

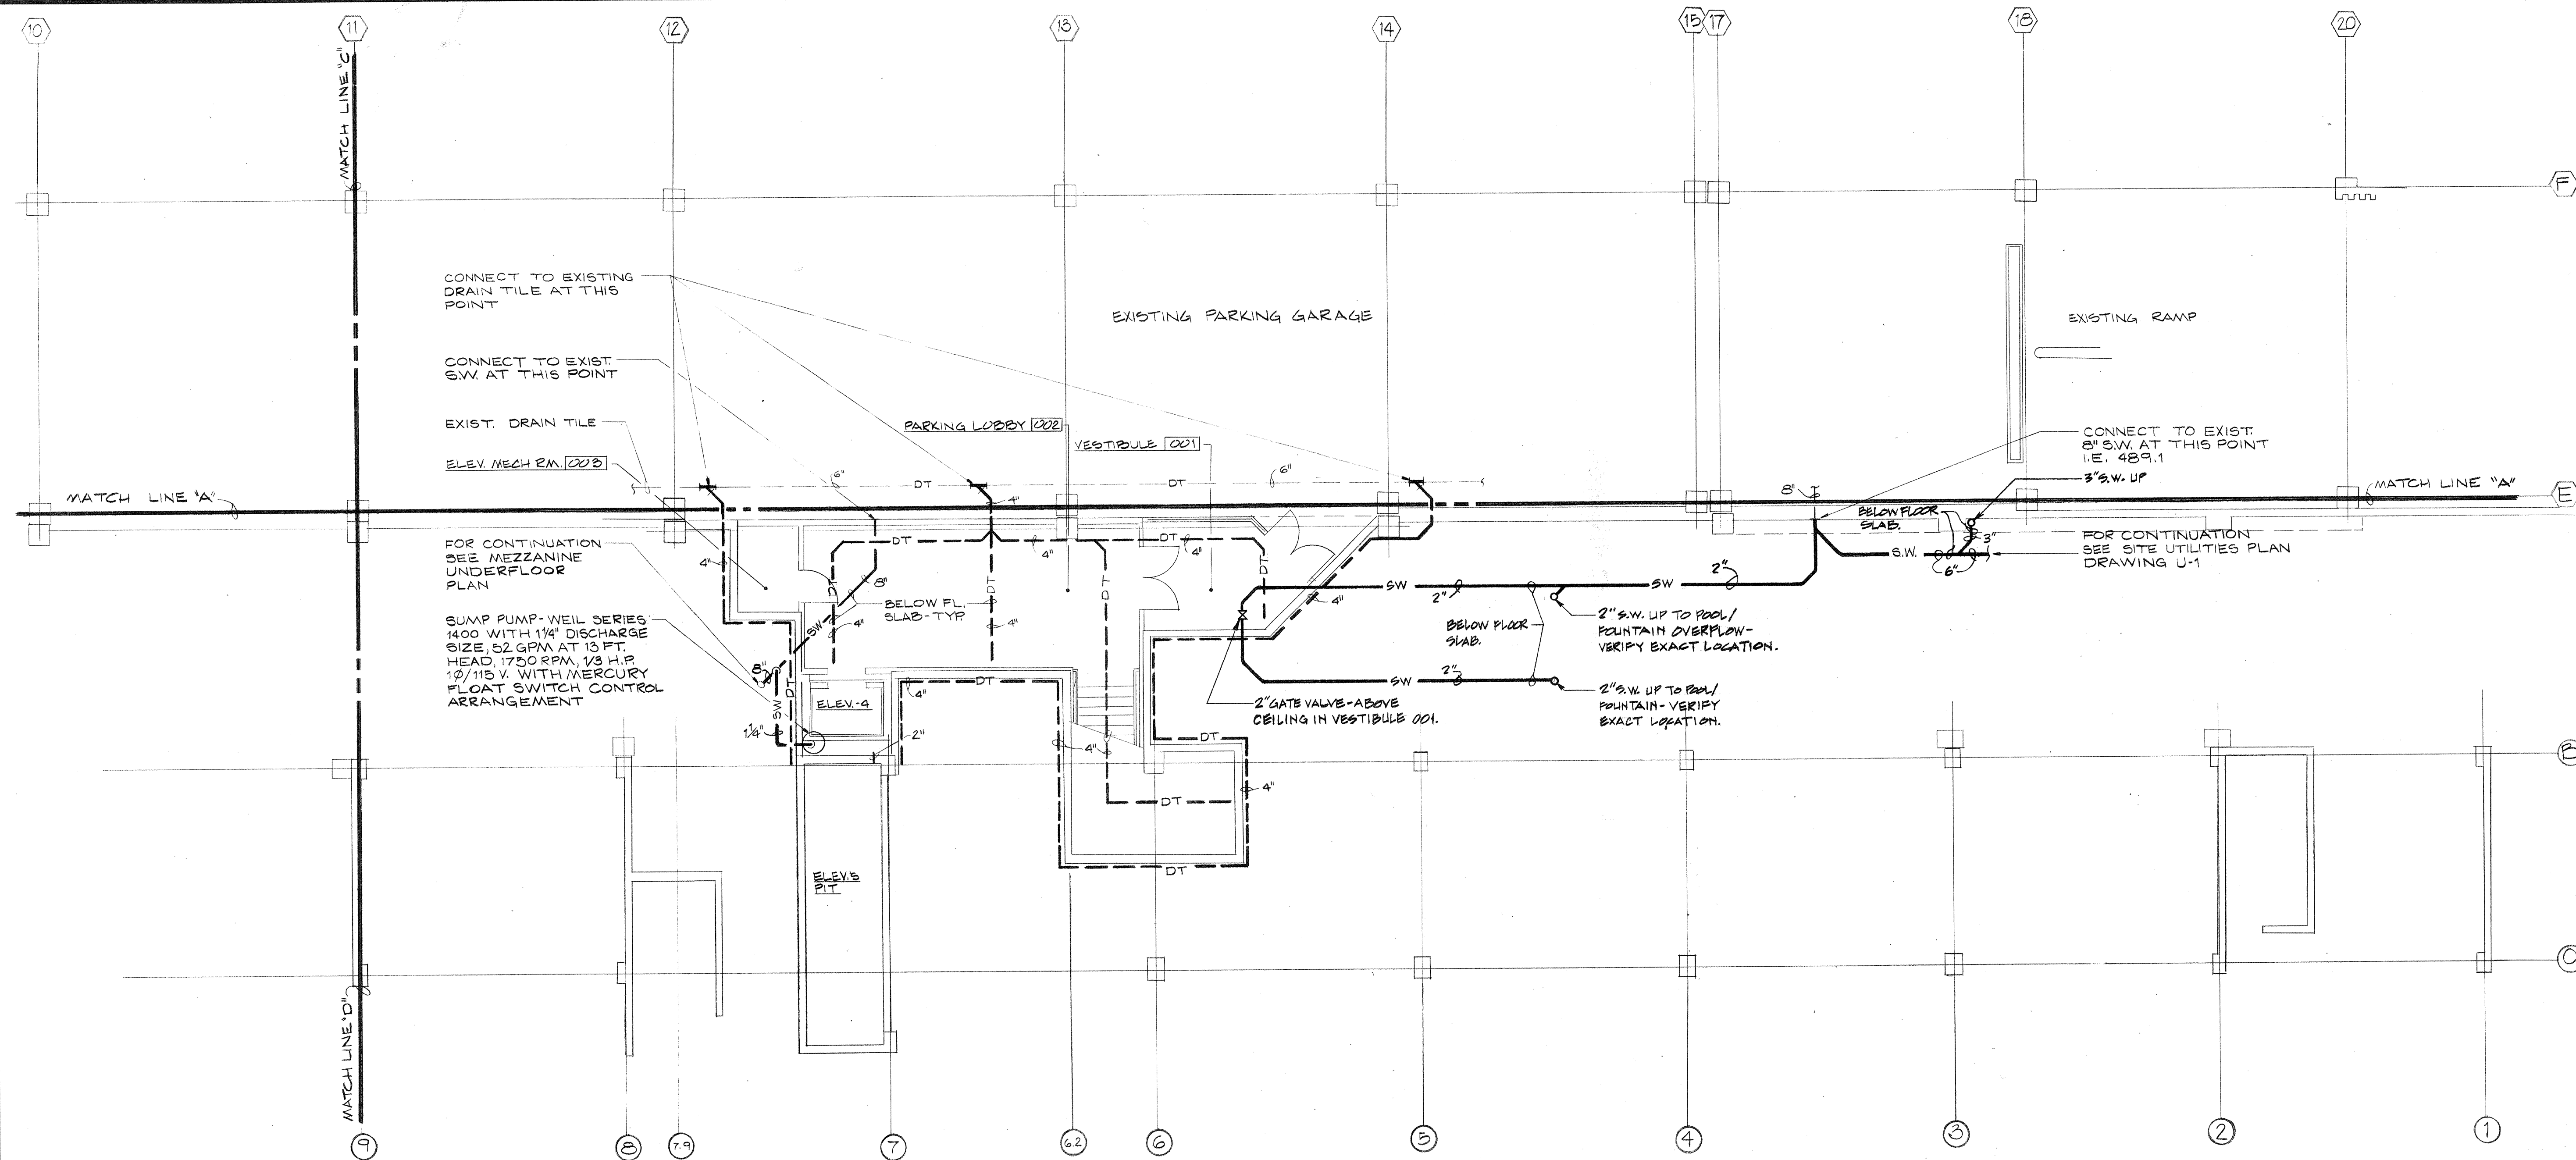
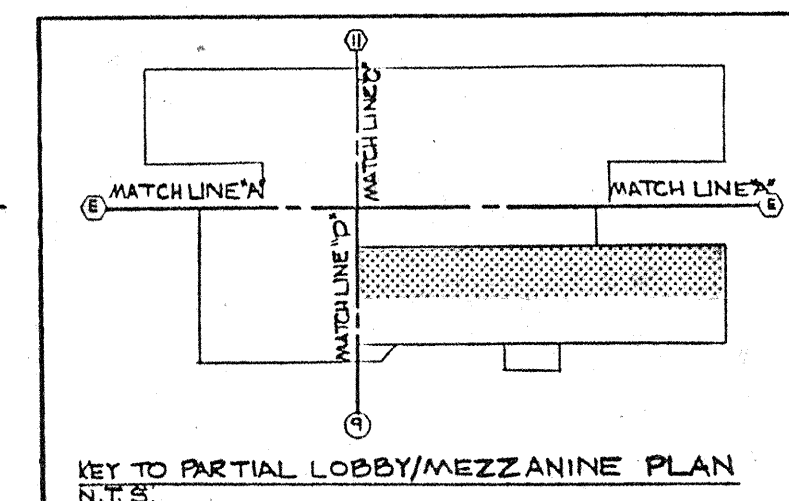


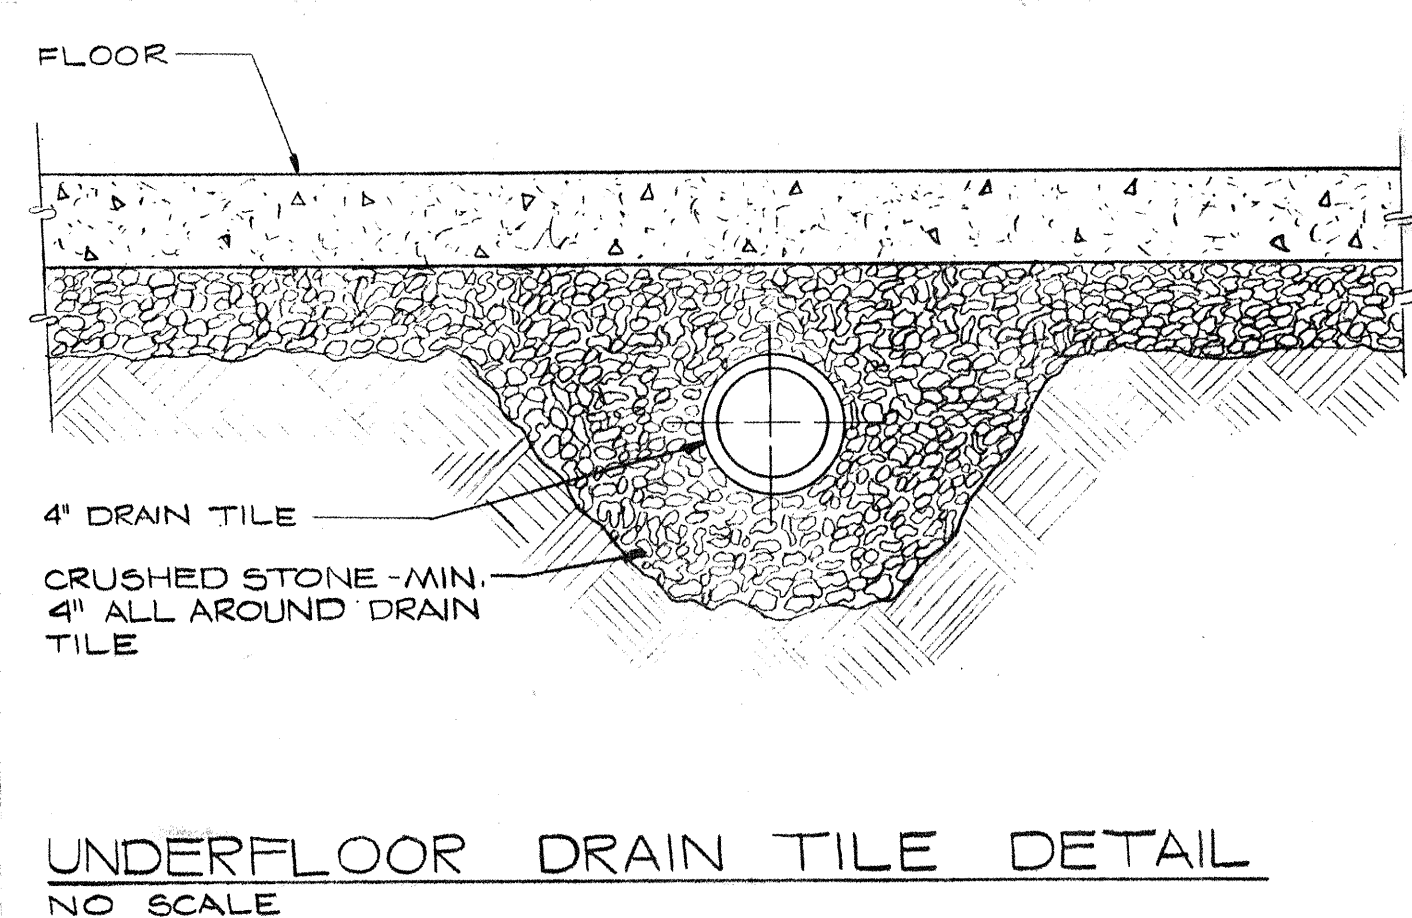

UNDERFLOOR PLUMBING PLAN - BASEMENT
 SCALE: 1/8" = 1'-0"

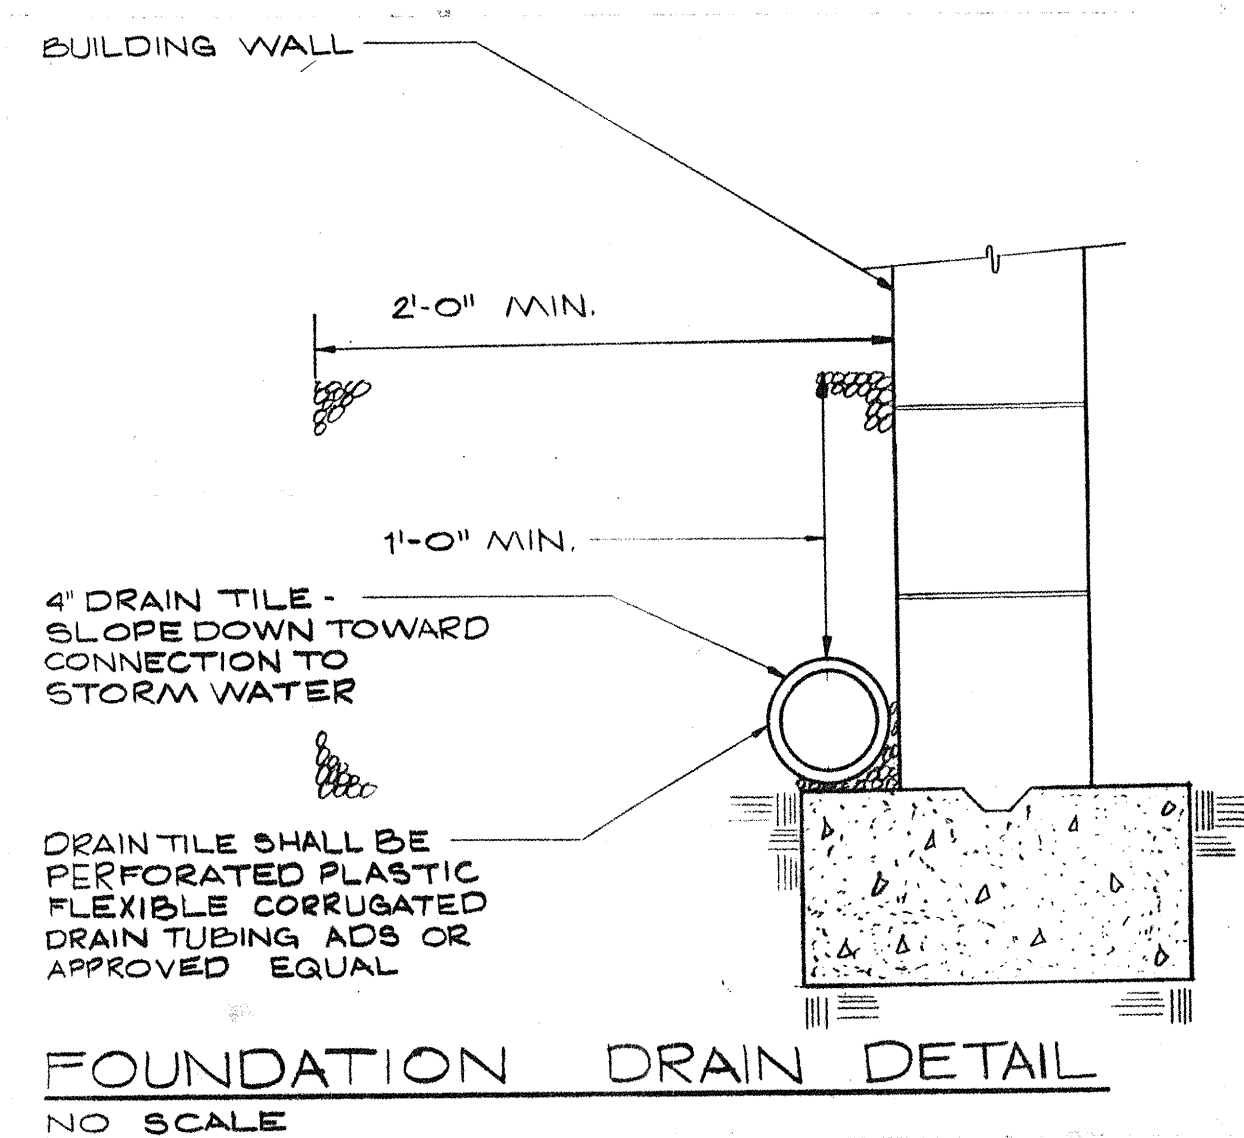

Consulting Engineers
 3257 Lochness Drive
 Lexington, Kentucky

CARTER - FOSTER INC.


CAPITOL PLAZA HOTEL
 FRANKFORT / KENTUCKY

JOHNSON / ROMANOWITZ / ARCHITECTS / KENTUCKY
 301 EAST VINE STREET, SUITE A
 TELEPHONE 1608/252-6781


STATE OF KENTUCKY
 TAGGART
 FOSTER
 6520
 PROFESSIONAL

STATE OF KENTUCKY
 GUY
 CARTER
 6521
 PROFESSIONAL

DRAWN B.H.	PROJECT
CHECKED B.H.	DATE 5-10-83
PLUMBING	
UNDERFLOOR PLUMBING PLAN - BASEMENT	
DRAWING	
P-1	

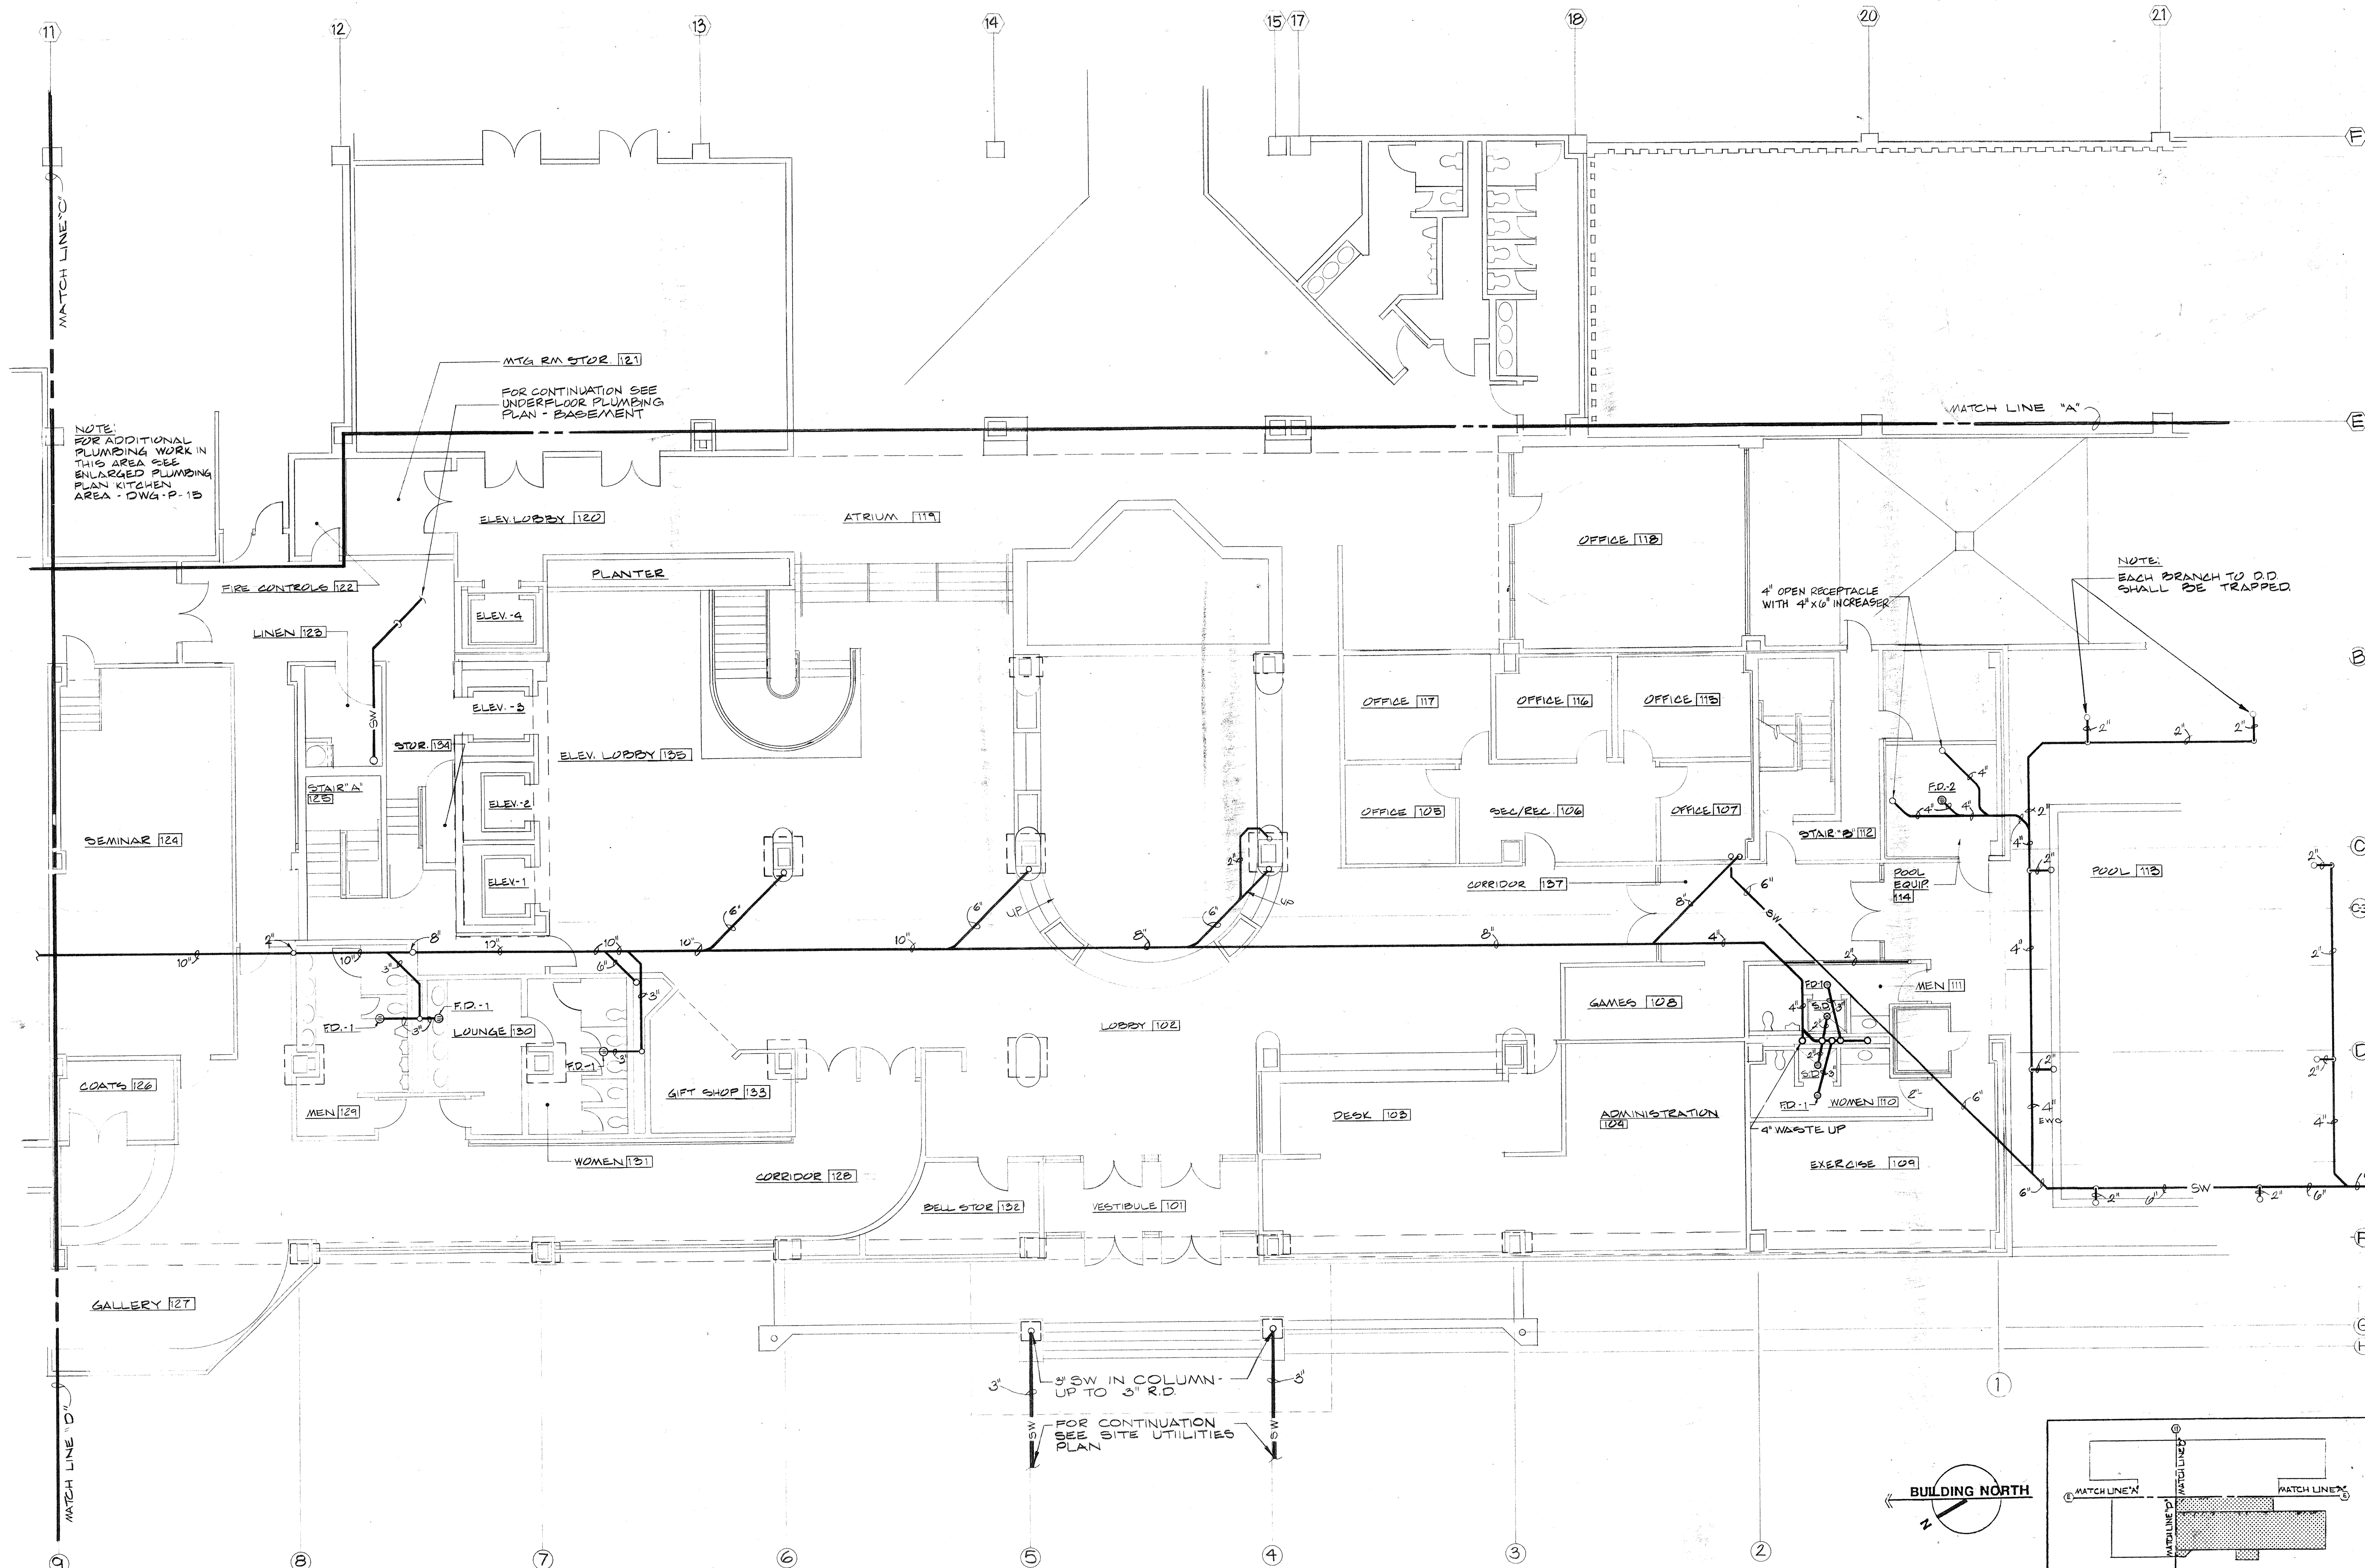




PARTIAL UNDERFLOOR PLUMBING PLAN - LOBBY/MEZZANINE LEVEL
SCALE: 1/8" = 1'-0"

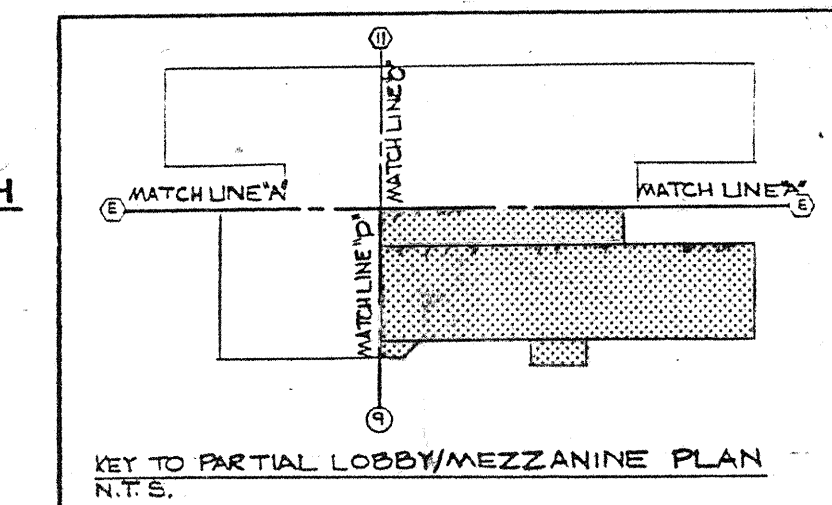

Consulting Engineers
3257 Lochness Drive
Lexington, Kentucky


CARTER - FOSTER INC.

CAPITOL PLAZA HOTEL
FRANKFORT / KENTUCKY

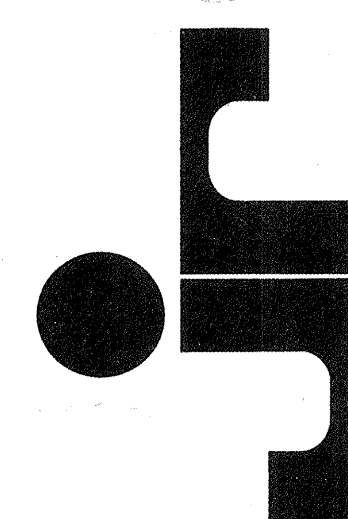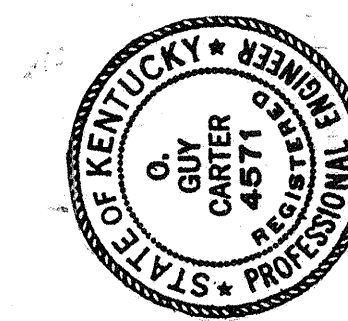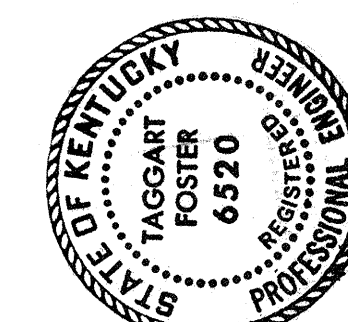

JOHNSON/ROMANOWICZ ARCHITECTS / LEXINGTON / KENTUCKY
301 EAST VINE STREET, SUITE A
TELEPHONE (606) 252-6781

DRAWN BH	PROJECT
CHECKED	DATE 5-10-83
PLUMBING	
PARTIAL UNDERFLOOR PLUMBING PLAN - LOBBY/MEZZANINE LEVEL	
DRAWING P-2	

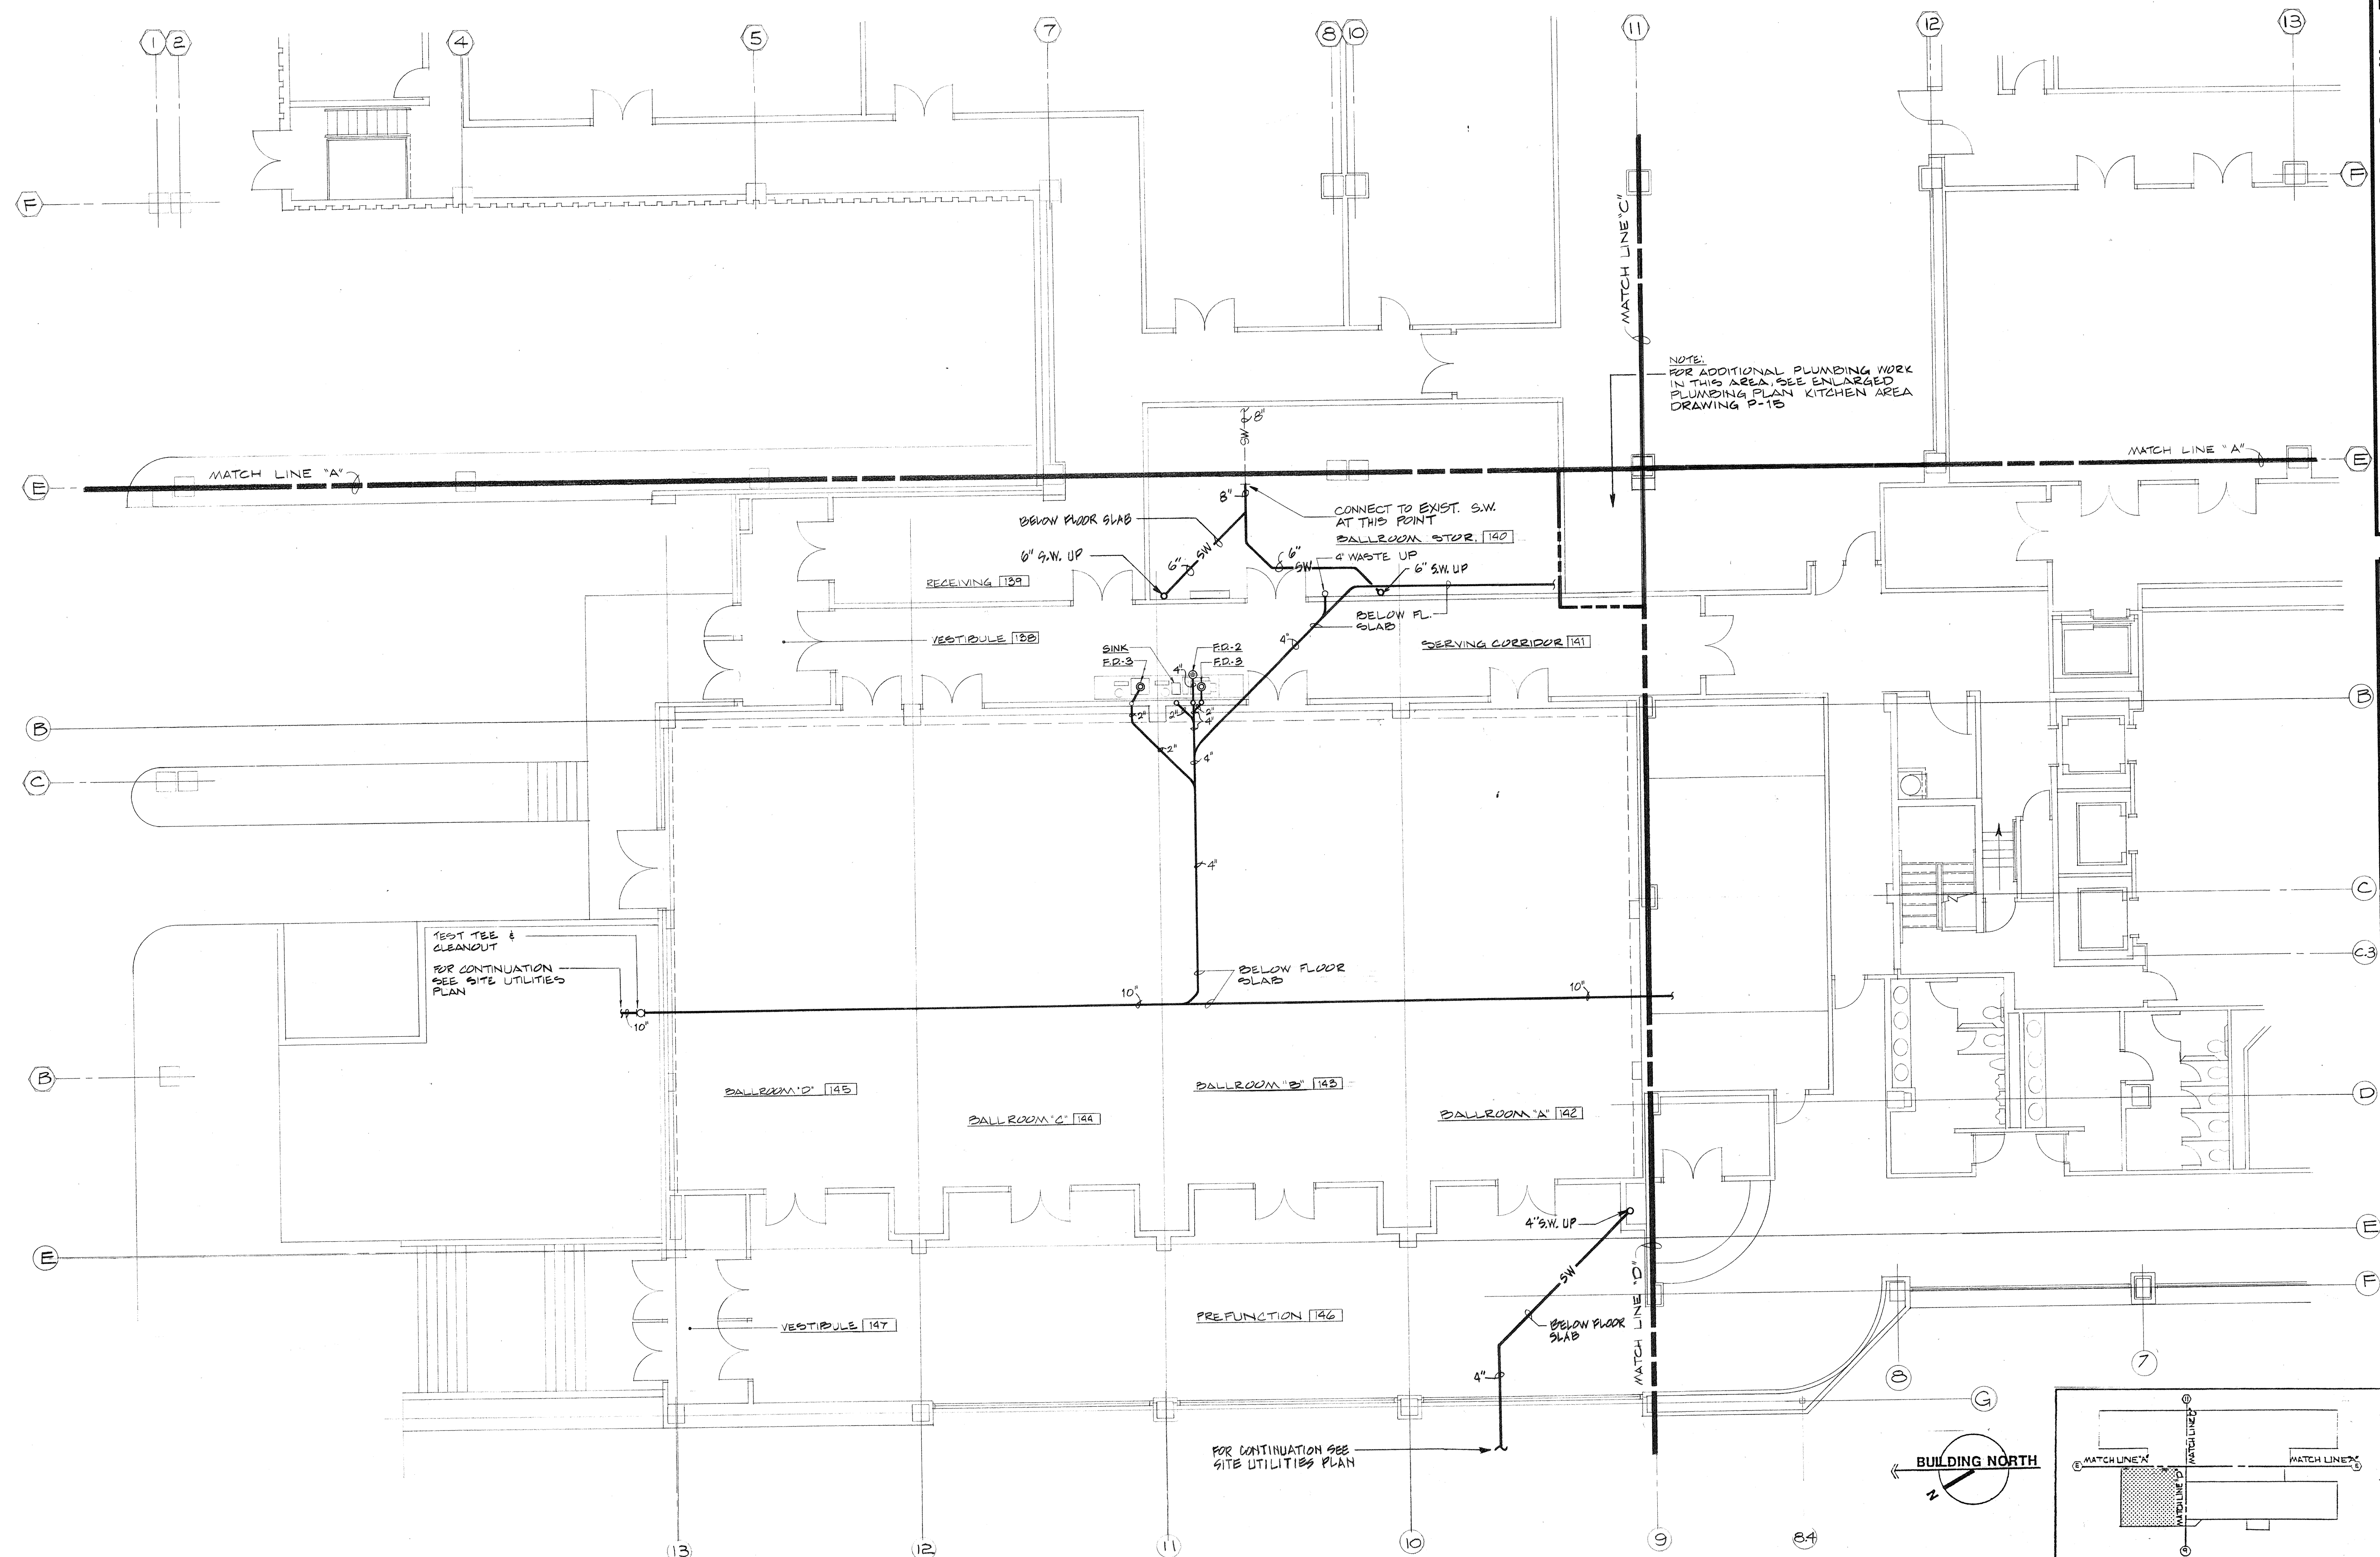

PARTIAL UNDERFLOOR PLUMBING PLAN - LOBBY/MEZZANINE LEVEL
SCALE: 1/8" = 1'-0"

Consulting Engineers
3257 Lochness Drive
Lexington, Kentucky

CARTER - FOSTER INC.

CAPITOL PLAZA HOTEL
FRANKFORT / KENTUCKY


JOHNSON / ROMANOWITZ / ARCHITECTS / LEXINGTON / KENTUCKY

STATE OF KENTUCKY
TAGCART
FOSTER
6520
PROFESSIONAL ENGINEER

STATE OF KENTUCKY
CARTER
4871
PROFESSIONAL ENGINEER

ji

DRAWN BH	PROJECT
CHECKED BH	DATE 5-10-83
PLUMBING	
PARTIAL UNDERFLOOR PLUMBING PLAN - LOBBY/MEZZANINE LEVEL	
DRAWING P-3	


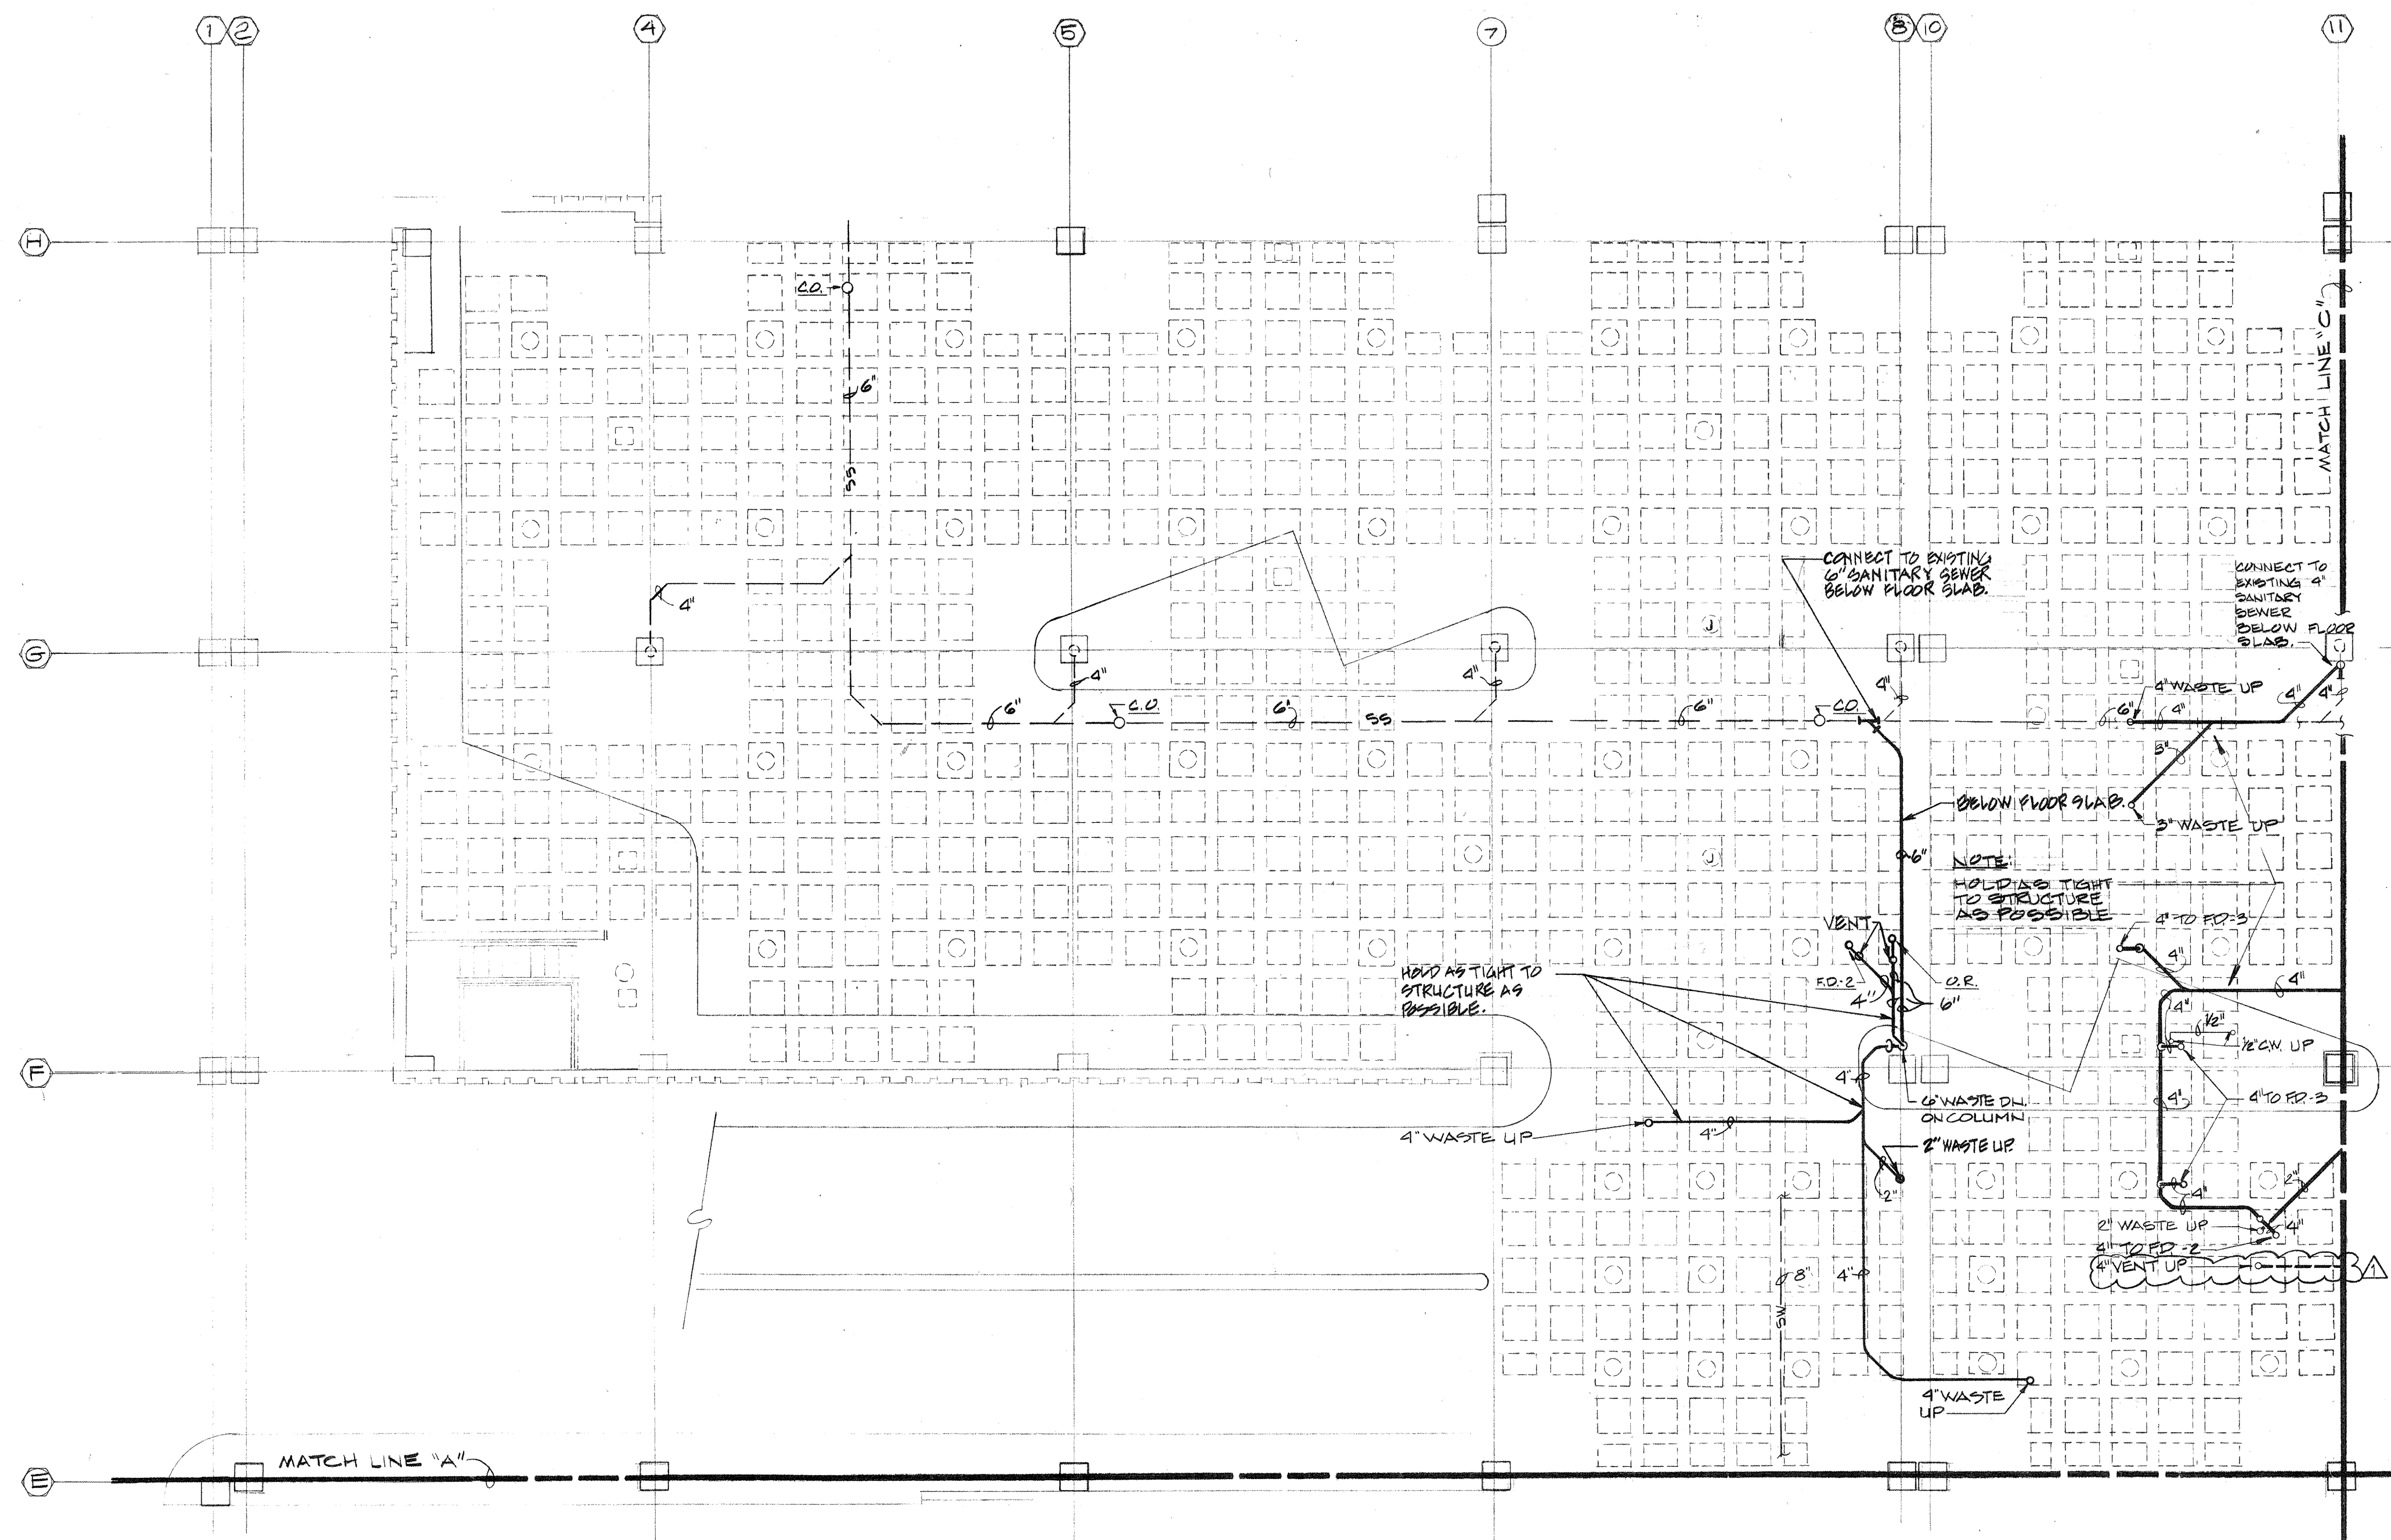


PARTIAL PLUMBING PLAN-EXISTING GARAGE
SCALE: 1/8" = 1'-0"

PLUMBING LEGEND	
---	SOIL OR WASTE
---	VENT
SW	STORM WATER
SW	EXISTING STORM WATER
SS	EXISTING SANITARY SEWER
---	COLD WATER
110°	110° HOT WATER
110R	110° RECIRCULATING HOT WATER
140°	140° HOT WATER
140R	140° RECIRCULATING HOT WATER
180°	180° HOT WATER
180R	180° RECIRCULATING HOT WATER
U	UNION
GV	GATE VALVE
CV	CHECK VALVE
BV	BALANCING VALVE
W.C.	WATER CLOSET
U.R.	URINAL
LAV.	LAVATORY
B.T.	BATH TUB
SH.	SHOWER
S.D.	SHOWER DRAIN
F.D.	FLOOR DRAIN
H.D.	HOPPER DRAIN
O.R.	OPEN RECEPTACLE
R.D.	ROOF DRAIN
S.S.	SERVICE SINK
C.O.	CLEAN OUT

SCHEDULE OF FIXTURE MOUNTING HEIGHTS			
FIXTURE	MOUNTING	MOUNTING HEIGHTS	REMARKS
WATER CLOSET (W.C.-1)	FLOOR	15"	FROM FINISHED FLOOR TO RIM OF CLOSET.
WATER CLOSET (W.C.-2)	FLOOR	17"-19"	FROM FINISHED FLOOR TO TOP OF SEAT.
WATER CLOSET (W.C.-3)	WALL	15"	FROM FINISHED FLOOR TO RIM OF CLOSET.
WATER CLOSET (W.C.-4)	WALL	17"-19"	FROM FINISHED FLOOR TO TOP OF SEAT.
URINAL (U.R.-1)	WALL	24"	FROM FINISHED FLOOR TO LIP.
URINAL (U.R.-2)	WALL	17"	FROM FINISHED FLOOR TO LIP.
LAVATORY (LAV.-4)	WALL	31"	FROM FINISHED FLOOR TO TOP OF BASIN.
SERVICE SINK (S.S.)	WALL	26 1/4"	FROM FINISHED FLOOR TO TOP OF SUPPLY.
ELEC. WATER COOLER (E.W.C.-1)	WALL	40"	FROM FINISHED FLOOR TO TOP OF COOLER.
ELEC. WATER COOLER (E.W.C.-2)	WALL	36"	FROM FINISHED FLOOR TO TOP OF BUBBLER.

REVISIONS
 1. 7-21-83
 ADDED VENT PIPING
 ASSOCIATED WITH
 MASTER TRAP CHANGE

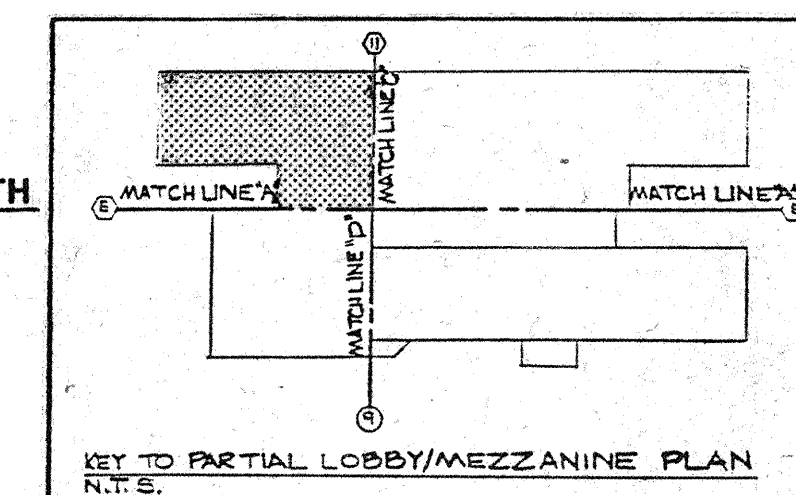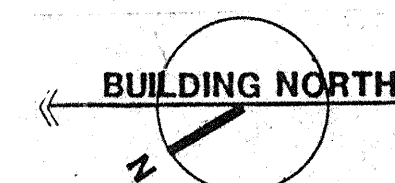

DRAWN B.H.	PROJECT
CHECKED T.F.	DATE 5-10-83
PLUMBING	
EXISTING PARTIAL UNDERFLOOR PLUMBING PLAN - GARAGE	
REISSUED 5-2-83	
DRAWING P-4	

REVISED - 7-5-83

JOHNSON / ROMANOWITZ / ARCHITECTS / LEXINGTON / KENTUCKY


STATE OF KENTUCKY
 REGISTERED PROFESSIONAL ARCHITECT
 TAG CARTER
 FOSTER
 6320

STATE OF KENTUCKY
 REGISTERED PROFESSIONAL ENGINEER
 GUY CARTER
 4571


CARTER - FOSTER INC.

Consulting Engineers
 3257 Lochness Drive
 Lexington, Kentucky

CAPITOL PLAZA HOTEL
 FRANKFORT / KENTUCKY

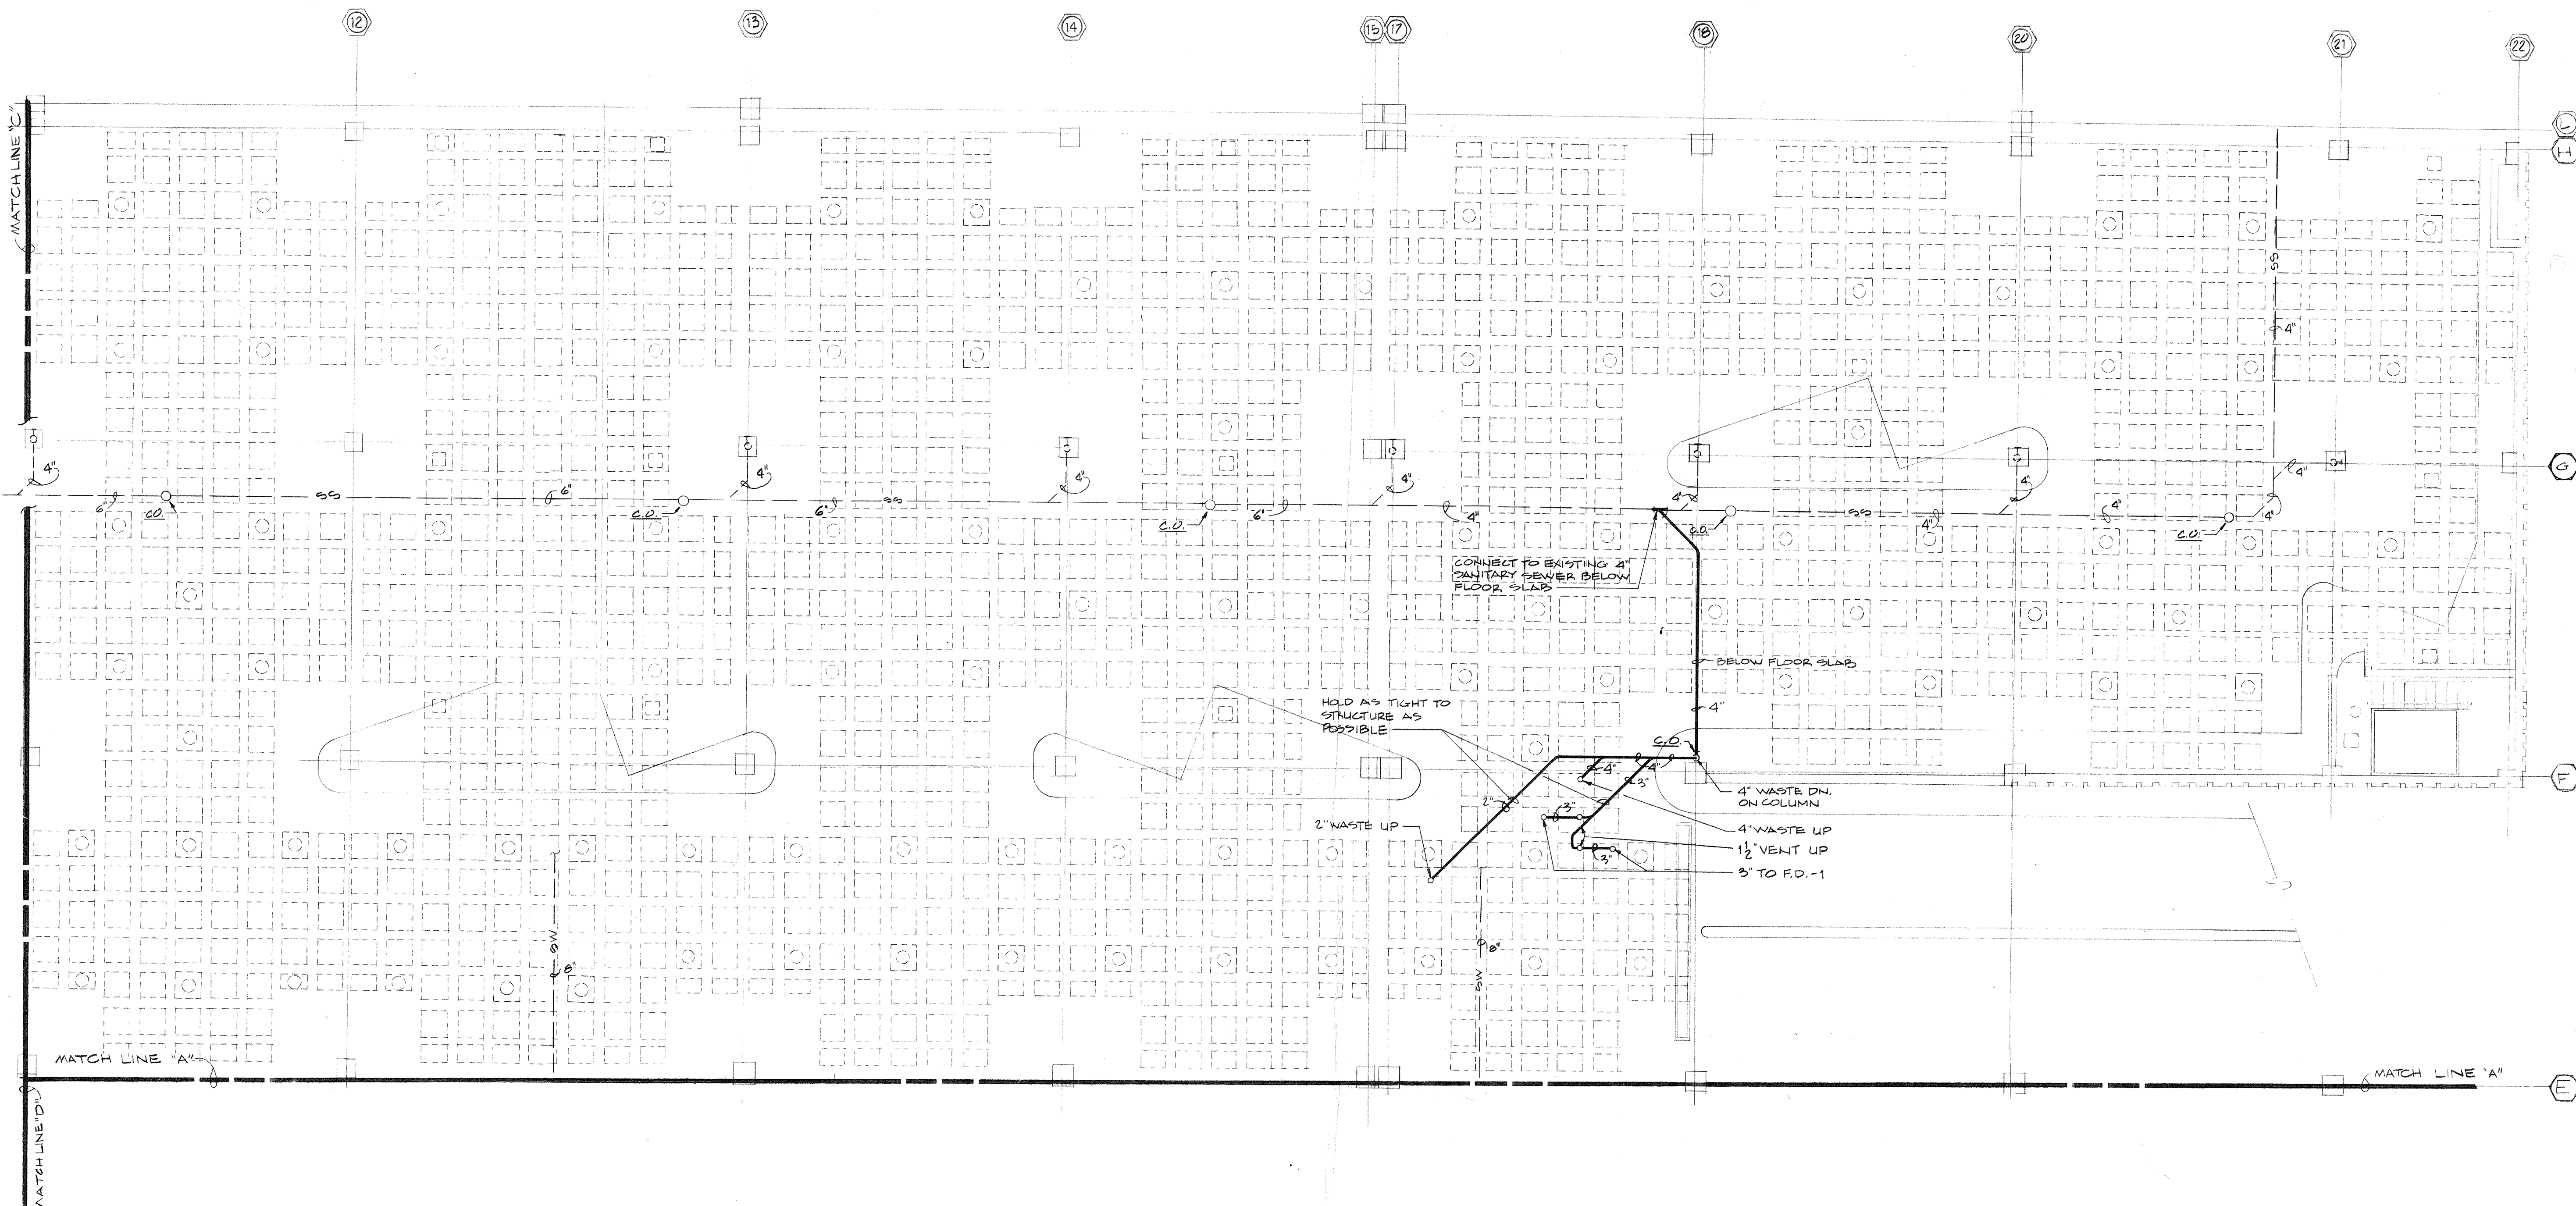

PARTIAL PLUMBING PLAN-EXISTING GARAGE
SCALE: 1/8" = 1'-0"

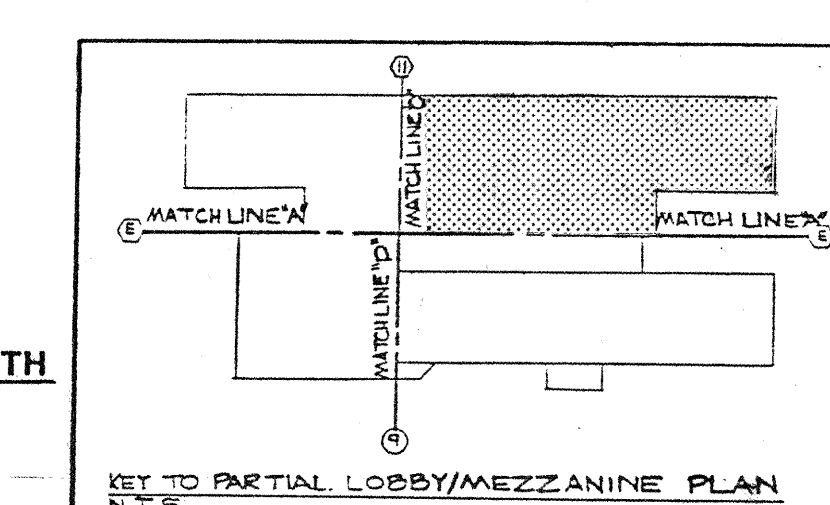



CARTER - FOSTER INC. Consulting Engineers 3257 Lochness Drive Lexington, Kentucky	CAPITOL PLAZA HOTEL FRANKFORT / KENTUCKY										
 GUY CARTER 4571 REGISTERED PROFESSIONAL AGGART FOSTER 6520 REGISTERED PROFESSIONAL JOHNSON / ROMANOWITZ / ARCHITECTS / LEXINGTON / KENTUCKY											
<table border="1" style="width: 100%; border-collapse: collapse;"> <tr> <td style="width: 50%; padding: 2px;">DRAWN BH</td> <td style="width: 50%; padding: 2px;">PROJECT</td> </tr> <tr> <td style="padding: 2px;">CHECKED</td> <td style="padding: 2px;">DATE 5-10-83</td> </tr> <tr> <td colspan="2" style="text-align: center; padding: 5px;">PLUMBING</td> </tr> <tr> <td colspan="2" style="padding: 2px;">EXISTING PARTIAL UNDERFLOOR PLUMBING PLAN - GARAGE</td> </tr> <tr> <td colspan="2" style="text-align: center; padding: 10px;"> DRAWING P-5 </td> </tr> </table>		DRAWN BH	PROJECT	CHECKED	DATE 5-10-83	PLUMBING		EXISTING PARTIAL UNDERFLOOR PLUMBING PLAN - GARAGE		DRAWING P-5	
DRAWN BH	PROJECT										
CHECKED	DATE 5-10-83										
PLUMBING											
EXISTING PARTIAL UNDERFLOOR PLUMBING PLAN - GARAGE											
DRAWING P-5											

Consulting Engineers
3257 Lochness Drive
Lexington, Kentucky

CARTER - FOSTER INC.

CAPITOL PLAZA HOTEL
FRANKFORT / KENTUCKY

JOHNSON / ROMANOWITZ ARCHITECTS / LEXINGTON / KENTUCKY

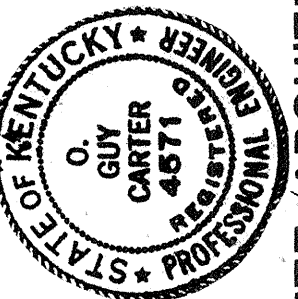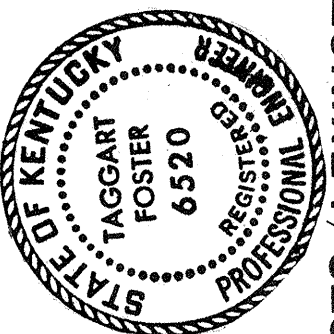

REVISED PLUMBING FIXTURES

LAVATORY - 2 (LAV-2): SAME AS ORIGINALLY SPECIFIED EXCEPT PROVIDE CHICAGO FAUCET NO. 2802A - E12 FAUCET WITH 6" WRIST BLADE HANDLES.


LAVATORY - 5 (LAV-5): AMERICAN STANDARD "AQUALYN" NO. 0475.020, VITREOUS CHINA SELF RIMMING OVAL LAVATORY, 20" X 17" WITH 1 1/4" WHEELCHAIR CAST GRID DRAIN WITH STRAINER AND OFFSET DRAIN ASSEMBLY, 1 1/4" CAST BRASS P-TRAP, CHROME PLATED WALL SUPPLIES WITH WHEEL HANDLE STOPS AND CHICAGO FAUCET NO. 2404-E12 FAUCET WITH 6" WRIST BLADE HANDLES AND 1/2 GPM FLOW RESTRICTOR. FAUCET SHALL MEET REQUIREMENTS OF KENTUCKY ENERGY CODE.

SHOWER (SH): POWERS TYPE 413 HYDROGUARD. PROVIDE PRESSURE BALANCED MIXING VALVE WITH INLET CHECKSTOPS, ELEVATED VACUUM BREAKER, THERMOMETER, ADJUSTABLE AND REMOVABLE SHOWER HEAD WITH GRAB BAR, REINFORCED VINYL HOSE AND DOLE 3.0 GPM FLOW REGULATOR.

URINAL-2 (UR-2): AMERICAN STANDARD "JETBROOK" MODEL 6570.014 VITREOUS CHINA WALL HUNG BLOWOUT URINAL WITH 2" OUTLET CONNECTION. SLOAN ROYAL NO. 180 FLUSH VALVE WITH VACUUM BREAKER AND SWEAT SOLDER ADAPTER KIT

REVISIONS
▲ 7-15-83
ADDED VENT PIPING
▲ 9-7-83

BUILDING NORTH

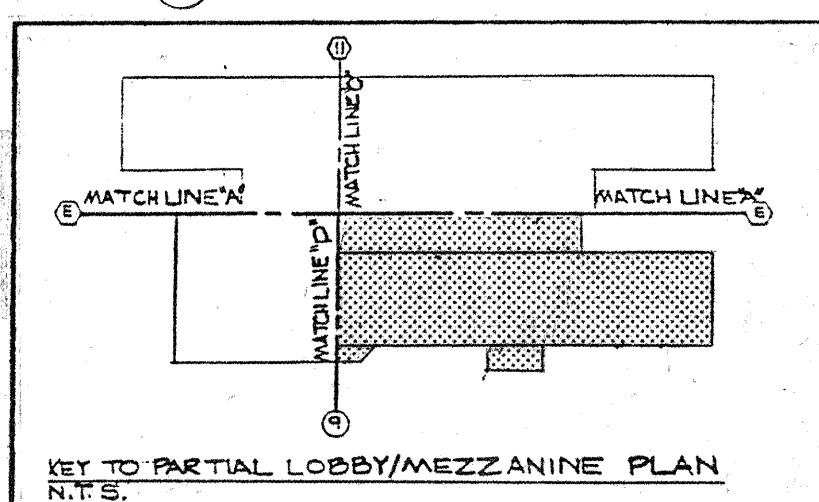

DRAWN BH	PROJECT
CHECKED T.F.	DATE 5-10-83

PLUMBING


PARTIAL PLUMBING PLAN - LOBBY/
MEZZANINE LEVEL

REISSUED 8-2-83


DRAWING
P-6

REISSUED 9-20-83



PARTIAL PLUMBING PLAN - LOBBY/MEZZANINE LEVEL
SCALE 1/8" = 1'-0"

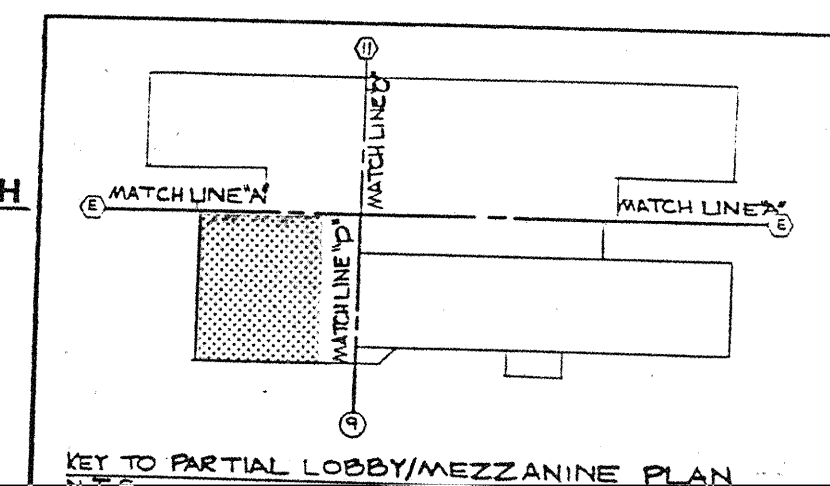

P-7

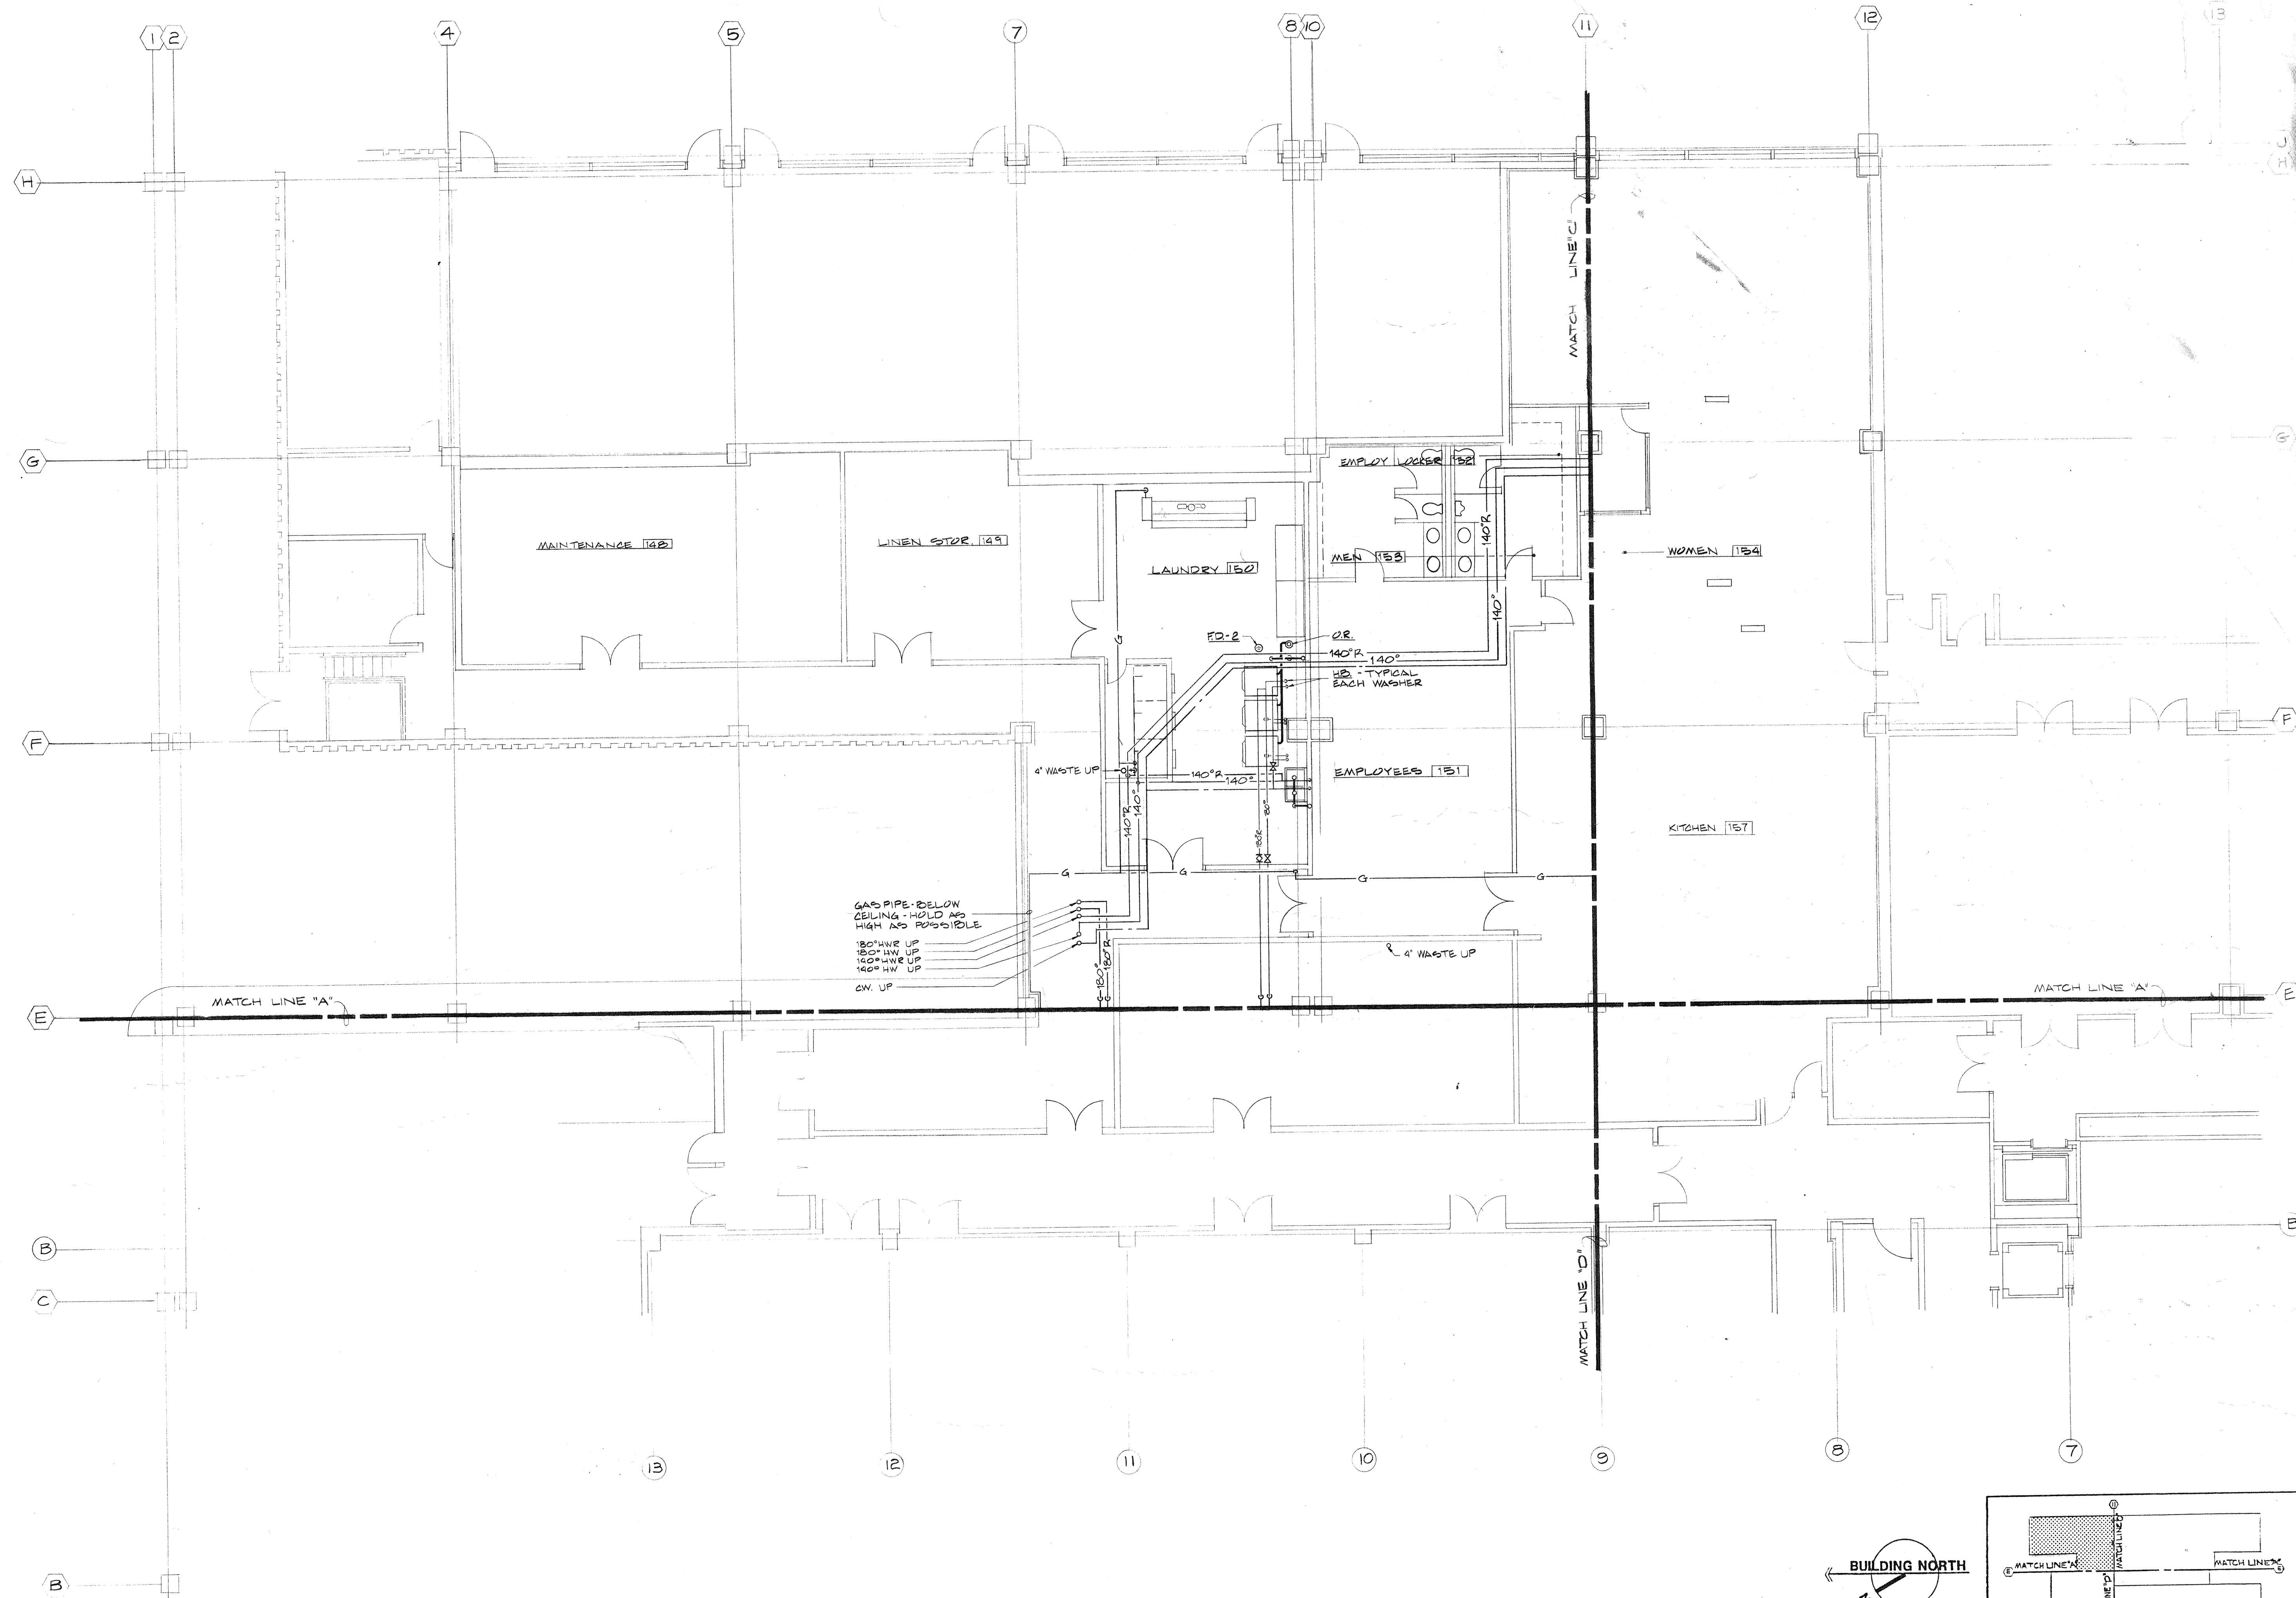

PARTIAL PLUMBING PLAN - LOBBY/MEZZANINE LEVEL
SCALE: 1/8" = 1'-0"

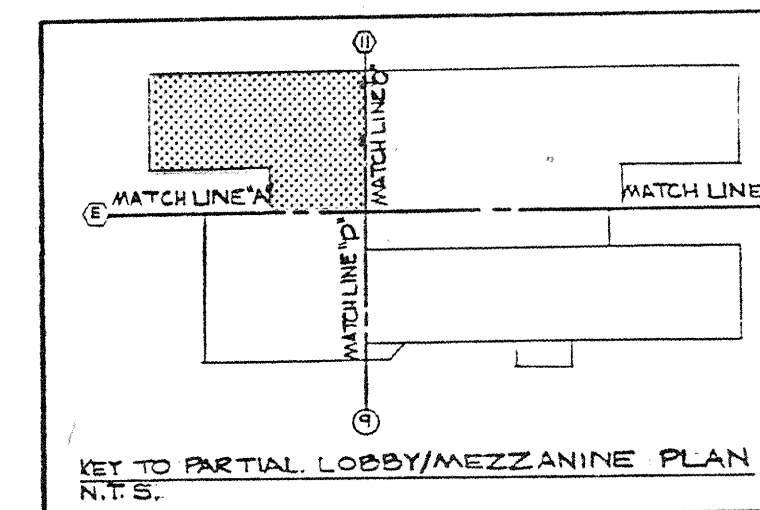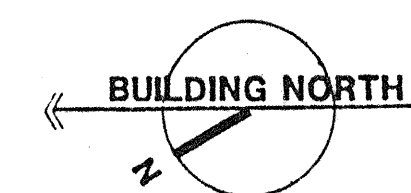

CARTER - FOSTER INC.
Consulting Engineers
3257 Locust Drive
Lexington, Kentucky


CAPITOL PLAZA HOTEL
FRANKFORT / KENTUCKY

JOHNSON / ROMANOWITZ / ARCHITECTS / LEXINGTON / KENTUCKY




STATE OF KENTUCKY
TAGART
FOSTER
6520
REGISTERED
PROFESSIONAL

STATE OF KENTUCKY
Q
CARTER
4511
REGISTERED
PROFESSIONAL

DRAWN BH	PROJECT
CHECKED BH	DATE 5-10-83
PLUMBING	
PARTIAL PLUMBING PLAN - LOBBY/ MEZZANINE LEVEL	
DRAWING P-8	

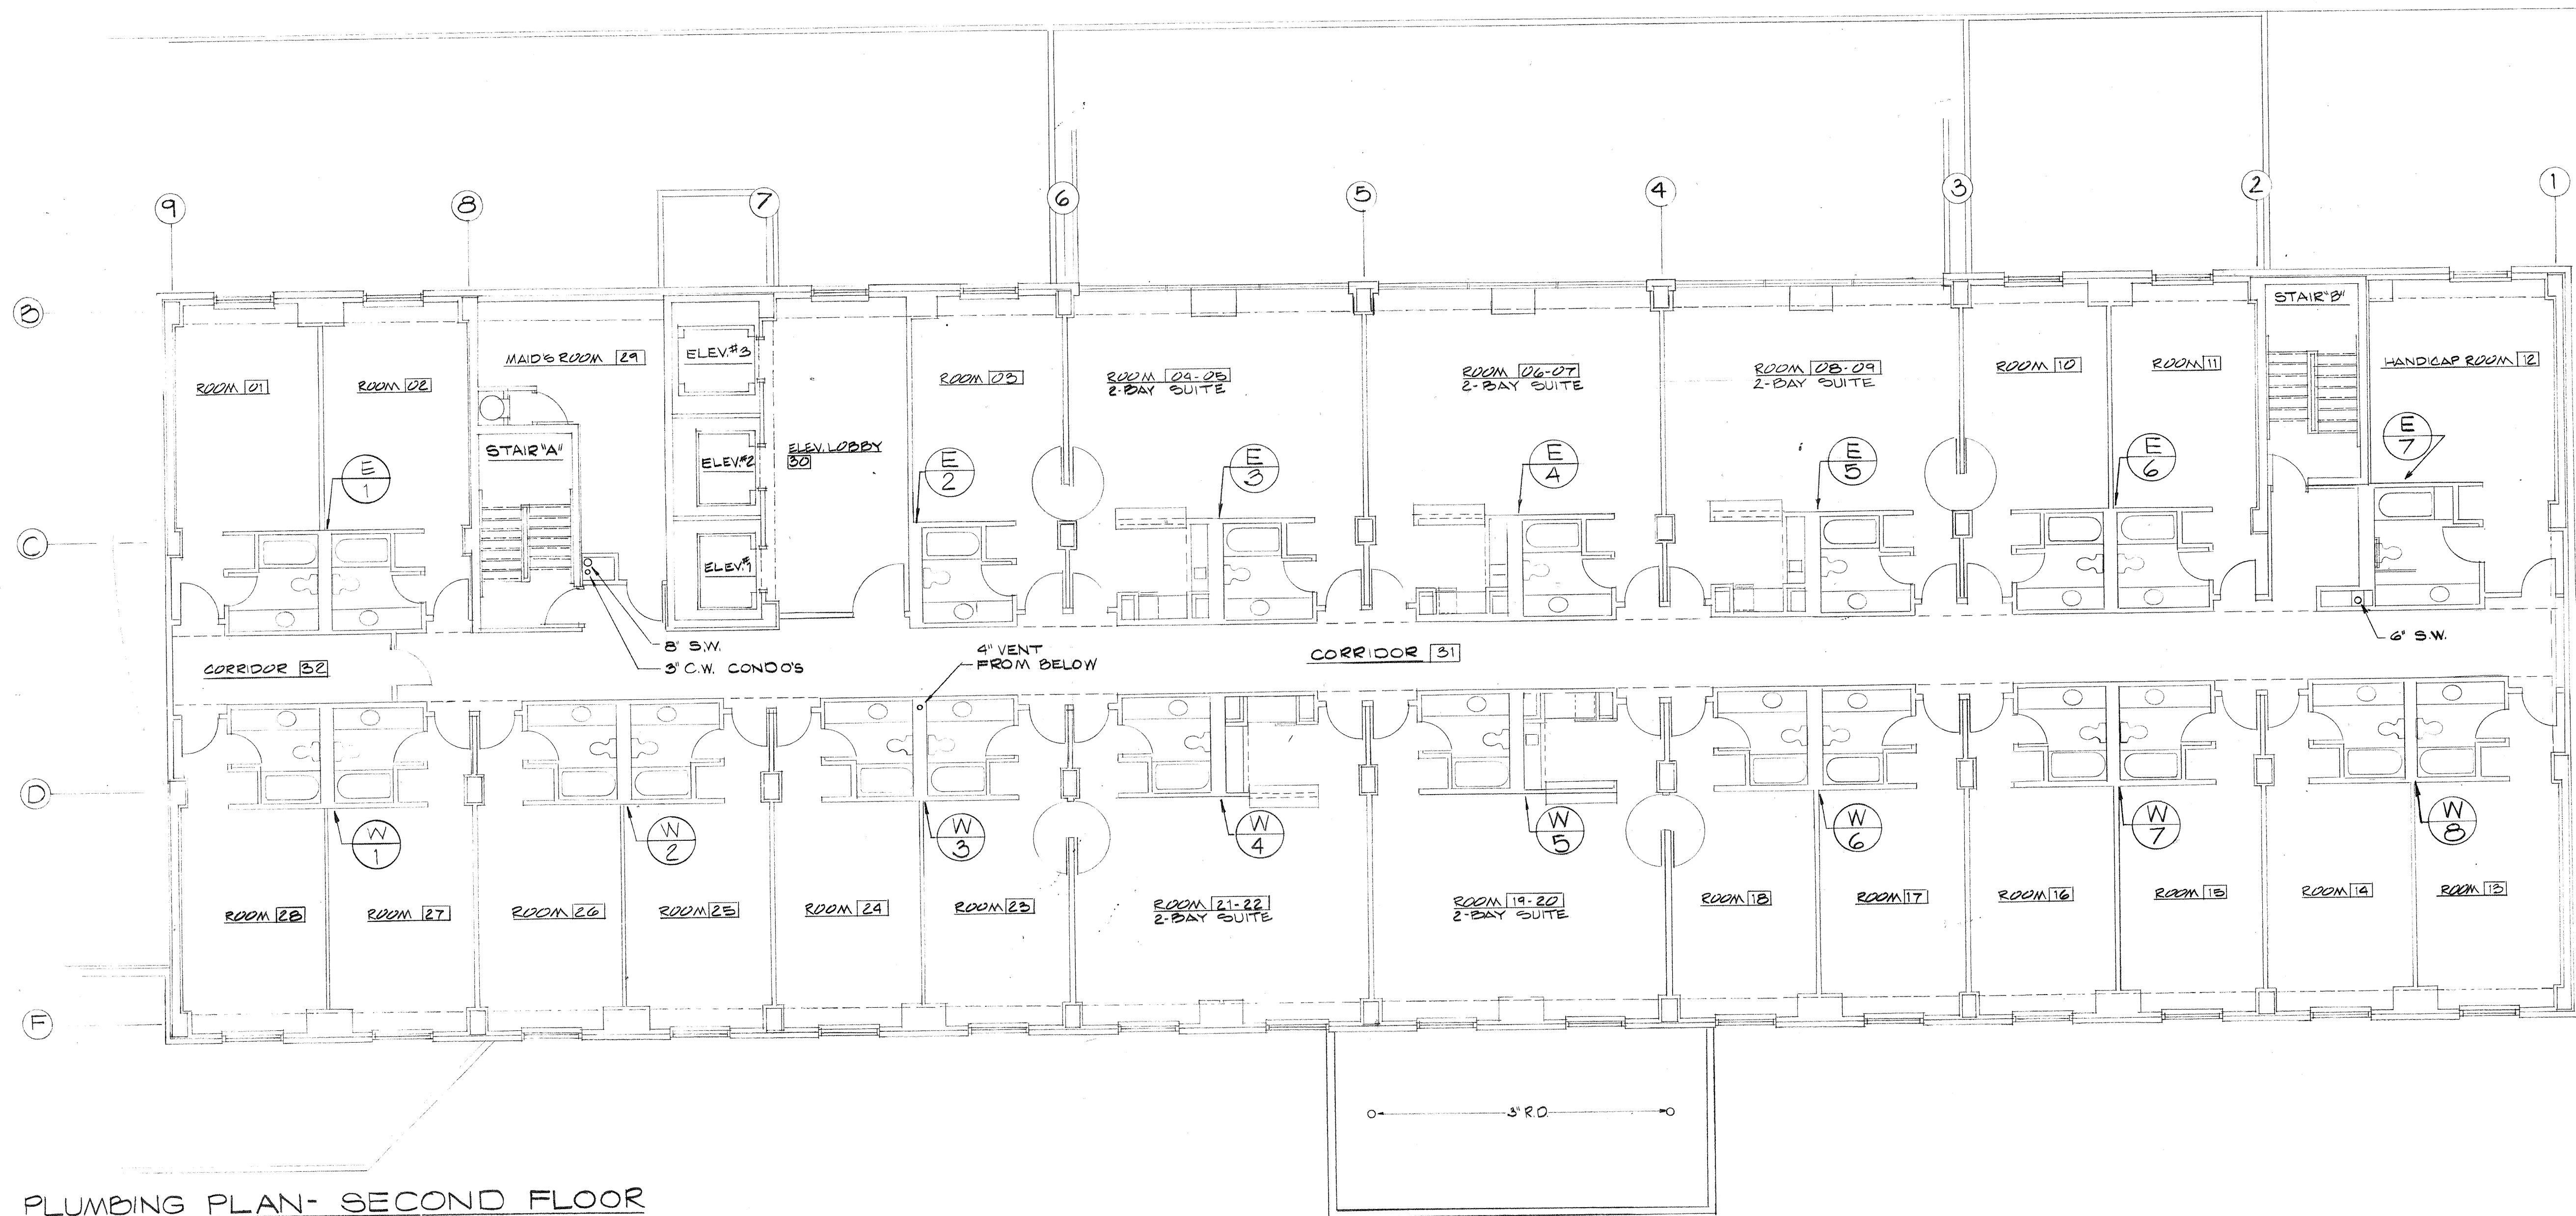

PLUMBING PLAN- SECOND FLOOR
SCALE: 1/8" = 1'-0"

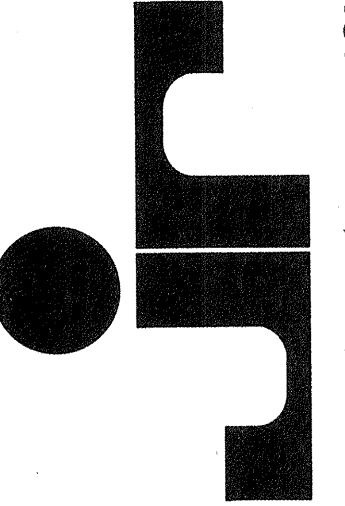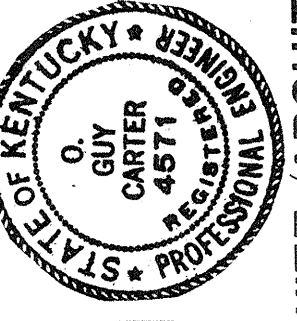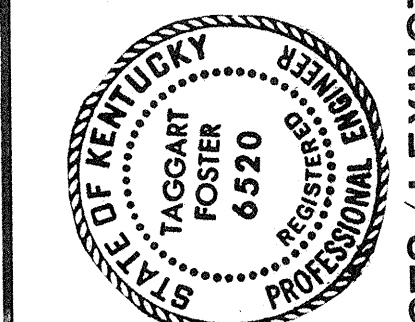


JOHNSON / ROMANOWITZ / ARCHITECTS / LEXINGTON / KENTUCKY

CARTER - FOSTER INC.


Consulting Engineers
3257 Lochness Drive
Lexington, Kentucky

CAPITOL PLAZA HOTEL
FRANKFORT / KENTUCKY

DRAWN BH	PROJECT
CHECKED	DATE 5-10-83
PLUMBING	
PLUMBING PLAN SECOND FLOOR	
DRAWING P-10	

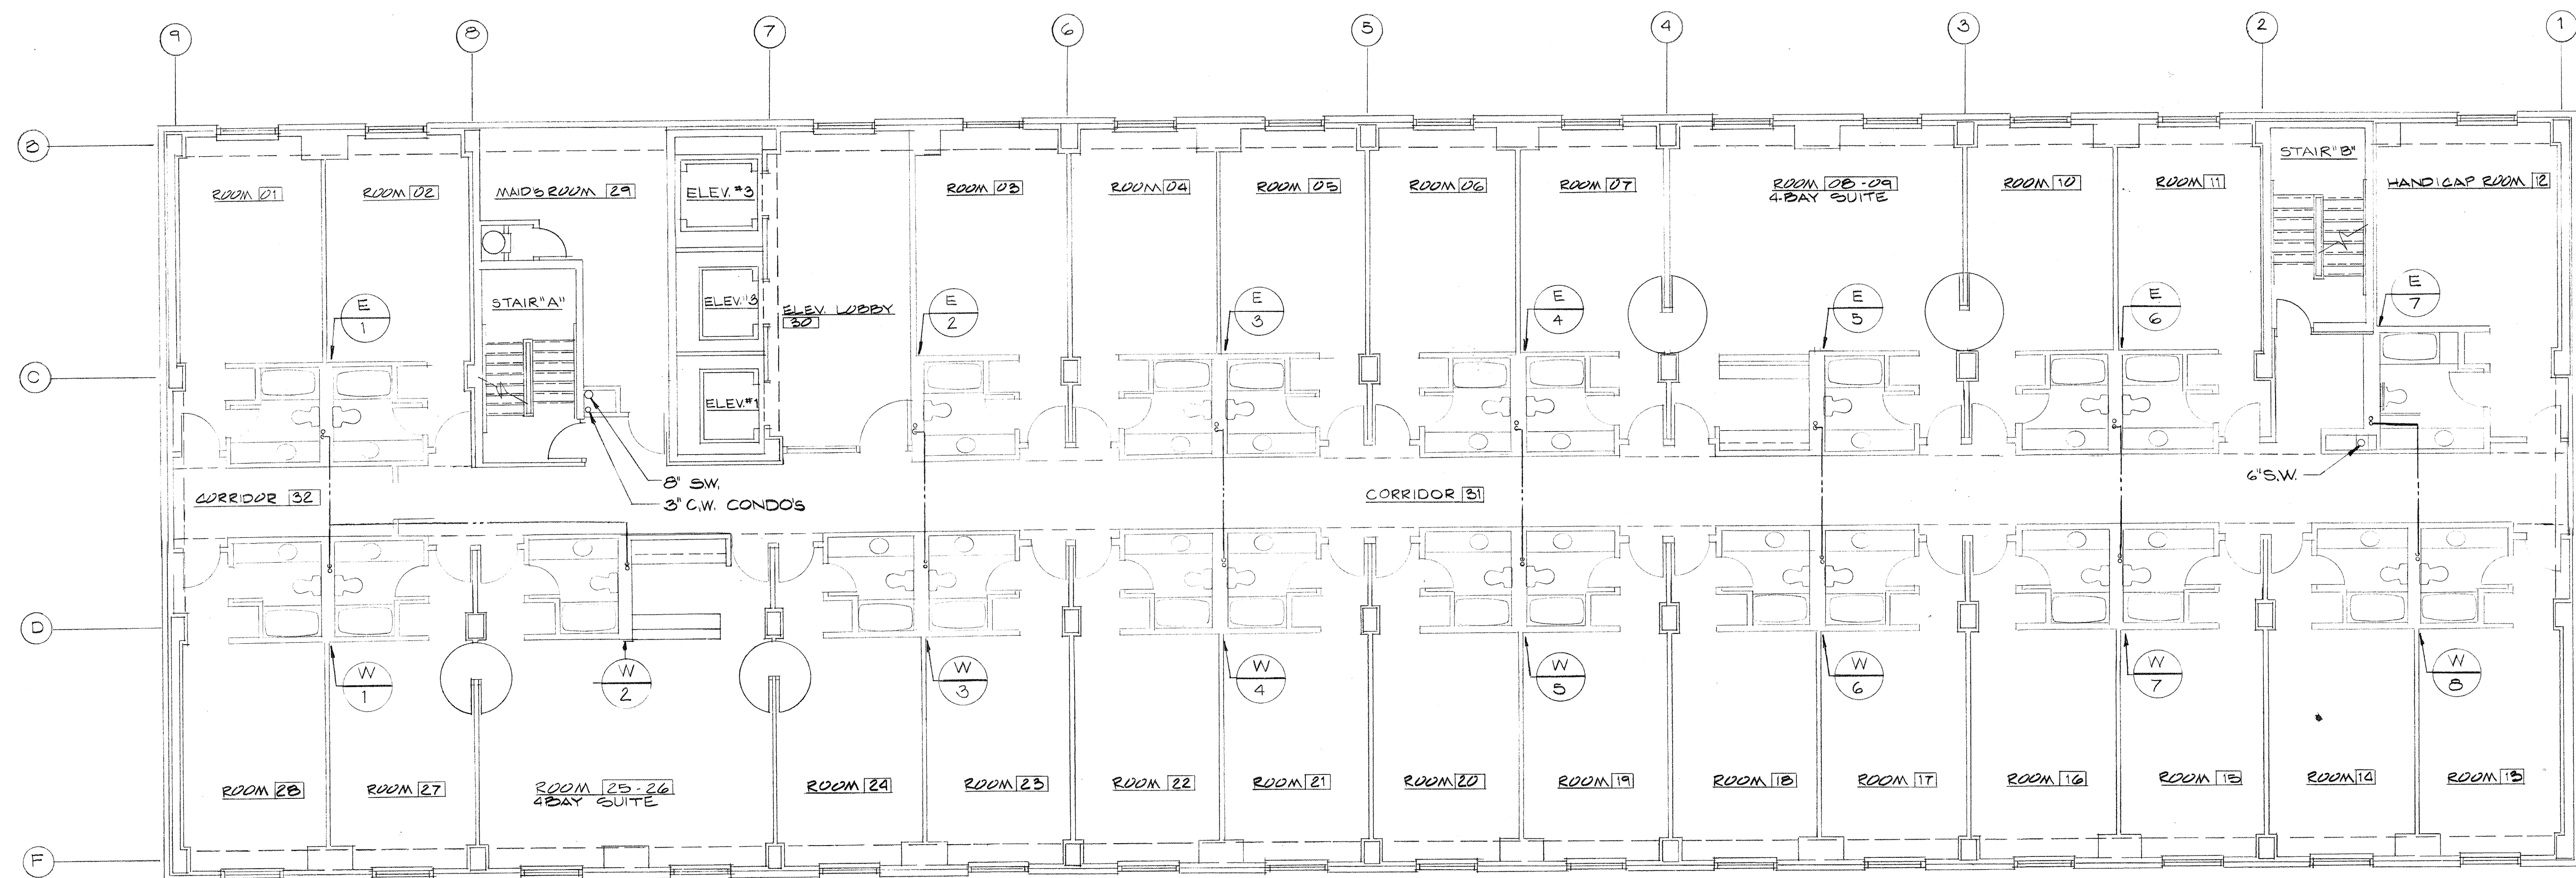

PLUMBING PLAN - 8TH FLOOR
SCALE: 1/8" = 1'-0"

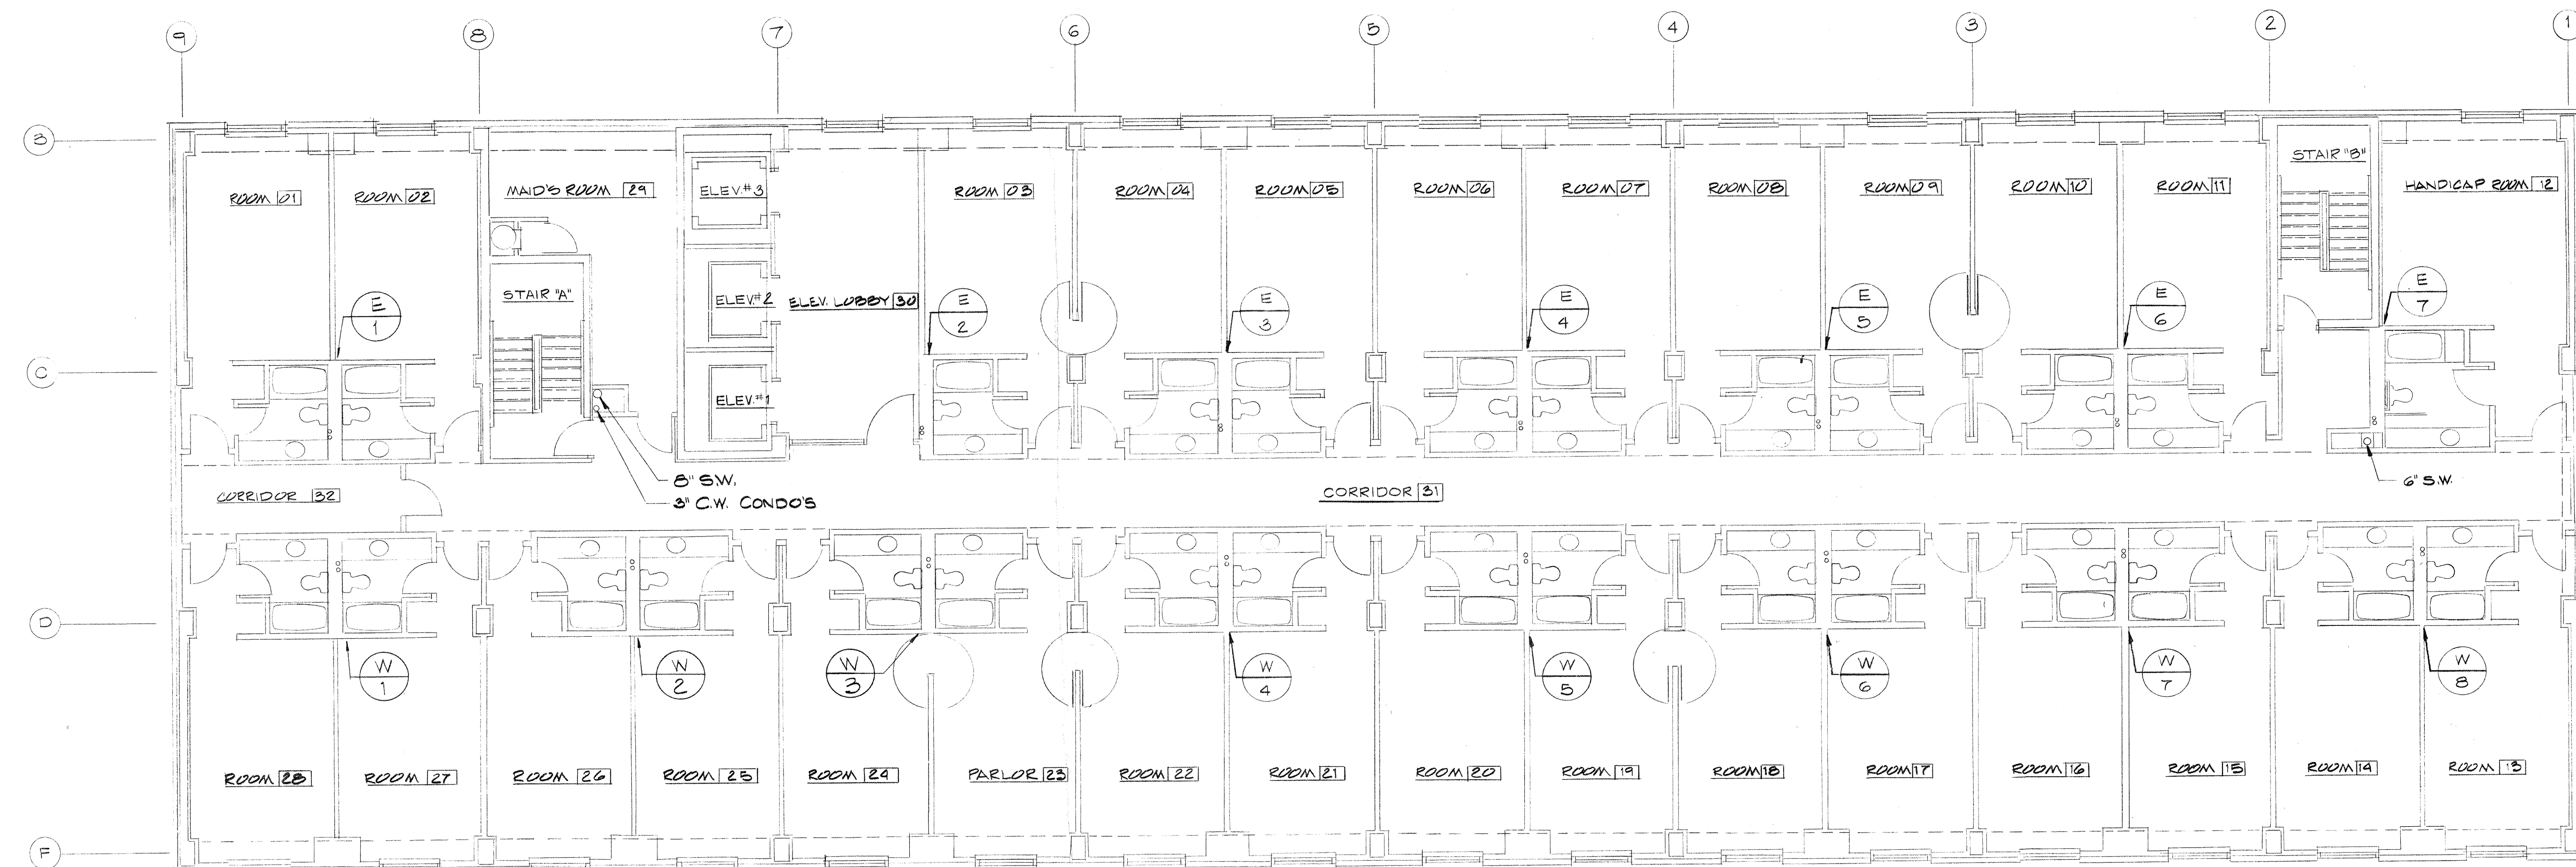



PLUMBING PLAN - 3RD THRU 7TH FLOOR
SCALE: 1/8" = 1'-0"



Consulting Engineers
3257 Lochness Drive
Lexington, Kentucky

CARTER - FOSTER INC.

CAPITOL PLAZA HOTEL
FRANKFORT / KENTUCKY

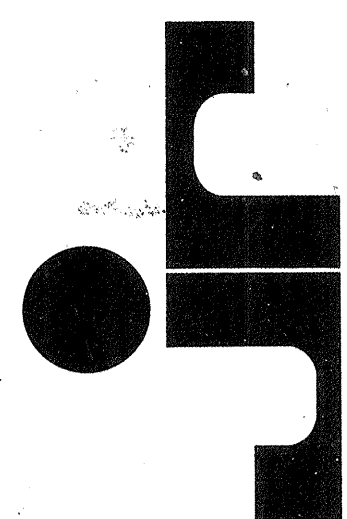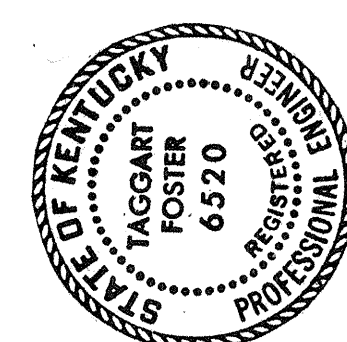

JOHNSON / ROMANOWITZ / ARCHITECTS / LEXINGTON / KENTUCKY

DRAWN 24	PROJECT
CHECKED	DATE 5-10-83

PLUMBING

PLUMBING PLANS -
3RD - 7TH FLOORS &
8TH FLOOR

DRAWING
P-11

Consulting Engineers
3257 Lochness Drive
Lexington, Kentucky

CARTER - FOSTER INC.


CAPITOL PLAZA HOTEL
FRANKFORT / KENTUCKY

JOHNSON / ROMANOWITZ / ARCHITECTS / LEXINGTON / KENTUCKY
301 EAST VINE STREET, SUITE A
TELEPHONE (606) 252-6781


STATE OF KENTUCKY
REGISTERED PROFESSIONAL
JAGGAR FOSTER
6570

STATE OF KENTUCKY
REGISTERED PROFESSIONAL
GUY CARTER
4571


DRAWN BH	PROJECT
CHECKED BH	DATE 5-10-83
PLUMBING	
PLUMBING PLAN - 9TH & 10TH FLOORS CONDOS	
DRAWING P-12	

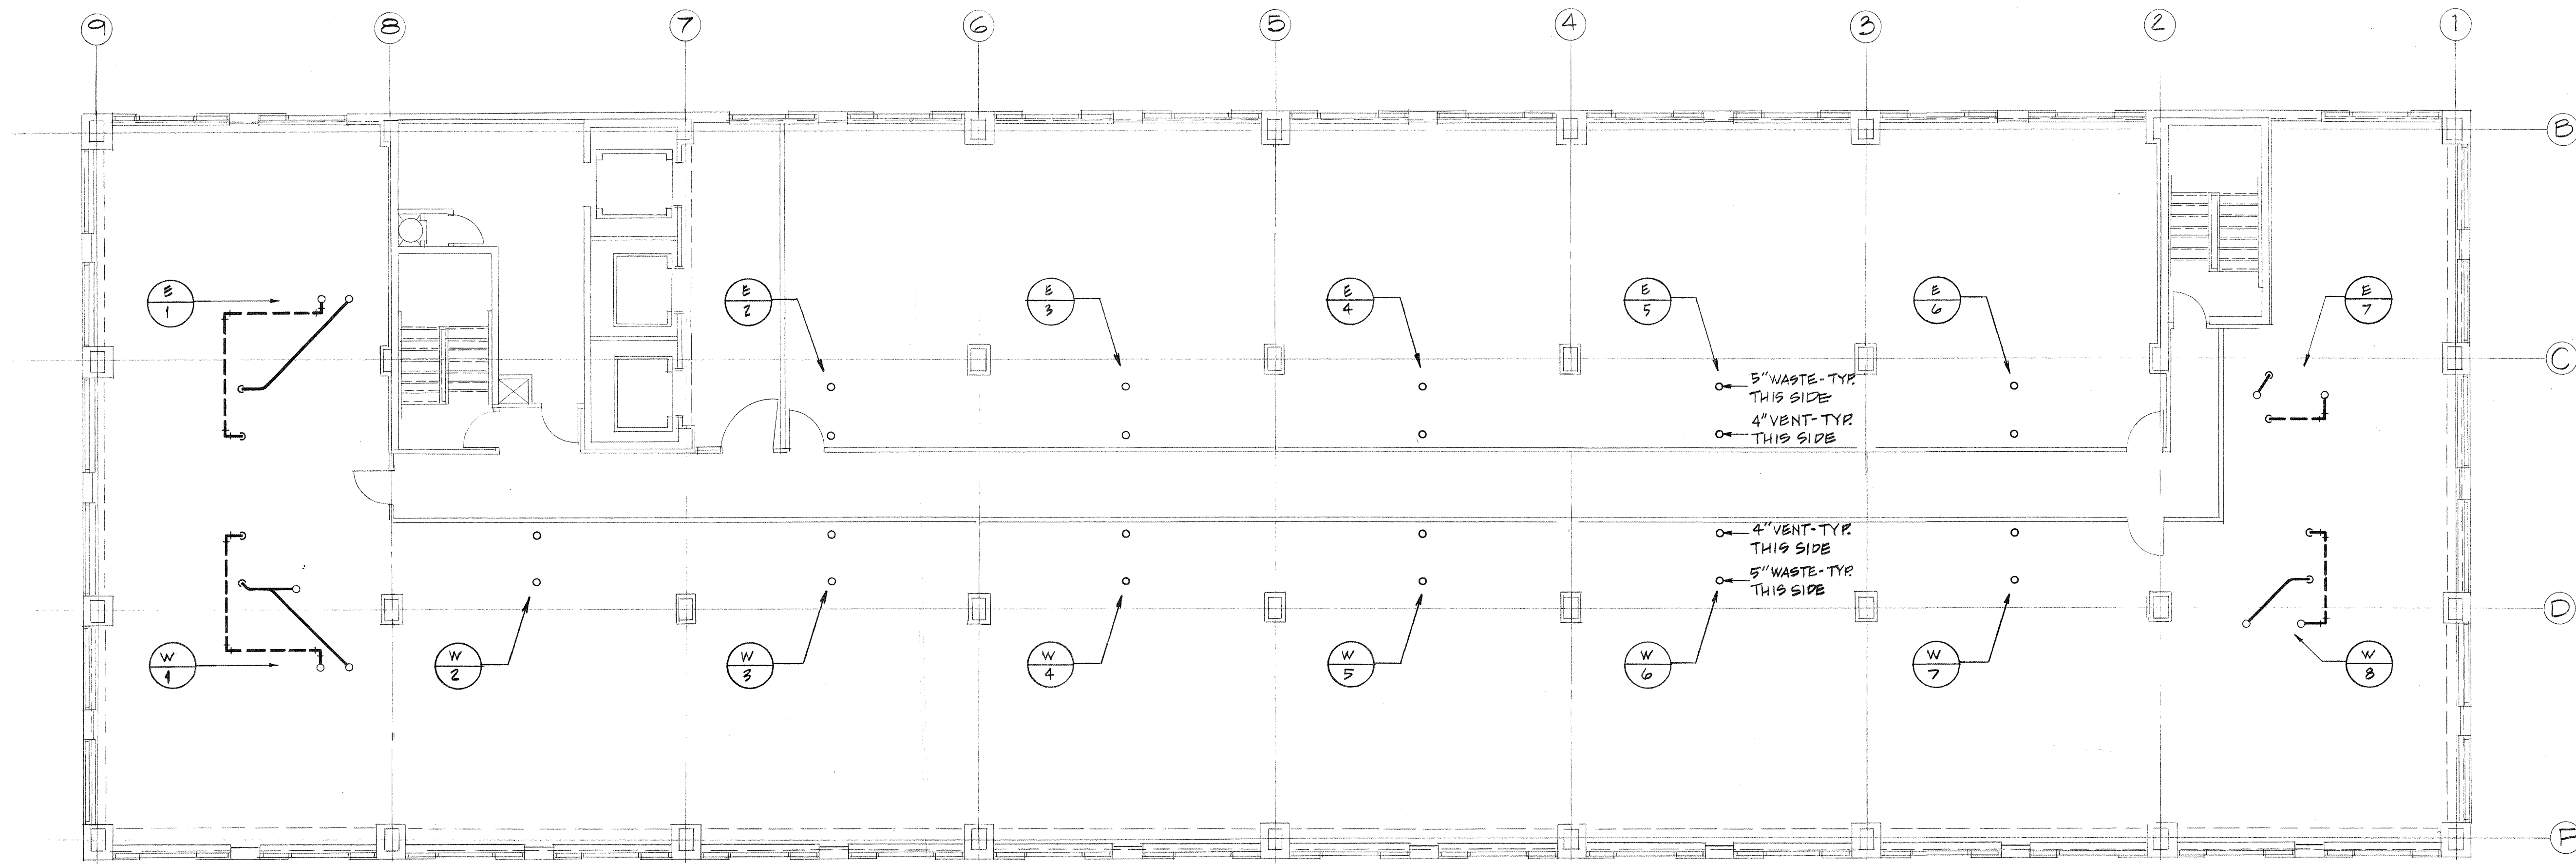

PLUMBING PLAN - 9TH FLOOR - CONDOMINIUMS
SCALE: 1/8" = 1'-0"

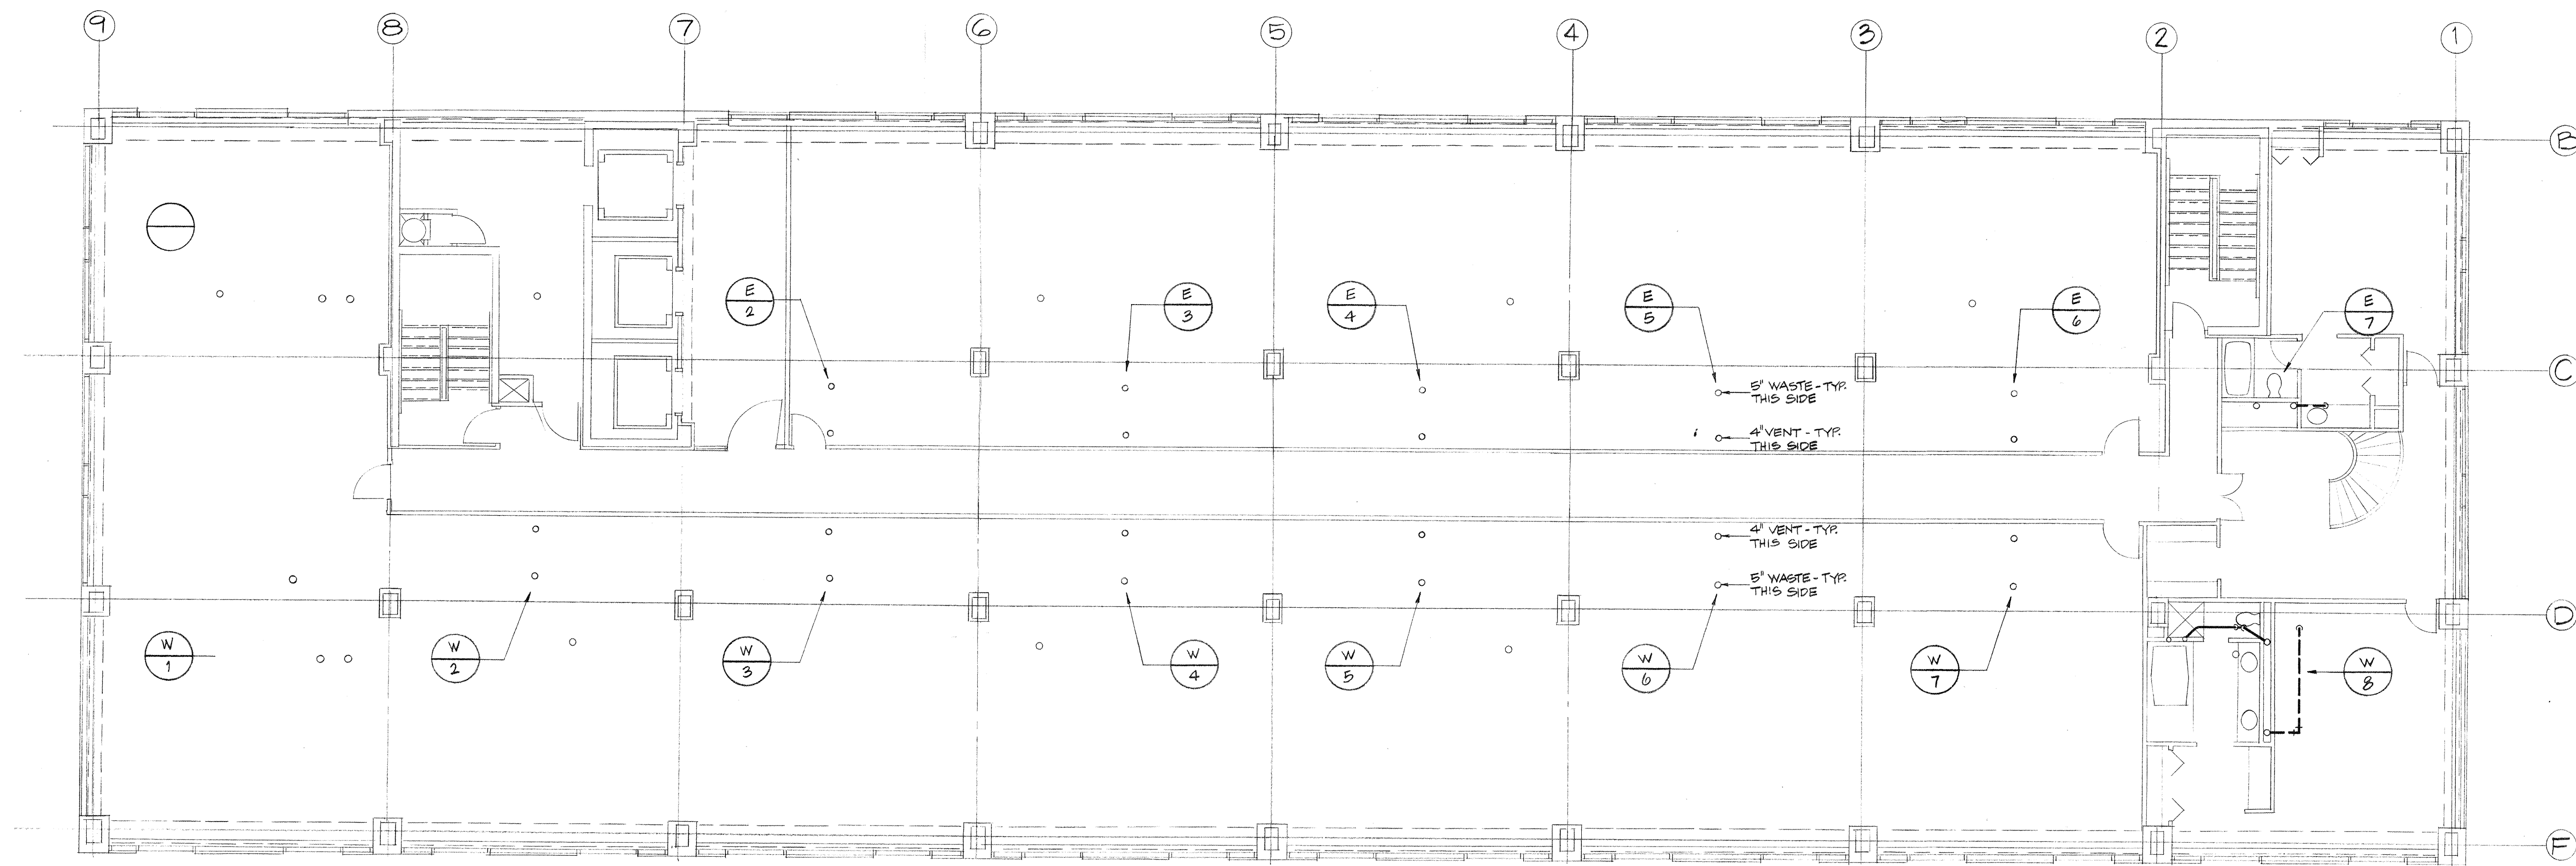

PLUMBING PLAN - 10TH FLOOR - CONDOMINIUMS
SCALE: 1/8" = 1'-0"

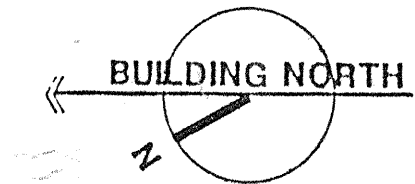


Consulting Engineers
3257 Lochness Drive
Lexington, Kentucky

CARTER - FOSTER INC.

CAPITOL PLAZA HOTEL
FRANKFORT / KENTUCKY

JOHNSON / ROMANOWITZ / ARCHITECTS / LEXINGTON / KENTUCKY
301 EAST VINE STREET, SUITE A
TELEPHONE (502) 252-6761

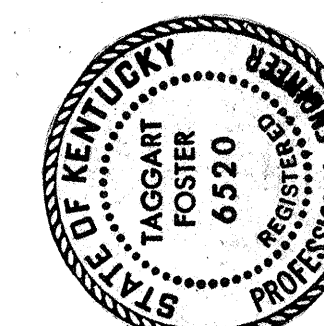

DRAWN: BH
CHECKED: T.F.
PROJECT: DATE: 5-10-83


PLUMBING

PLUMBING PLAN - ROOF
AND MECHANICAL ROOM

REISSUED 8-2-83


DRAWING
P-13

REVISED 7-3-83



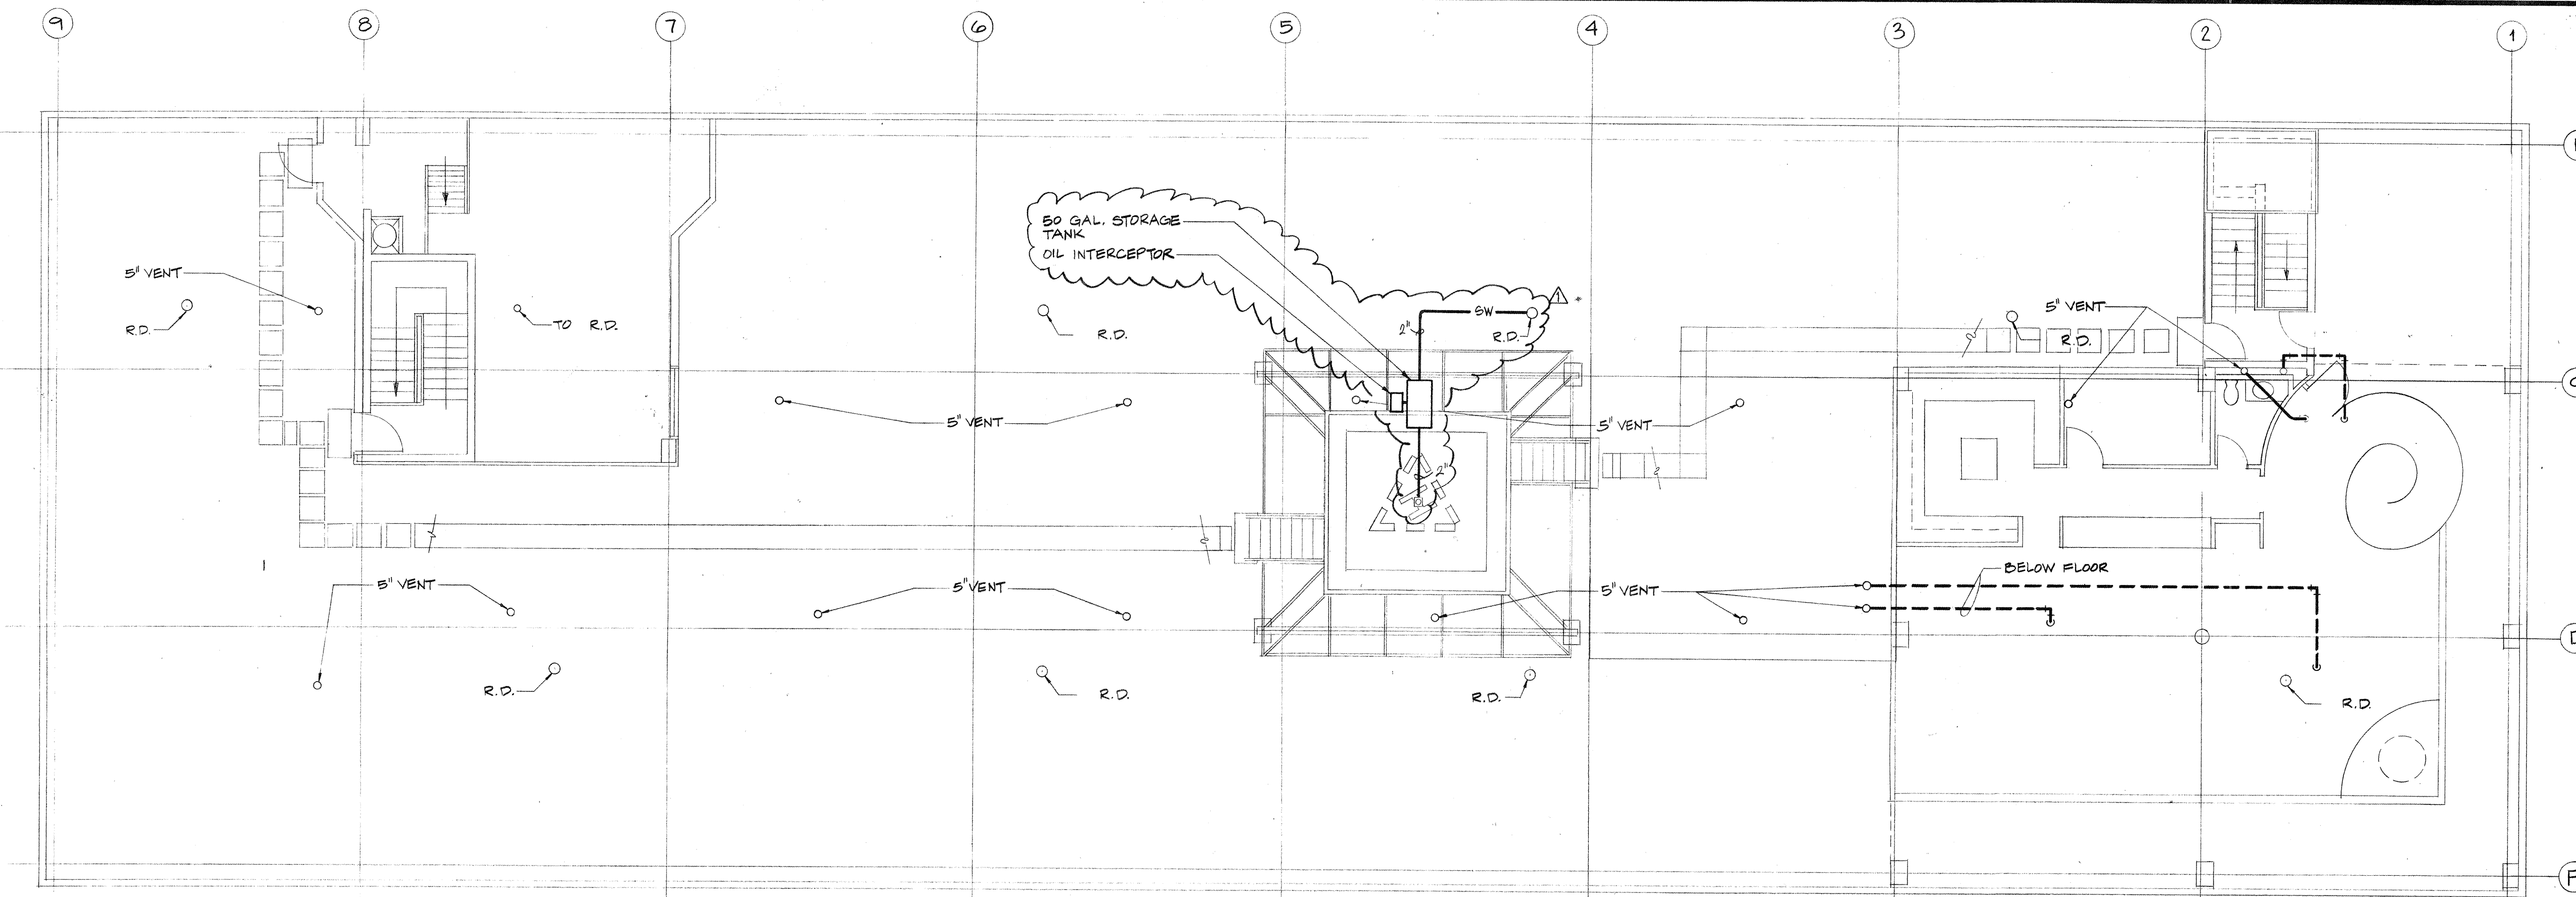


REVISIONS
7-13-83
ADDED SW. PIPING TO HELISTOP


PLUMBING PLAN - ROOF
SCALE: 1/8" = 1' - 0"

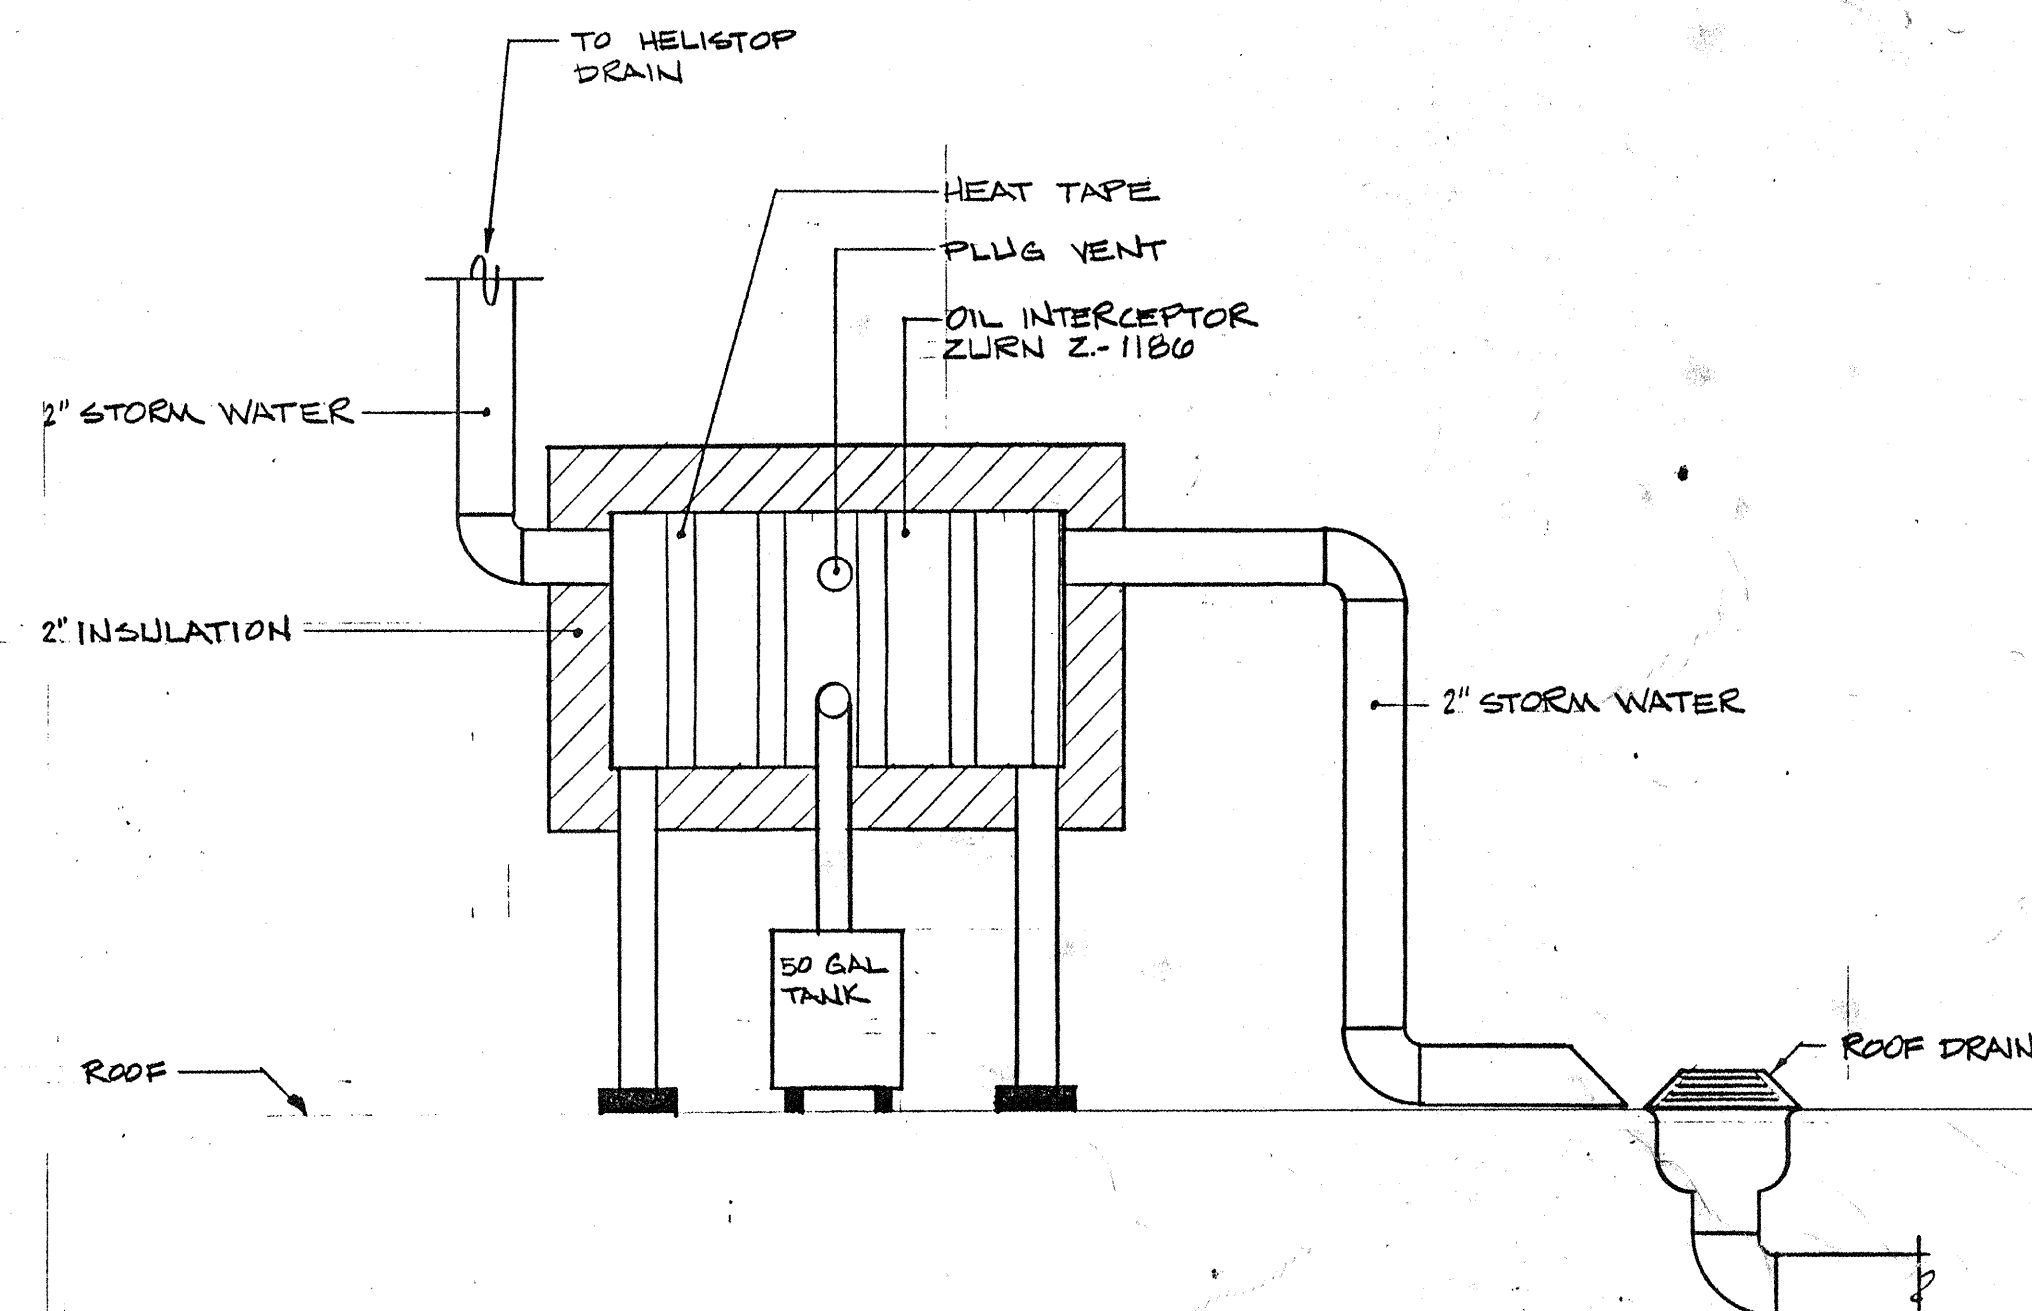


DETAIL HELISTOP STORM WATER & OIL SPILLAGE COLLECTION
NO SCALE

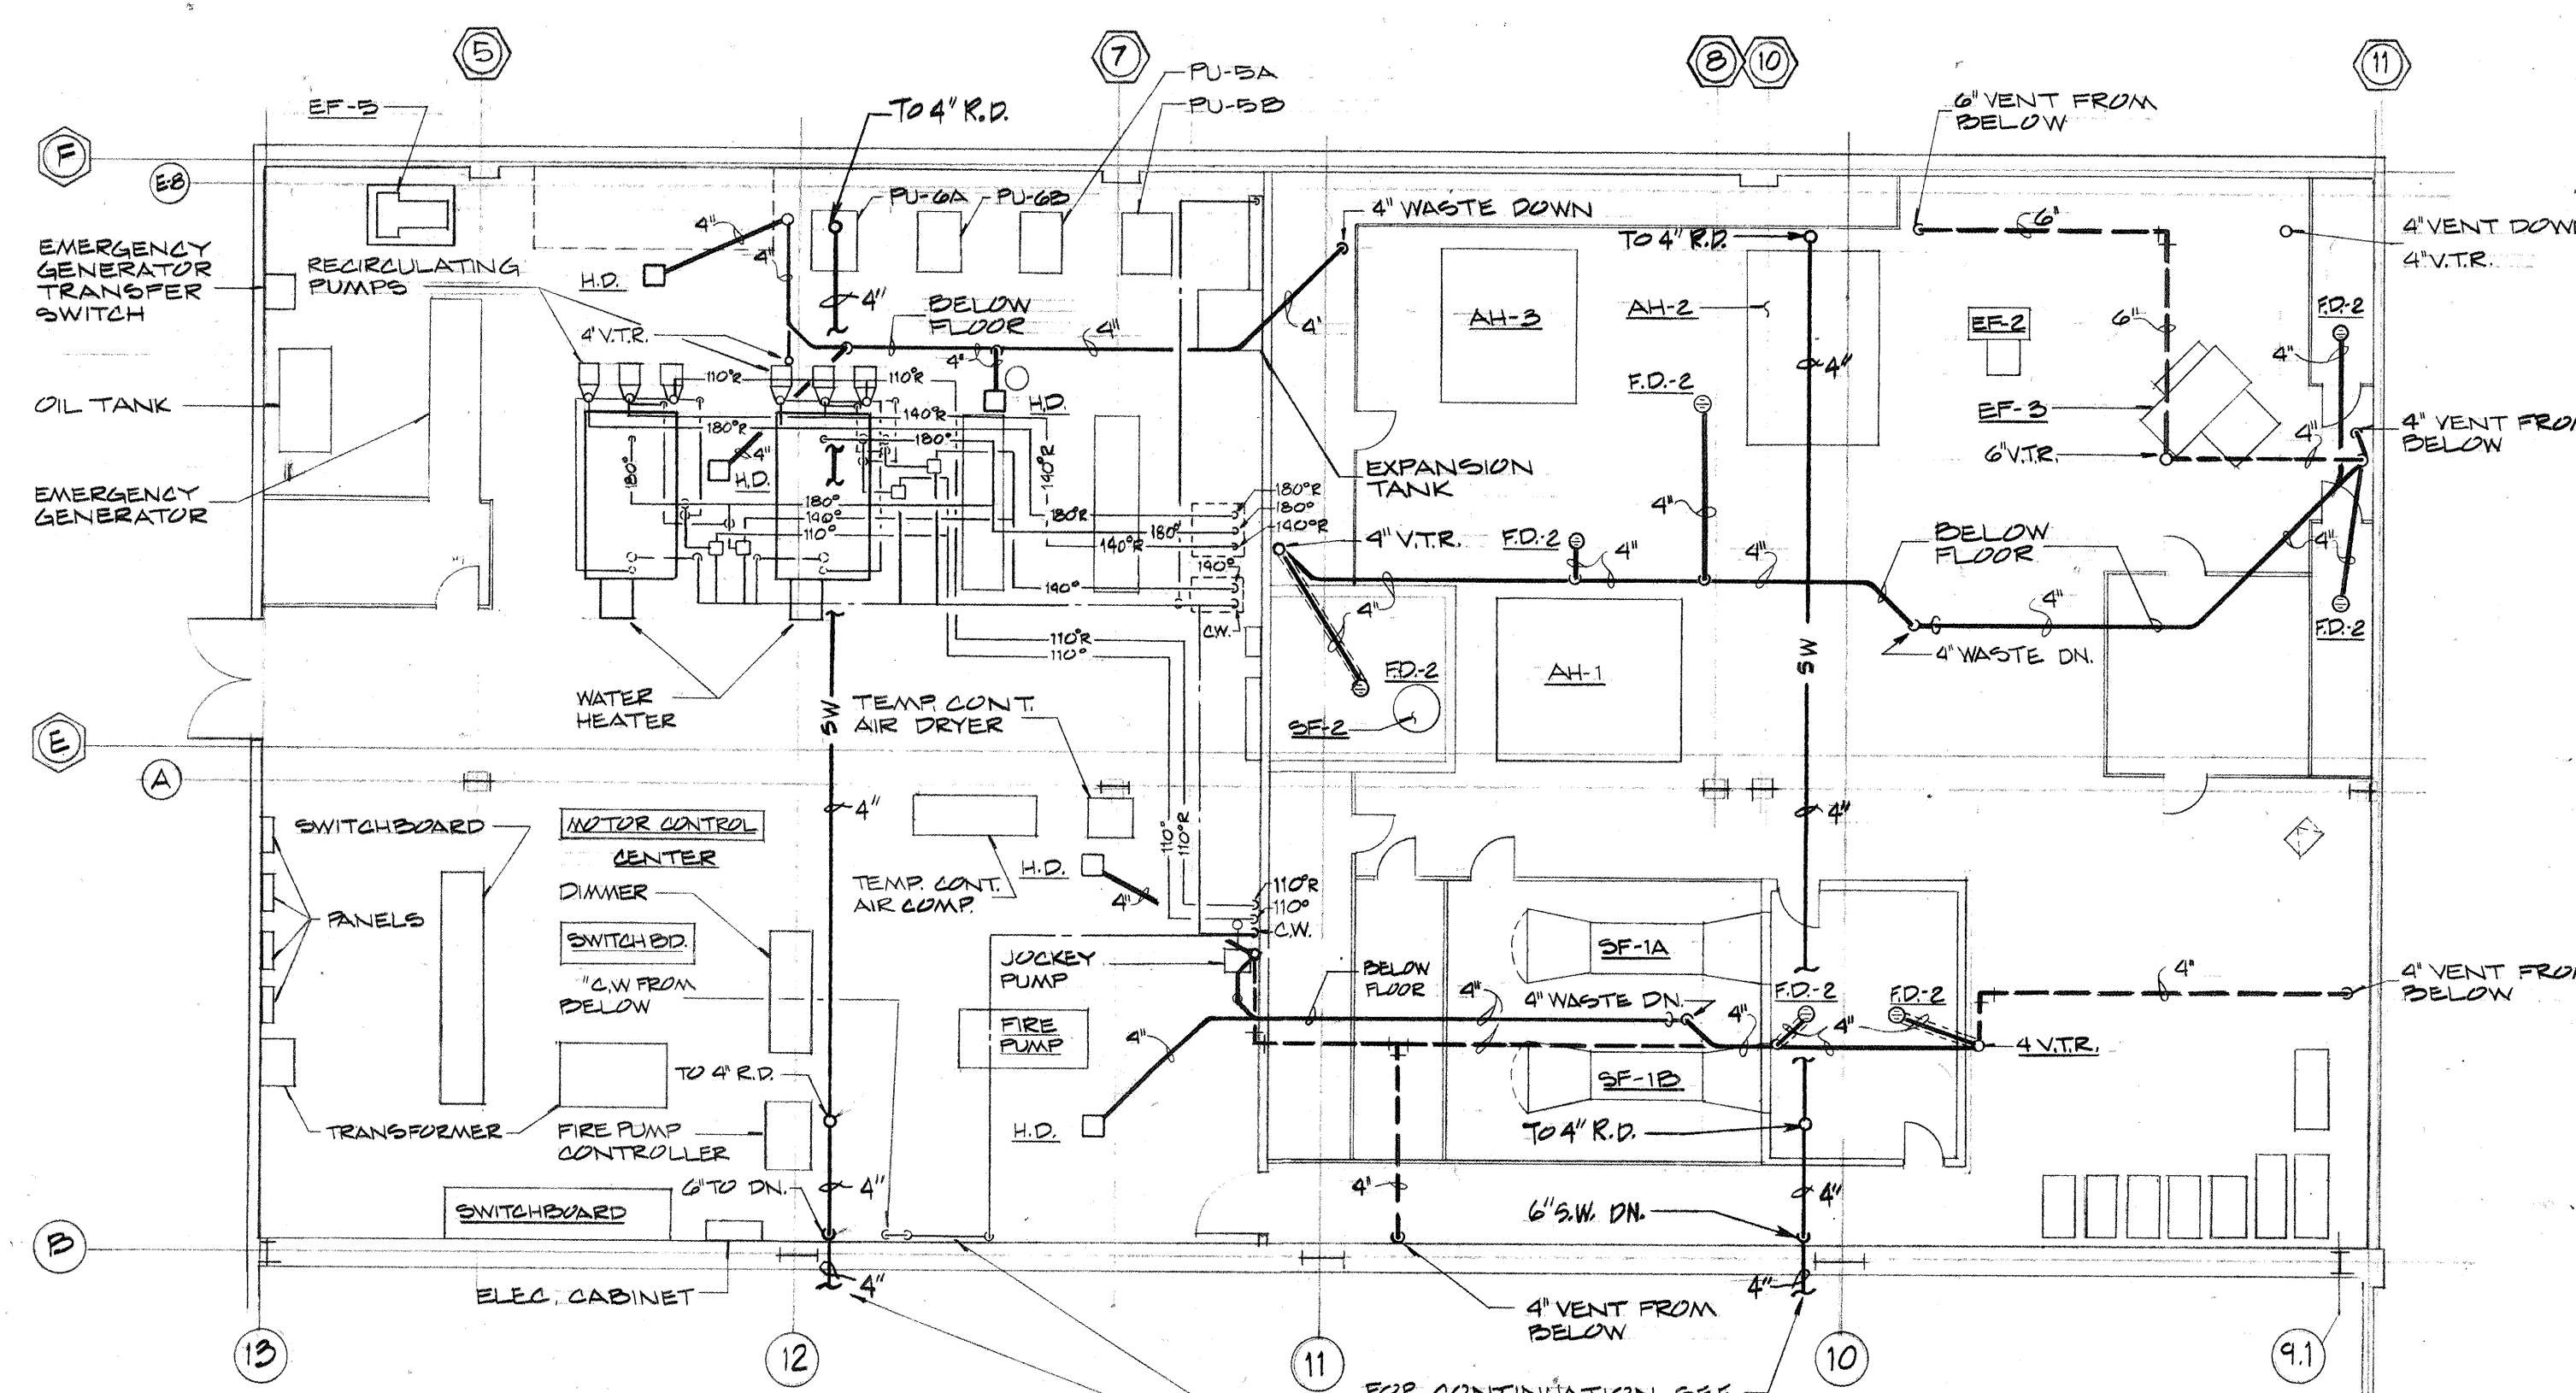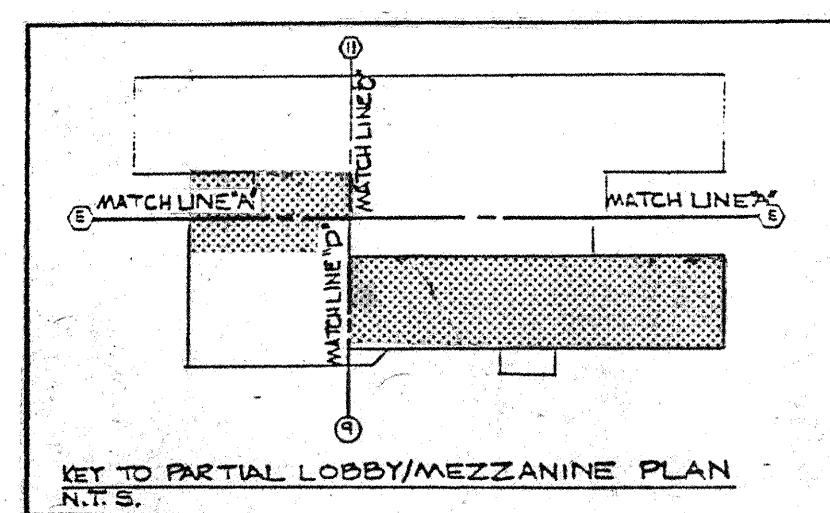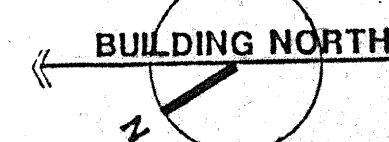


PLUMBING PLAN - MECHANICAL ROOM
SCALE: 1/8" = 1' - 0"

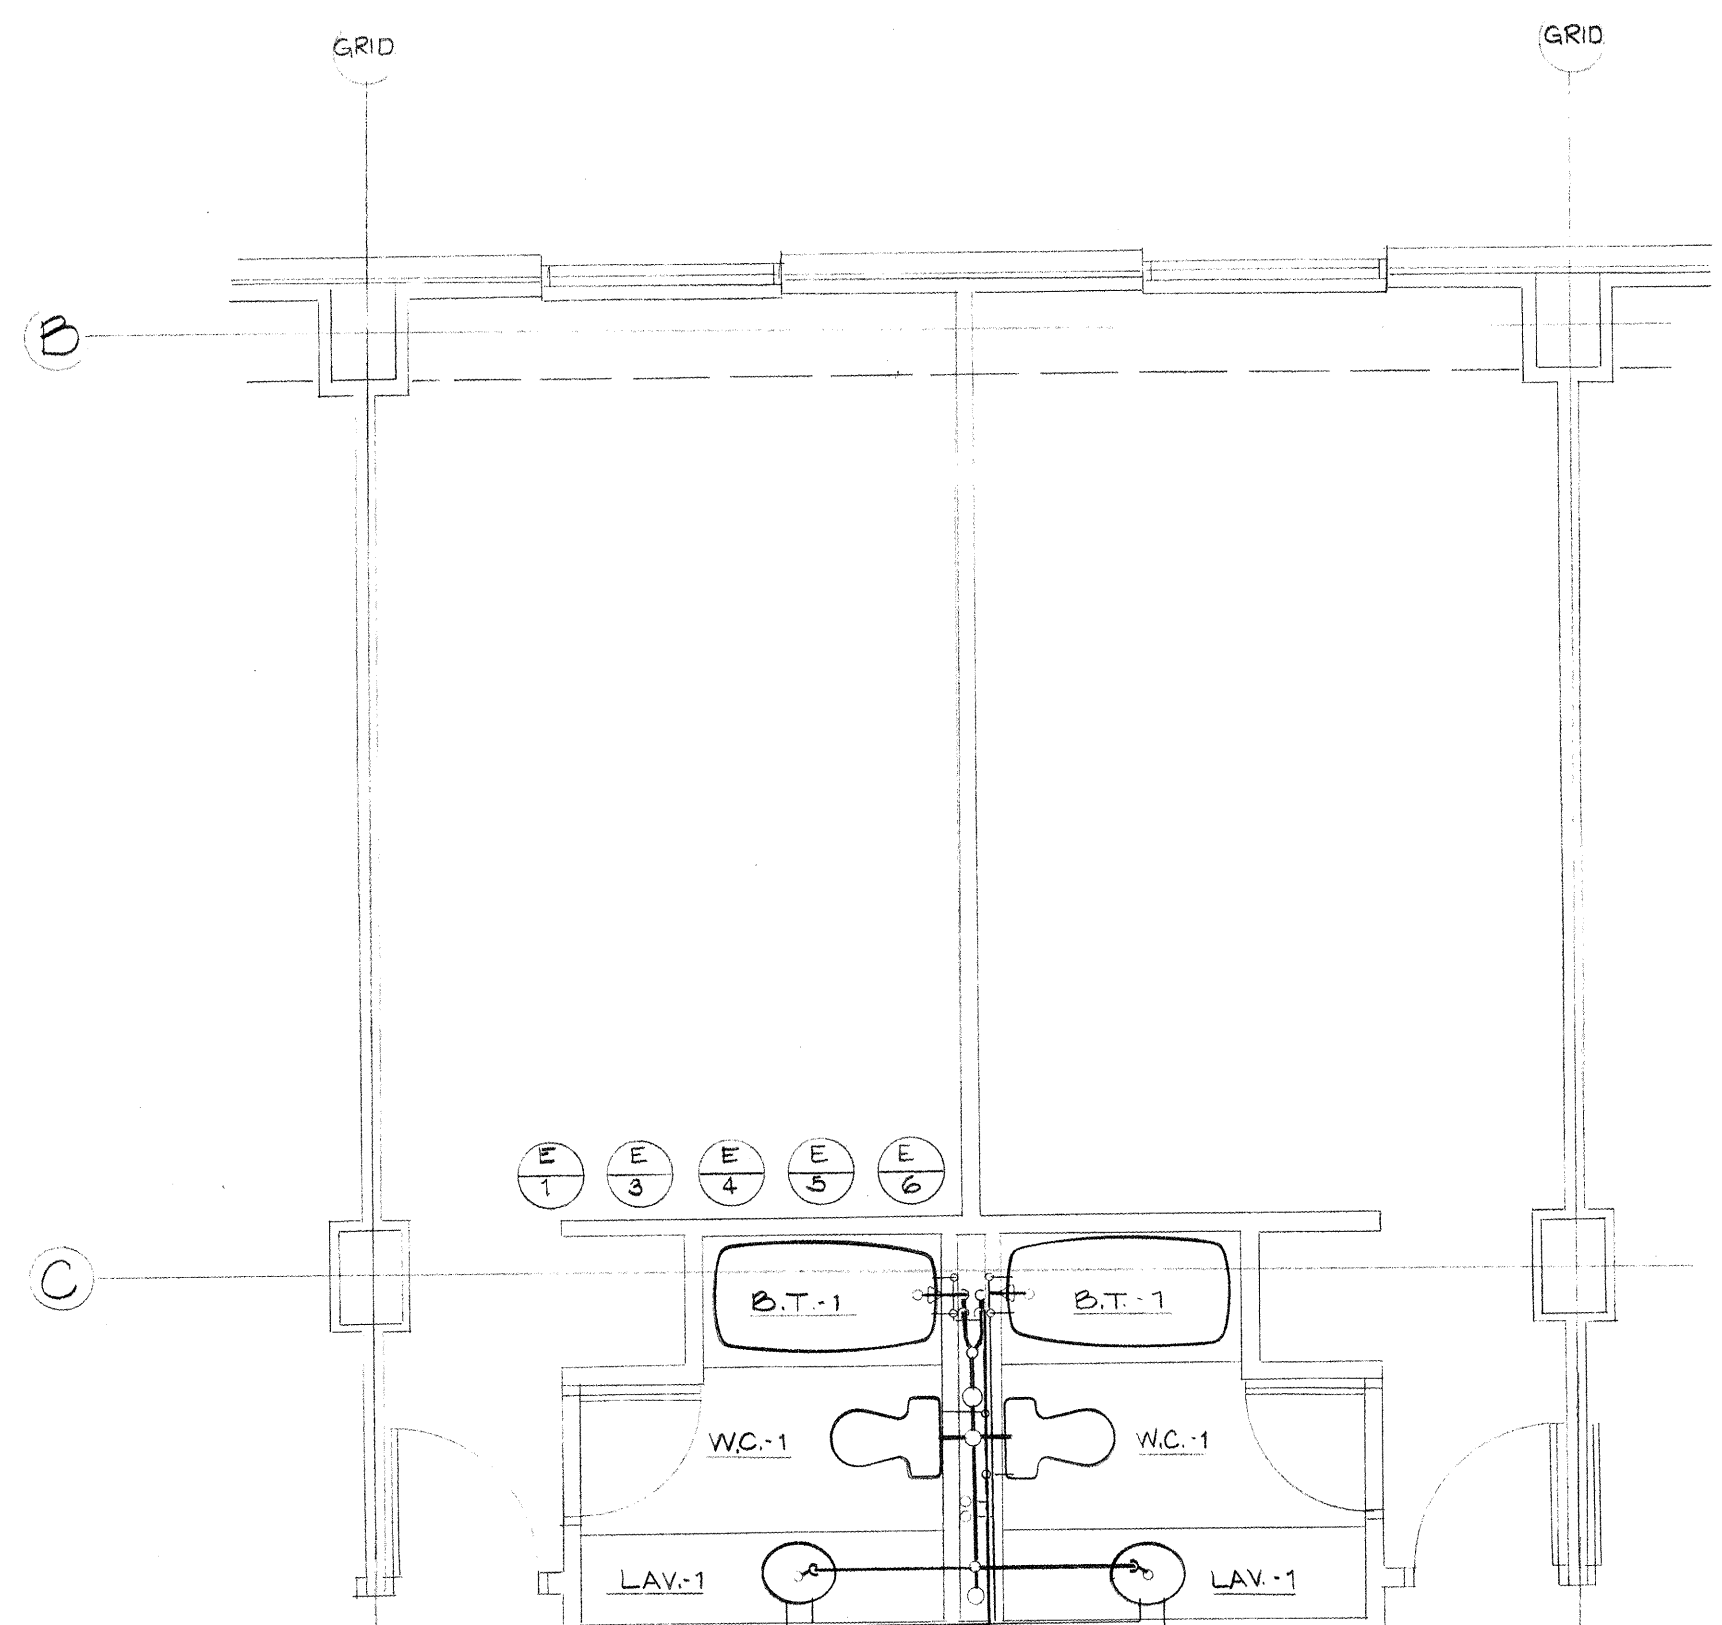


PLUMBING PLAN - TYPICAL GUEST ROOM
SCALE: 1/4" = 1'-0"

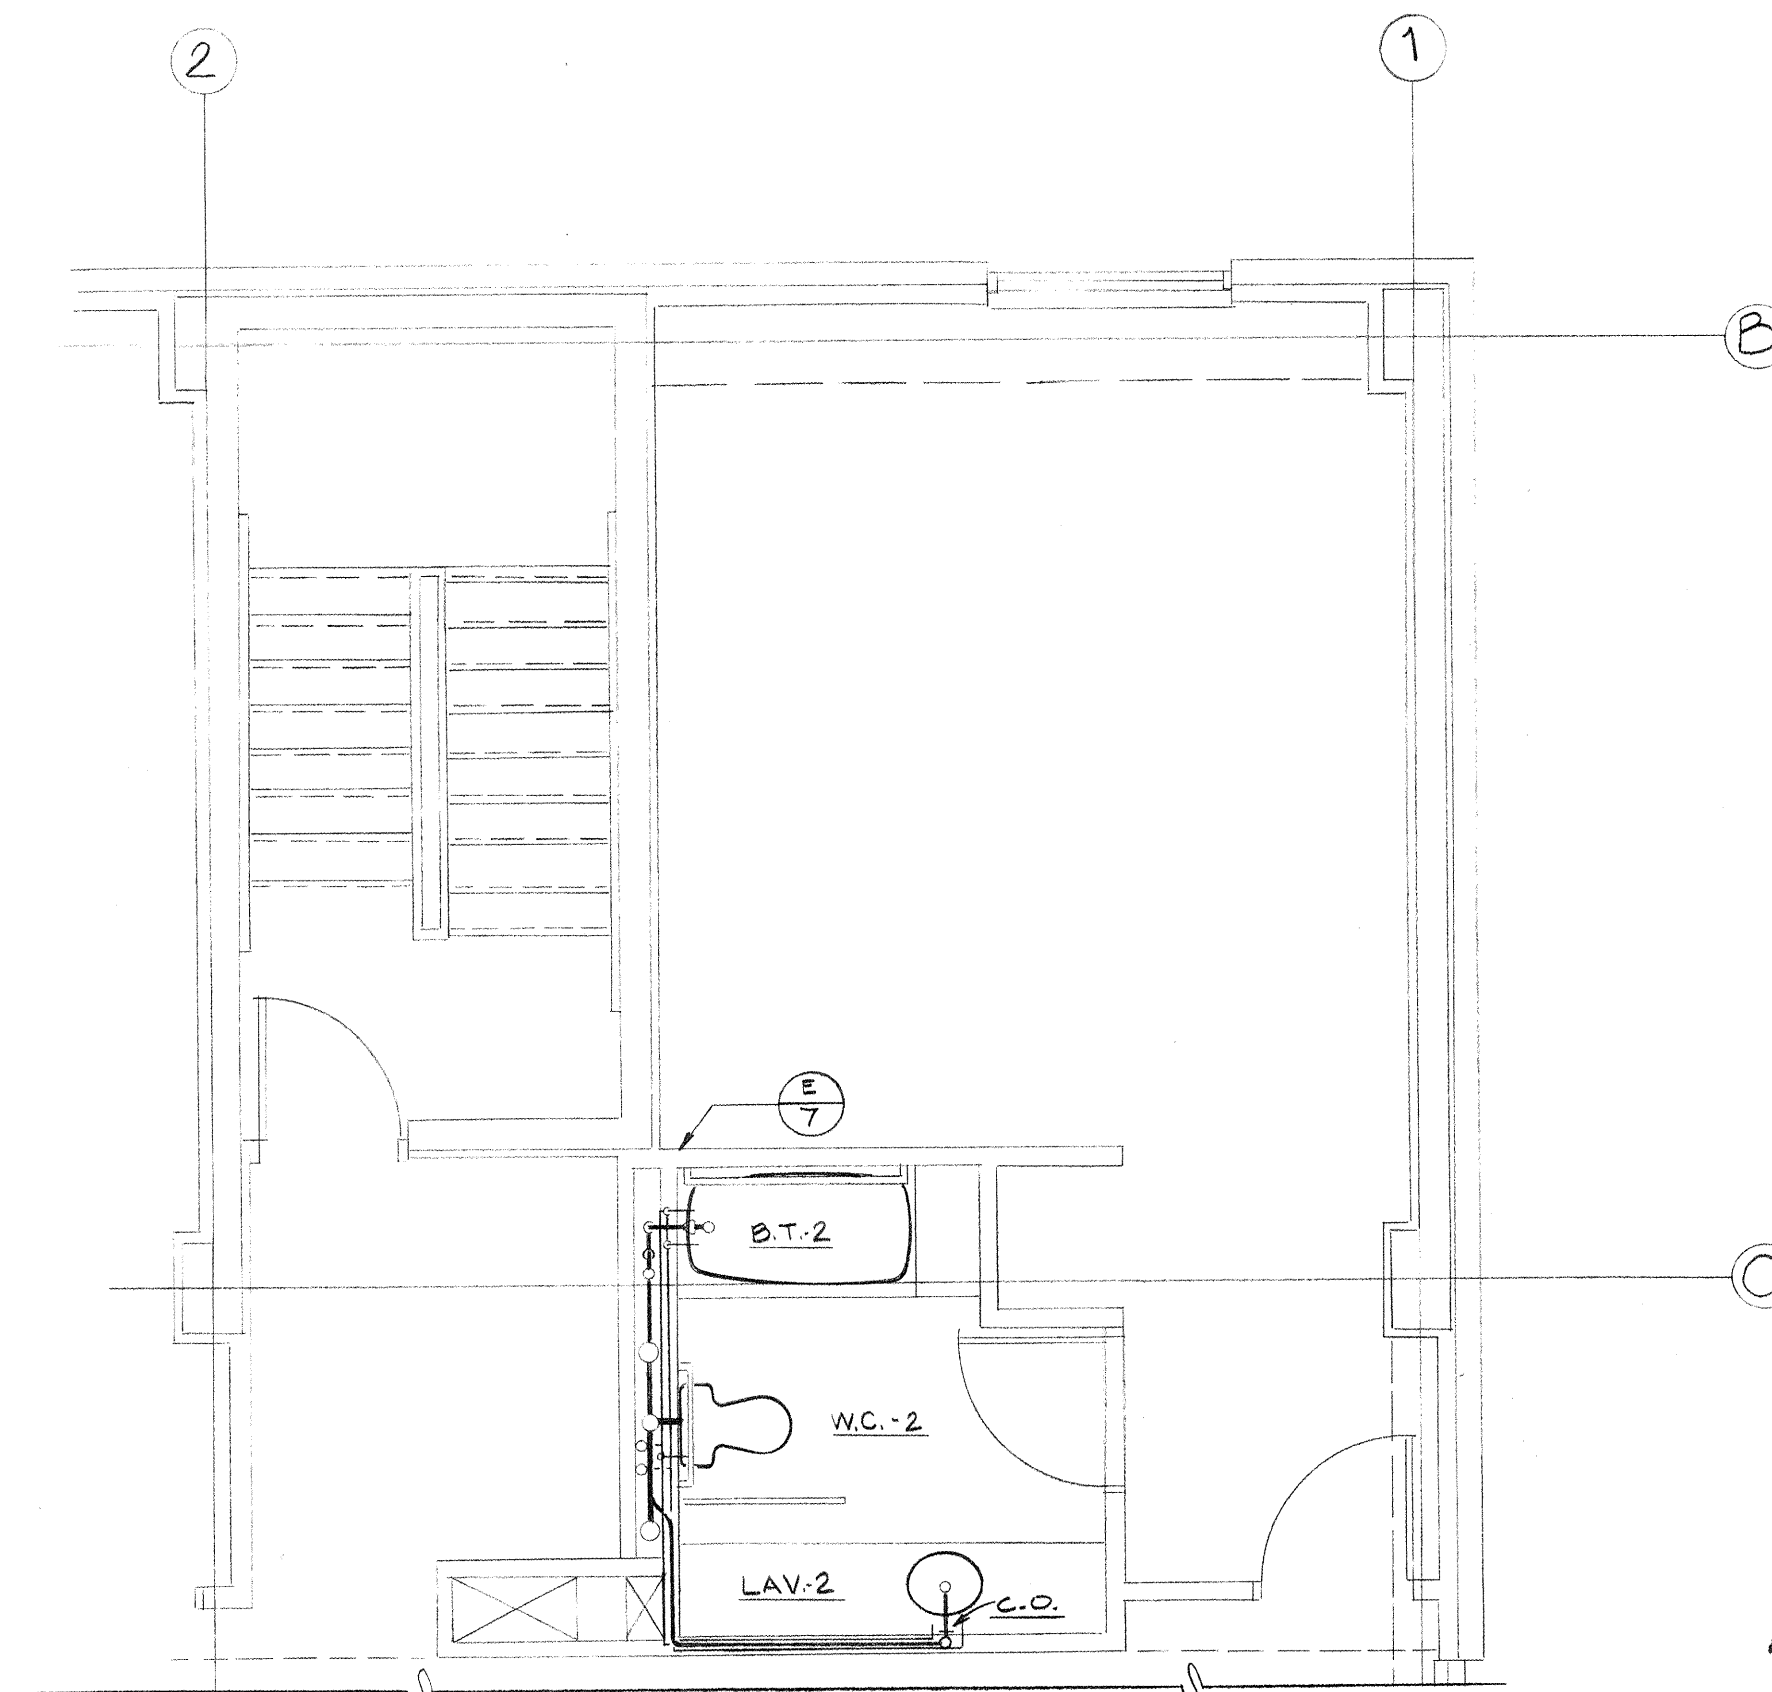


PLUMBING PLAN - TYPICAL HANDICAPPED GUEST ROOM
SCALE: 1/4" = 1'-0"

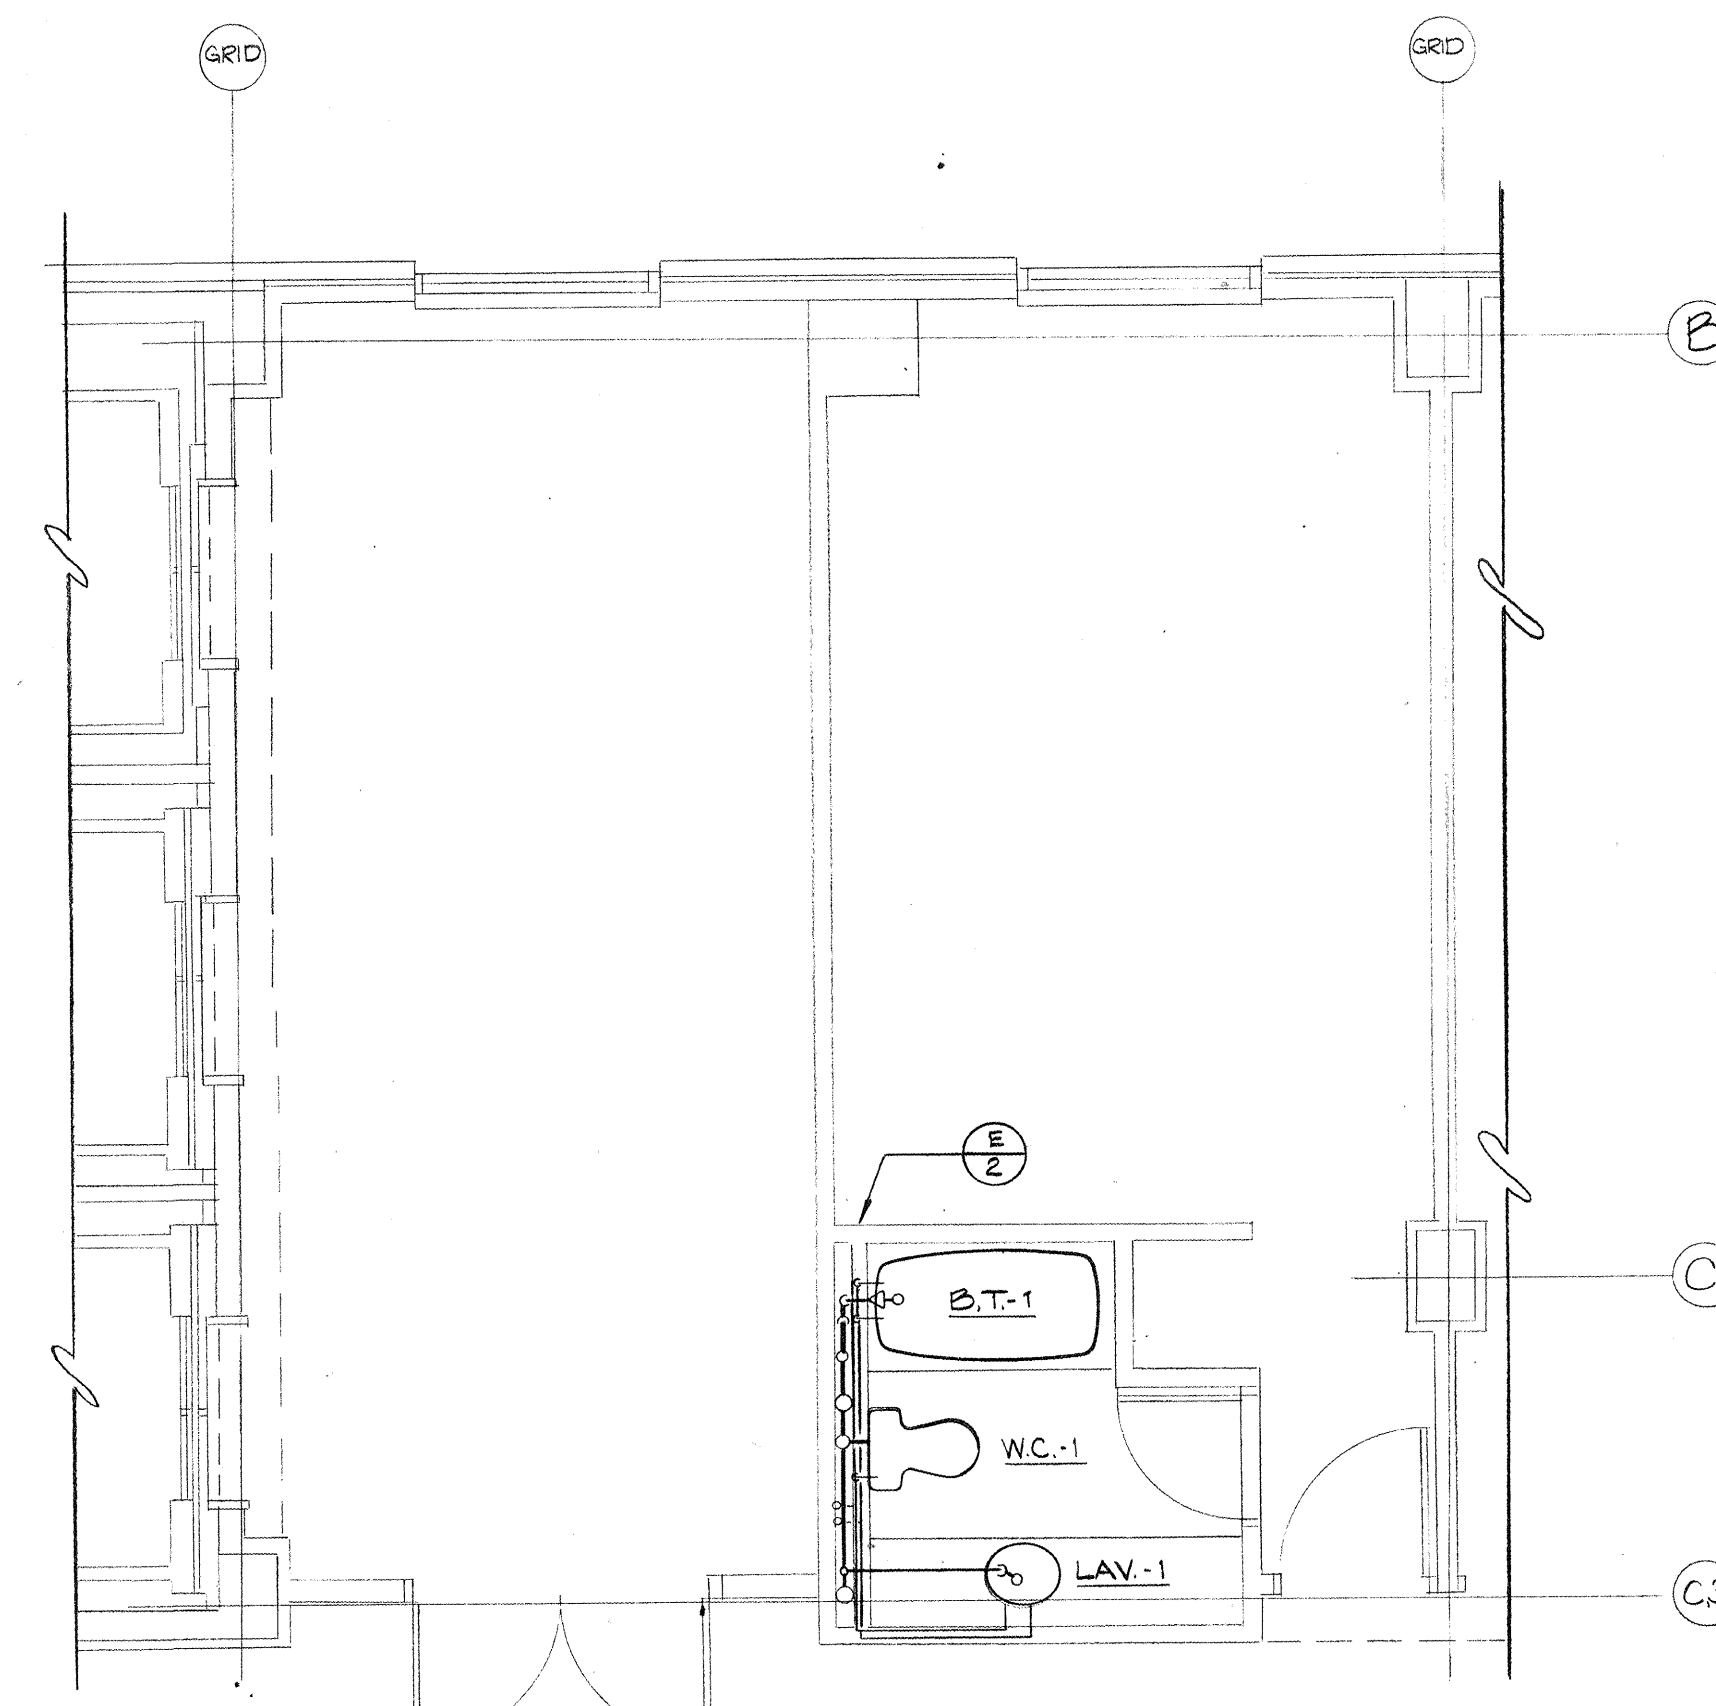


PLUMBING PLAN - TYPICAL ROOM STACK
SCALE: 1/4" = 1'-0"

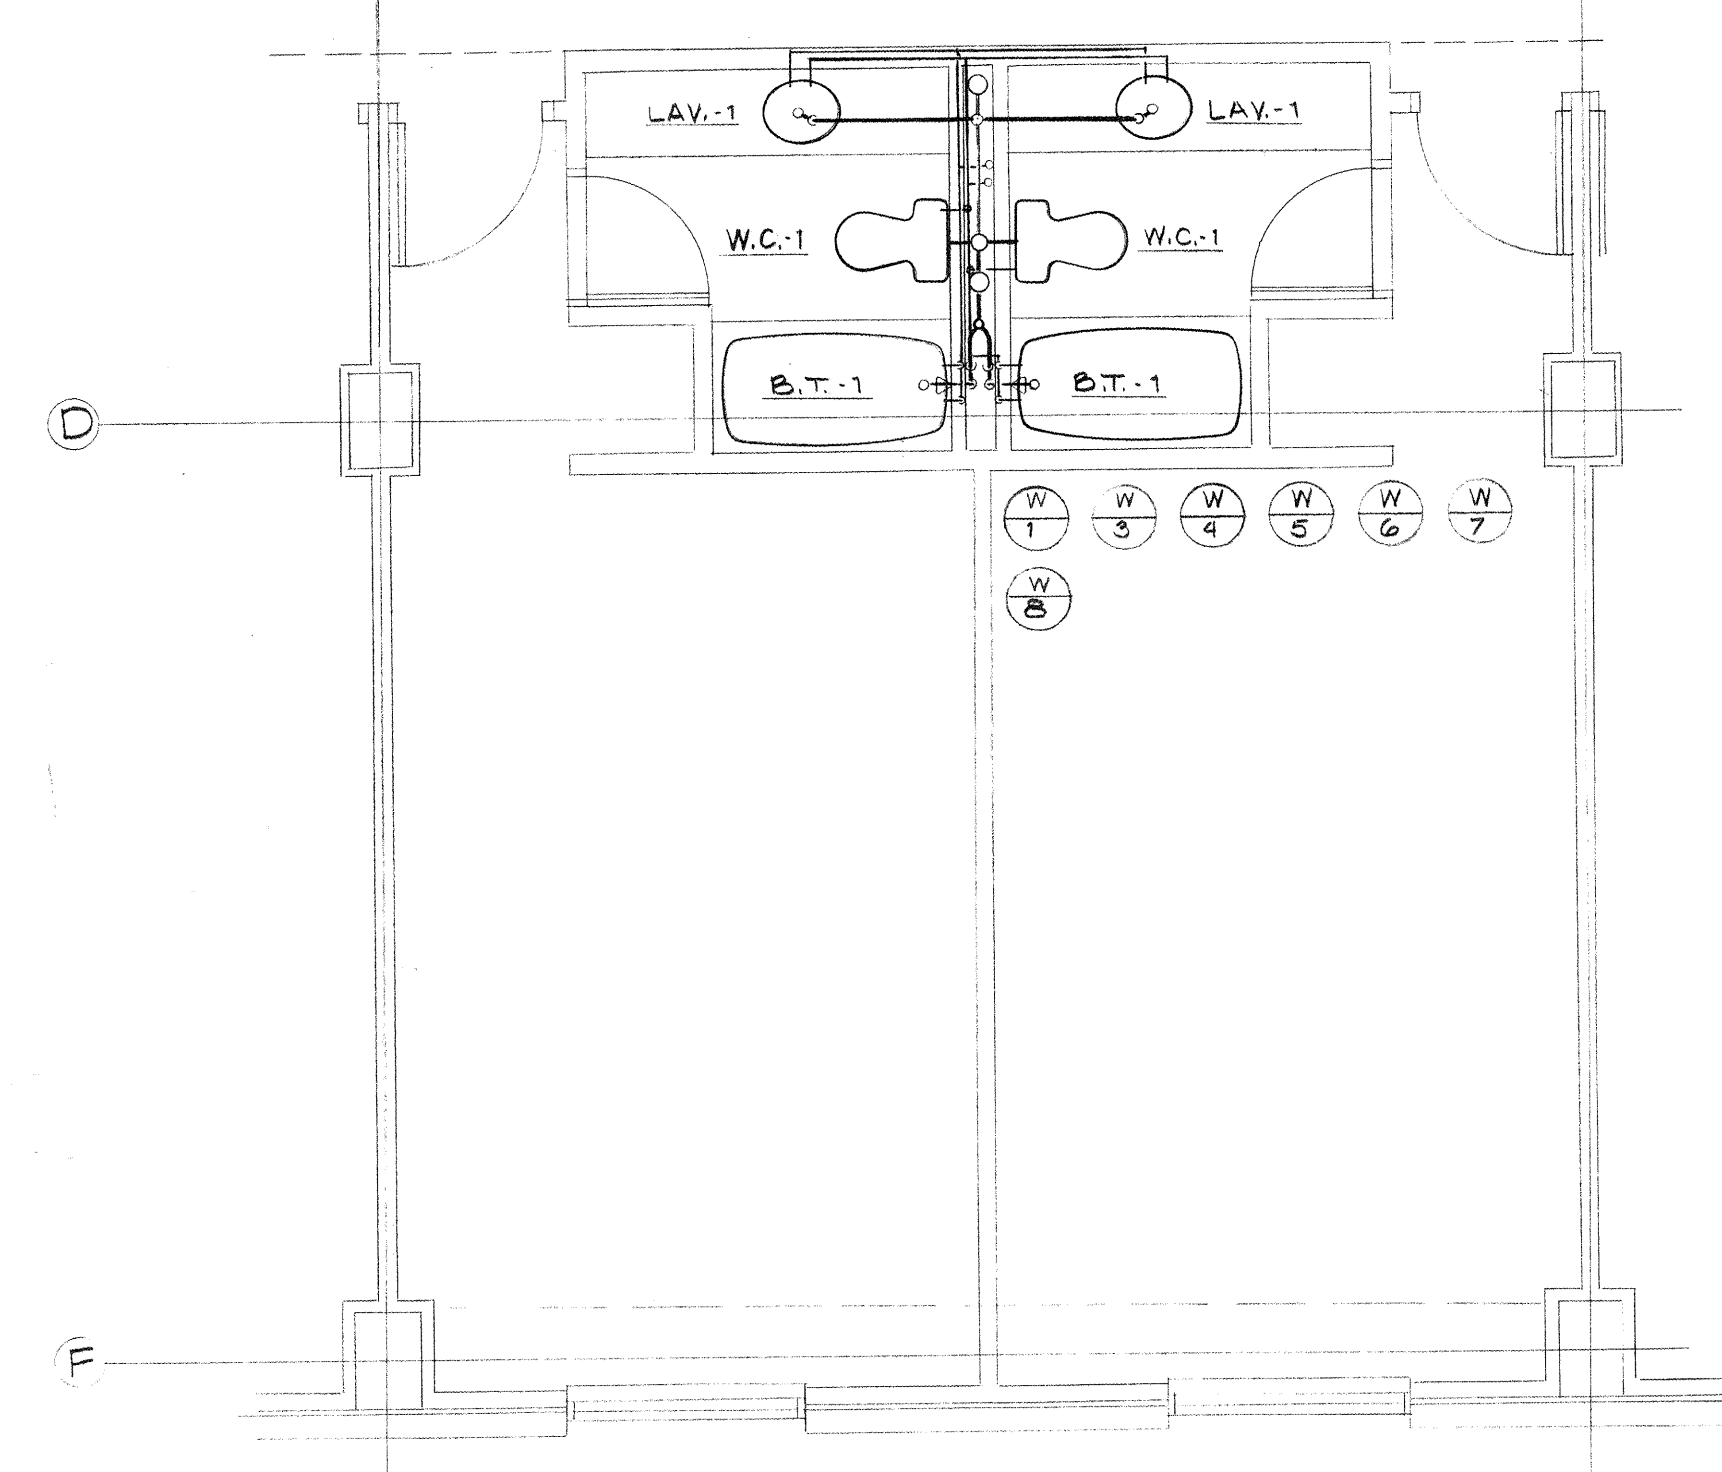

PLUMBING PLAN - TYPICAL GUEST ROOM
SCALE: 1/4" = 1'-0"

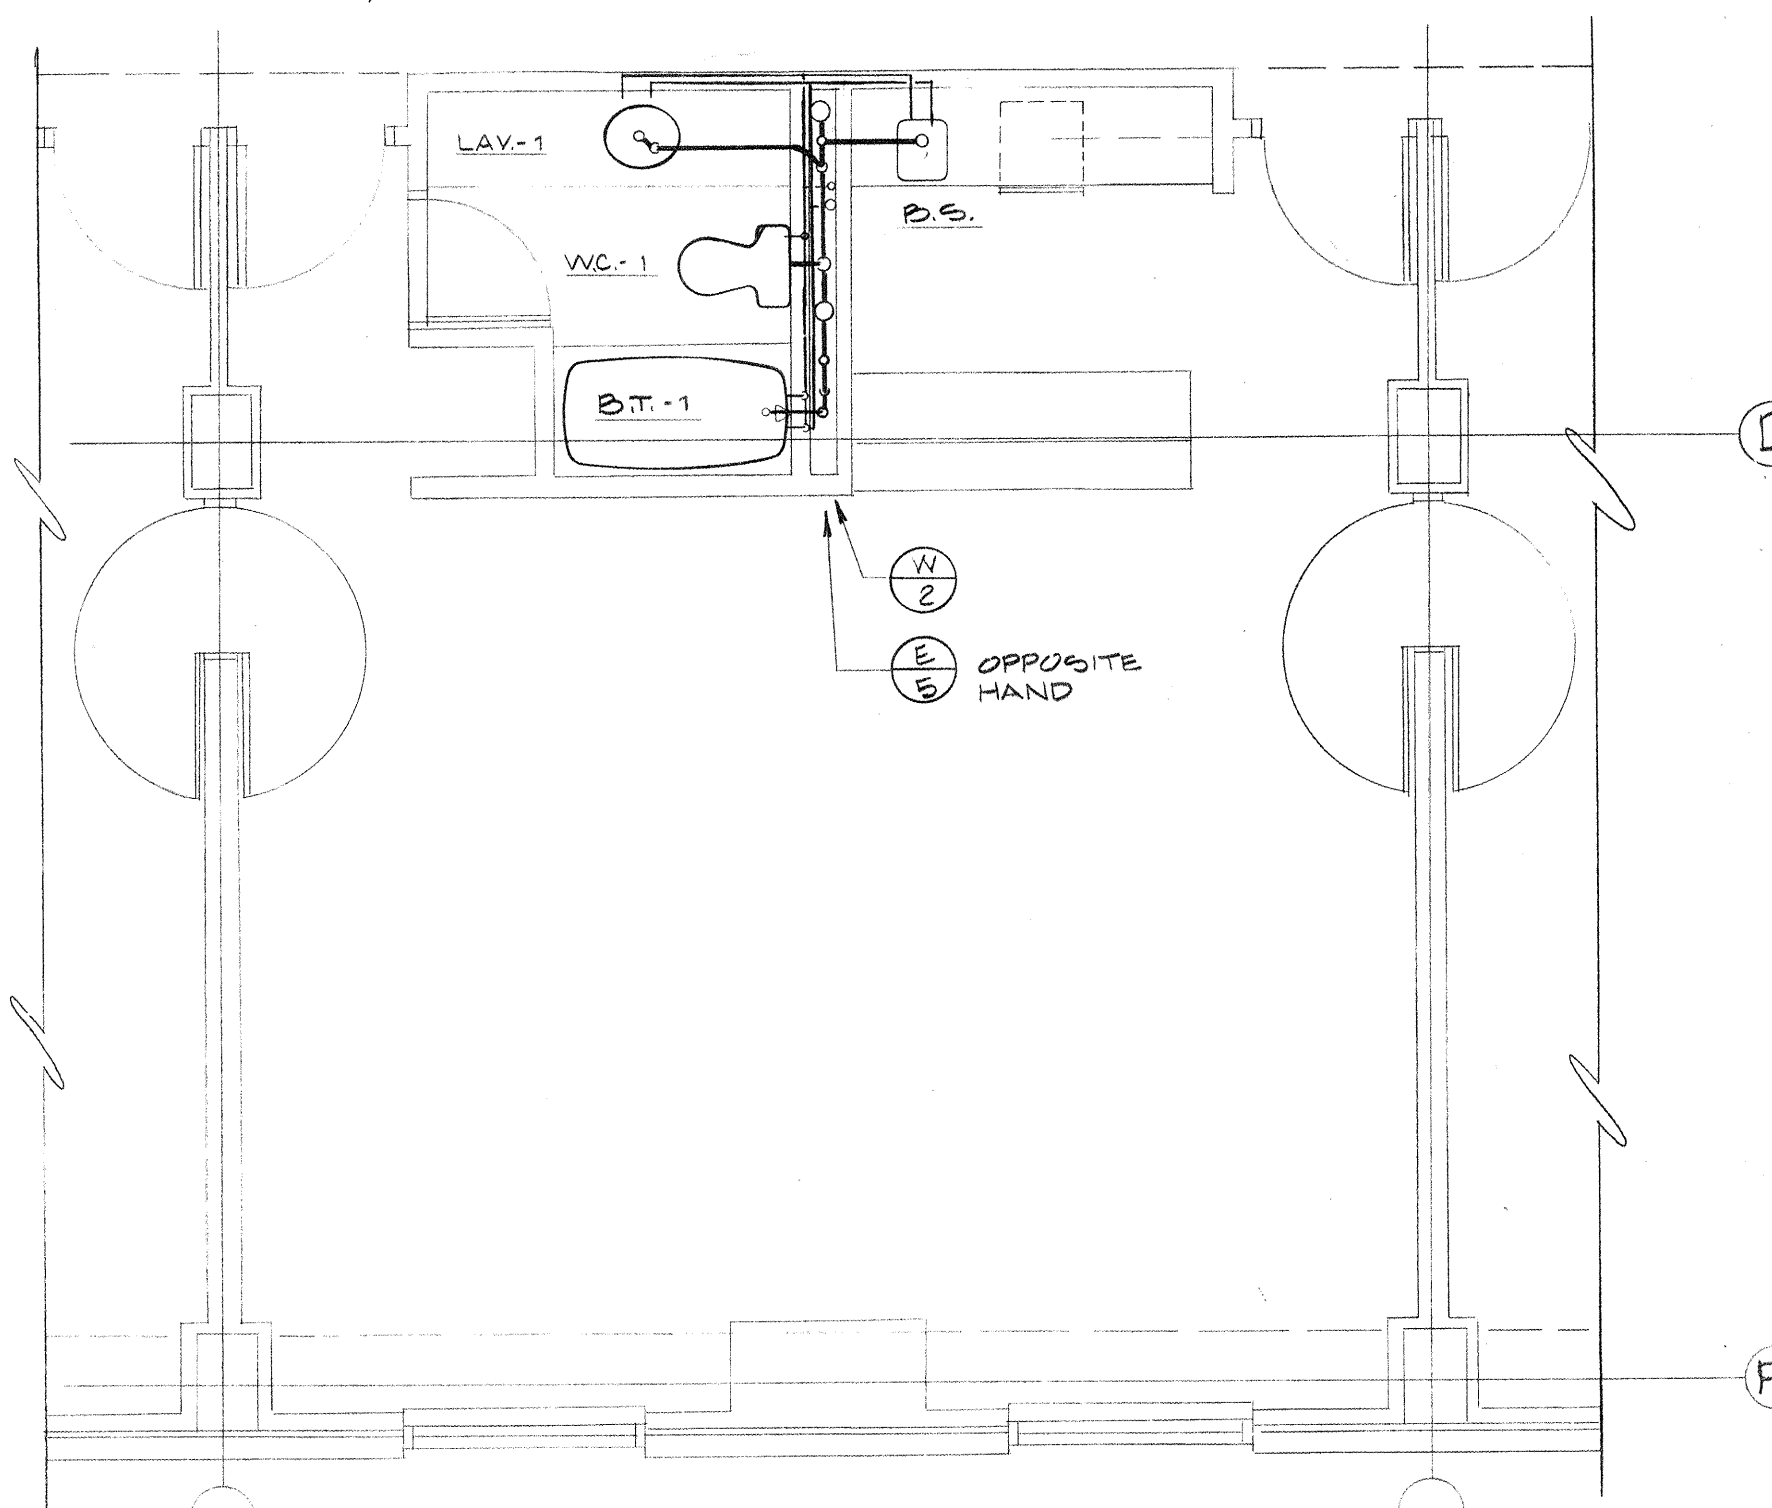

PLUMBING PLAN - 4-BAY SUITE
SCALE: 1/4" = 1'-0"

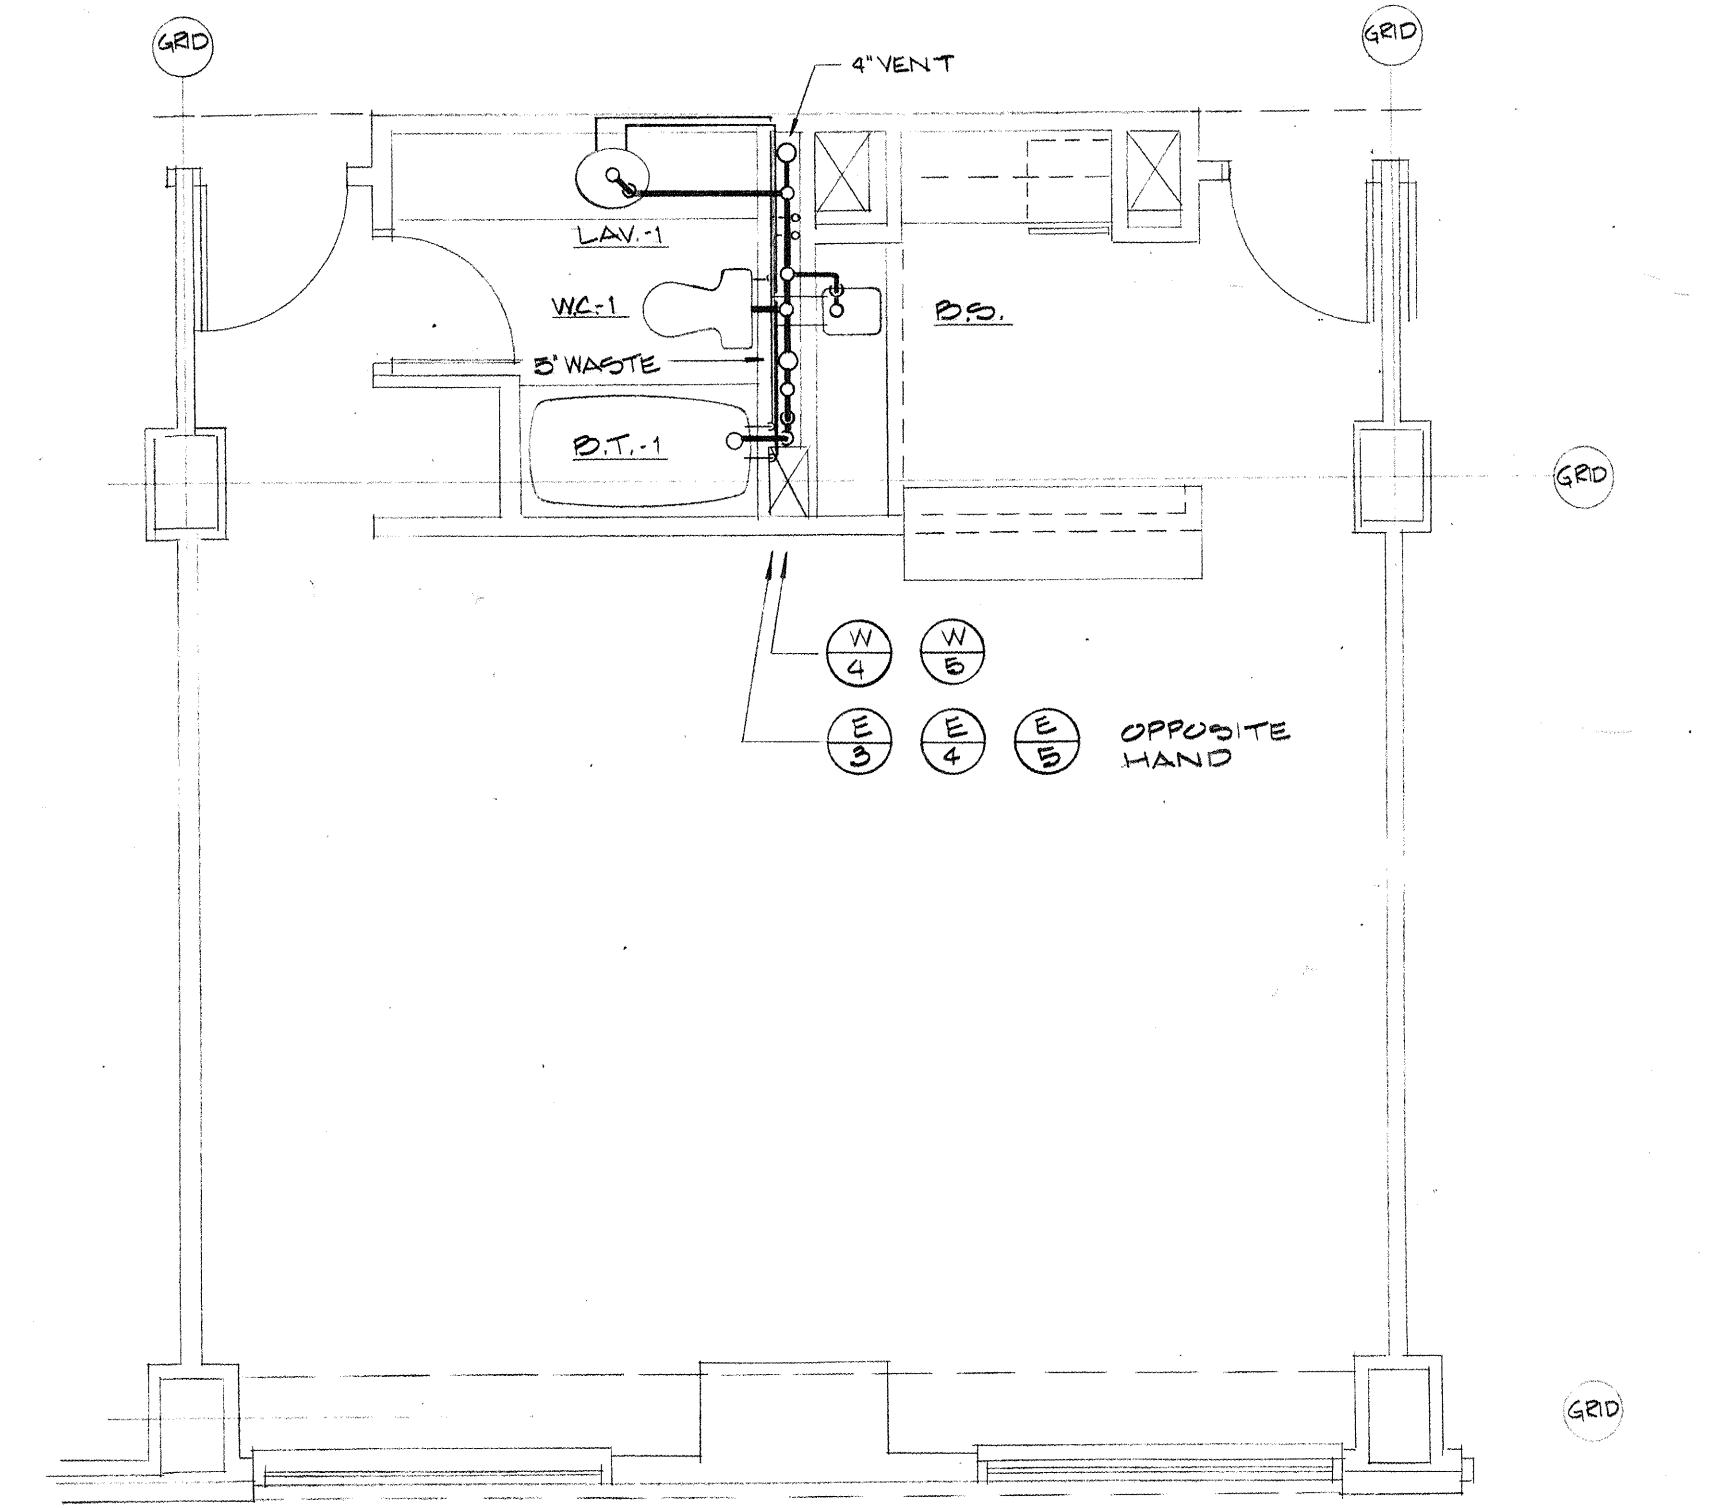




PLUMBING PLAN - 2 BAY SUITE
SCALE: 1/4" = 1'-0"

ENLARGED PLUMBING PLANS - GUEST ROOMS
SCALE: 1/4" = 1'-0"

Consulting Engineers
3257 Lochness Drive
Lexington, Kentucky


CARTER - FOSTER INC.

CAPITOL PLAZA HOTEL
FRANKFORT / KENTUCKY

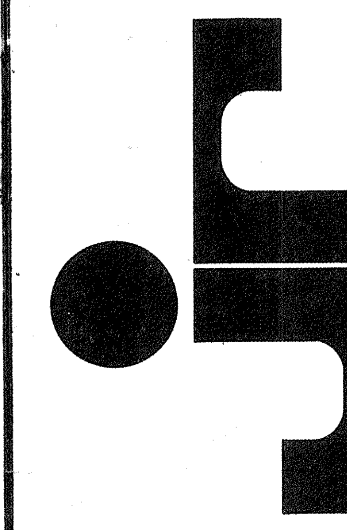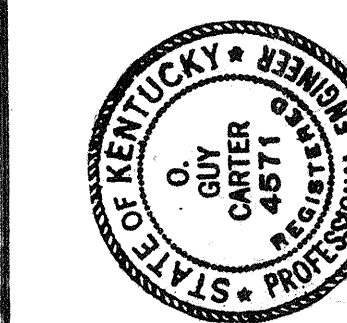
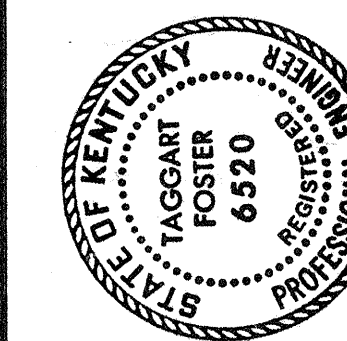


JOHNSON / ROMANOWITZ / ARCHITECTS / LEXINGTON / KENTUCKY
301 EAST VINE STREET, SUITE A
LEXINGTON, KENTUCKY 40501-252-6781

DRAWN B.H.	PROJECT
CHECKED	DATE 5-10-83
PLUMBING	
ENLARGED PLUMBING PLANS GUEST ROOMS	
DRAWING P-14	

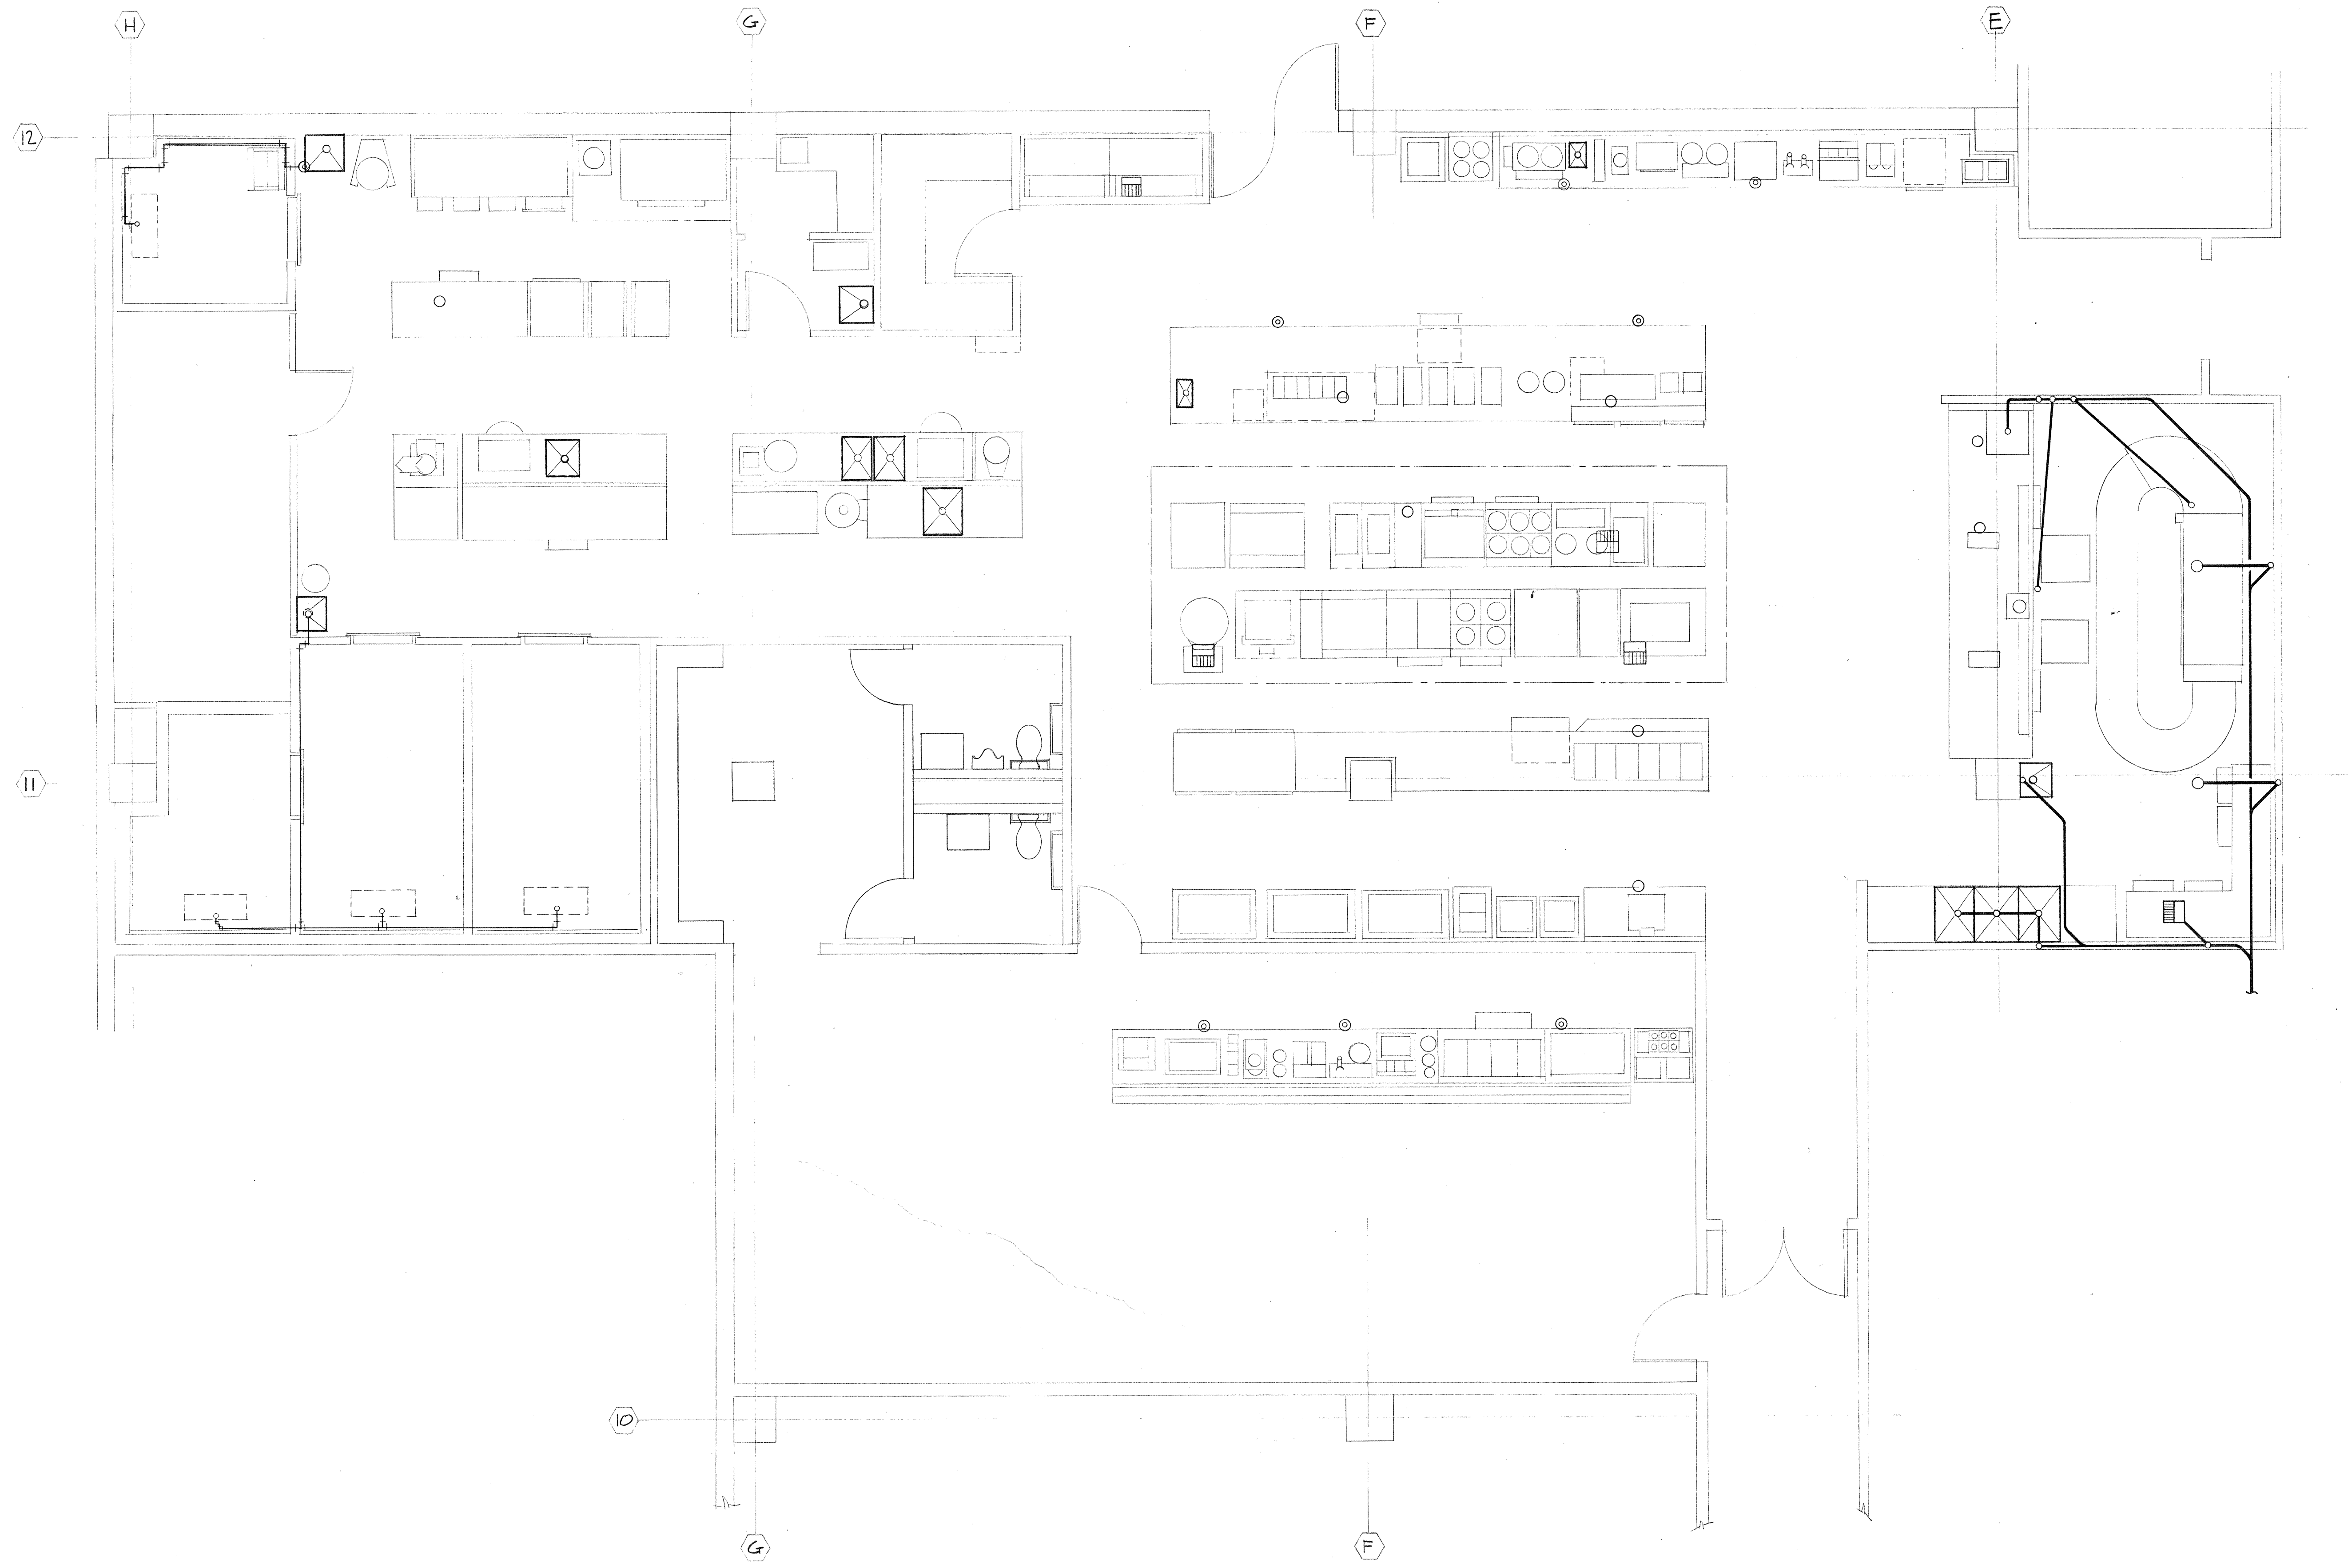

ENLARGED PLUMBING PLAN - KITCHEN
SCALE: 1/4" = 1'-0"

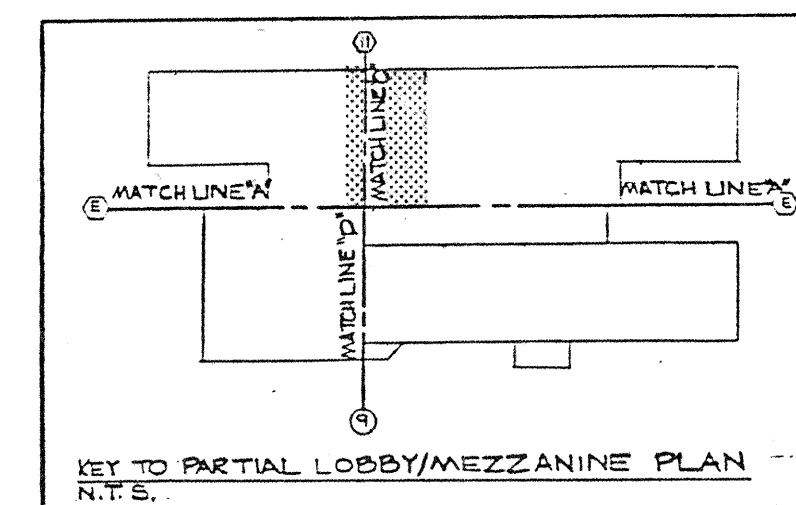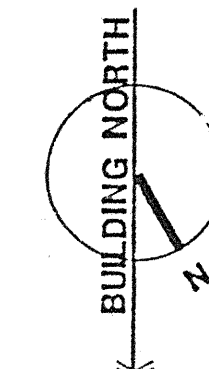







CARTER - FOSTER INC. Consulting Engineers 3257 Lochness Drive Lexington, Kentucky	CAPITOL PLAZA HOTEL FRANKFORT / KENTUCKY

JOHNSON / ROMANOWITZ ARCHITECTS / KENTUCKY
 301 EAST VINE STREET, SUITE A
 TELEPHONE (606) 252-6781

STATE OF KENTUCKY
 GUY CARTER
 4571
 REGISTERED PROFESSIONAL

STATE OF KENTUCKY
 CARTER FOSTER
 6920
 REGISTERED PROFESSIONAL

DRAWN BH	PROJECT
CHECKED	DATE 5-10-83
PLUMBING	
ENLARGED PLUMBING PLAN - KITCHEN	
DRAWING P-15	

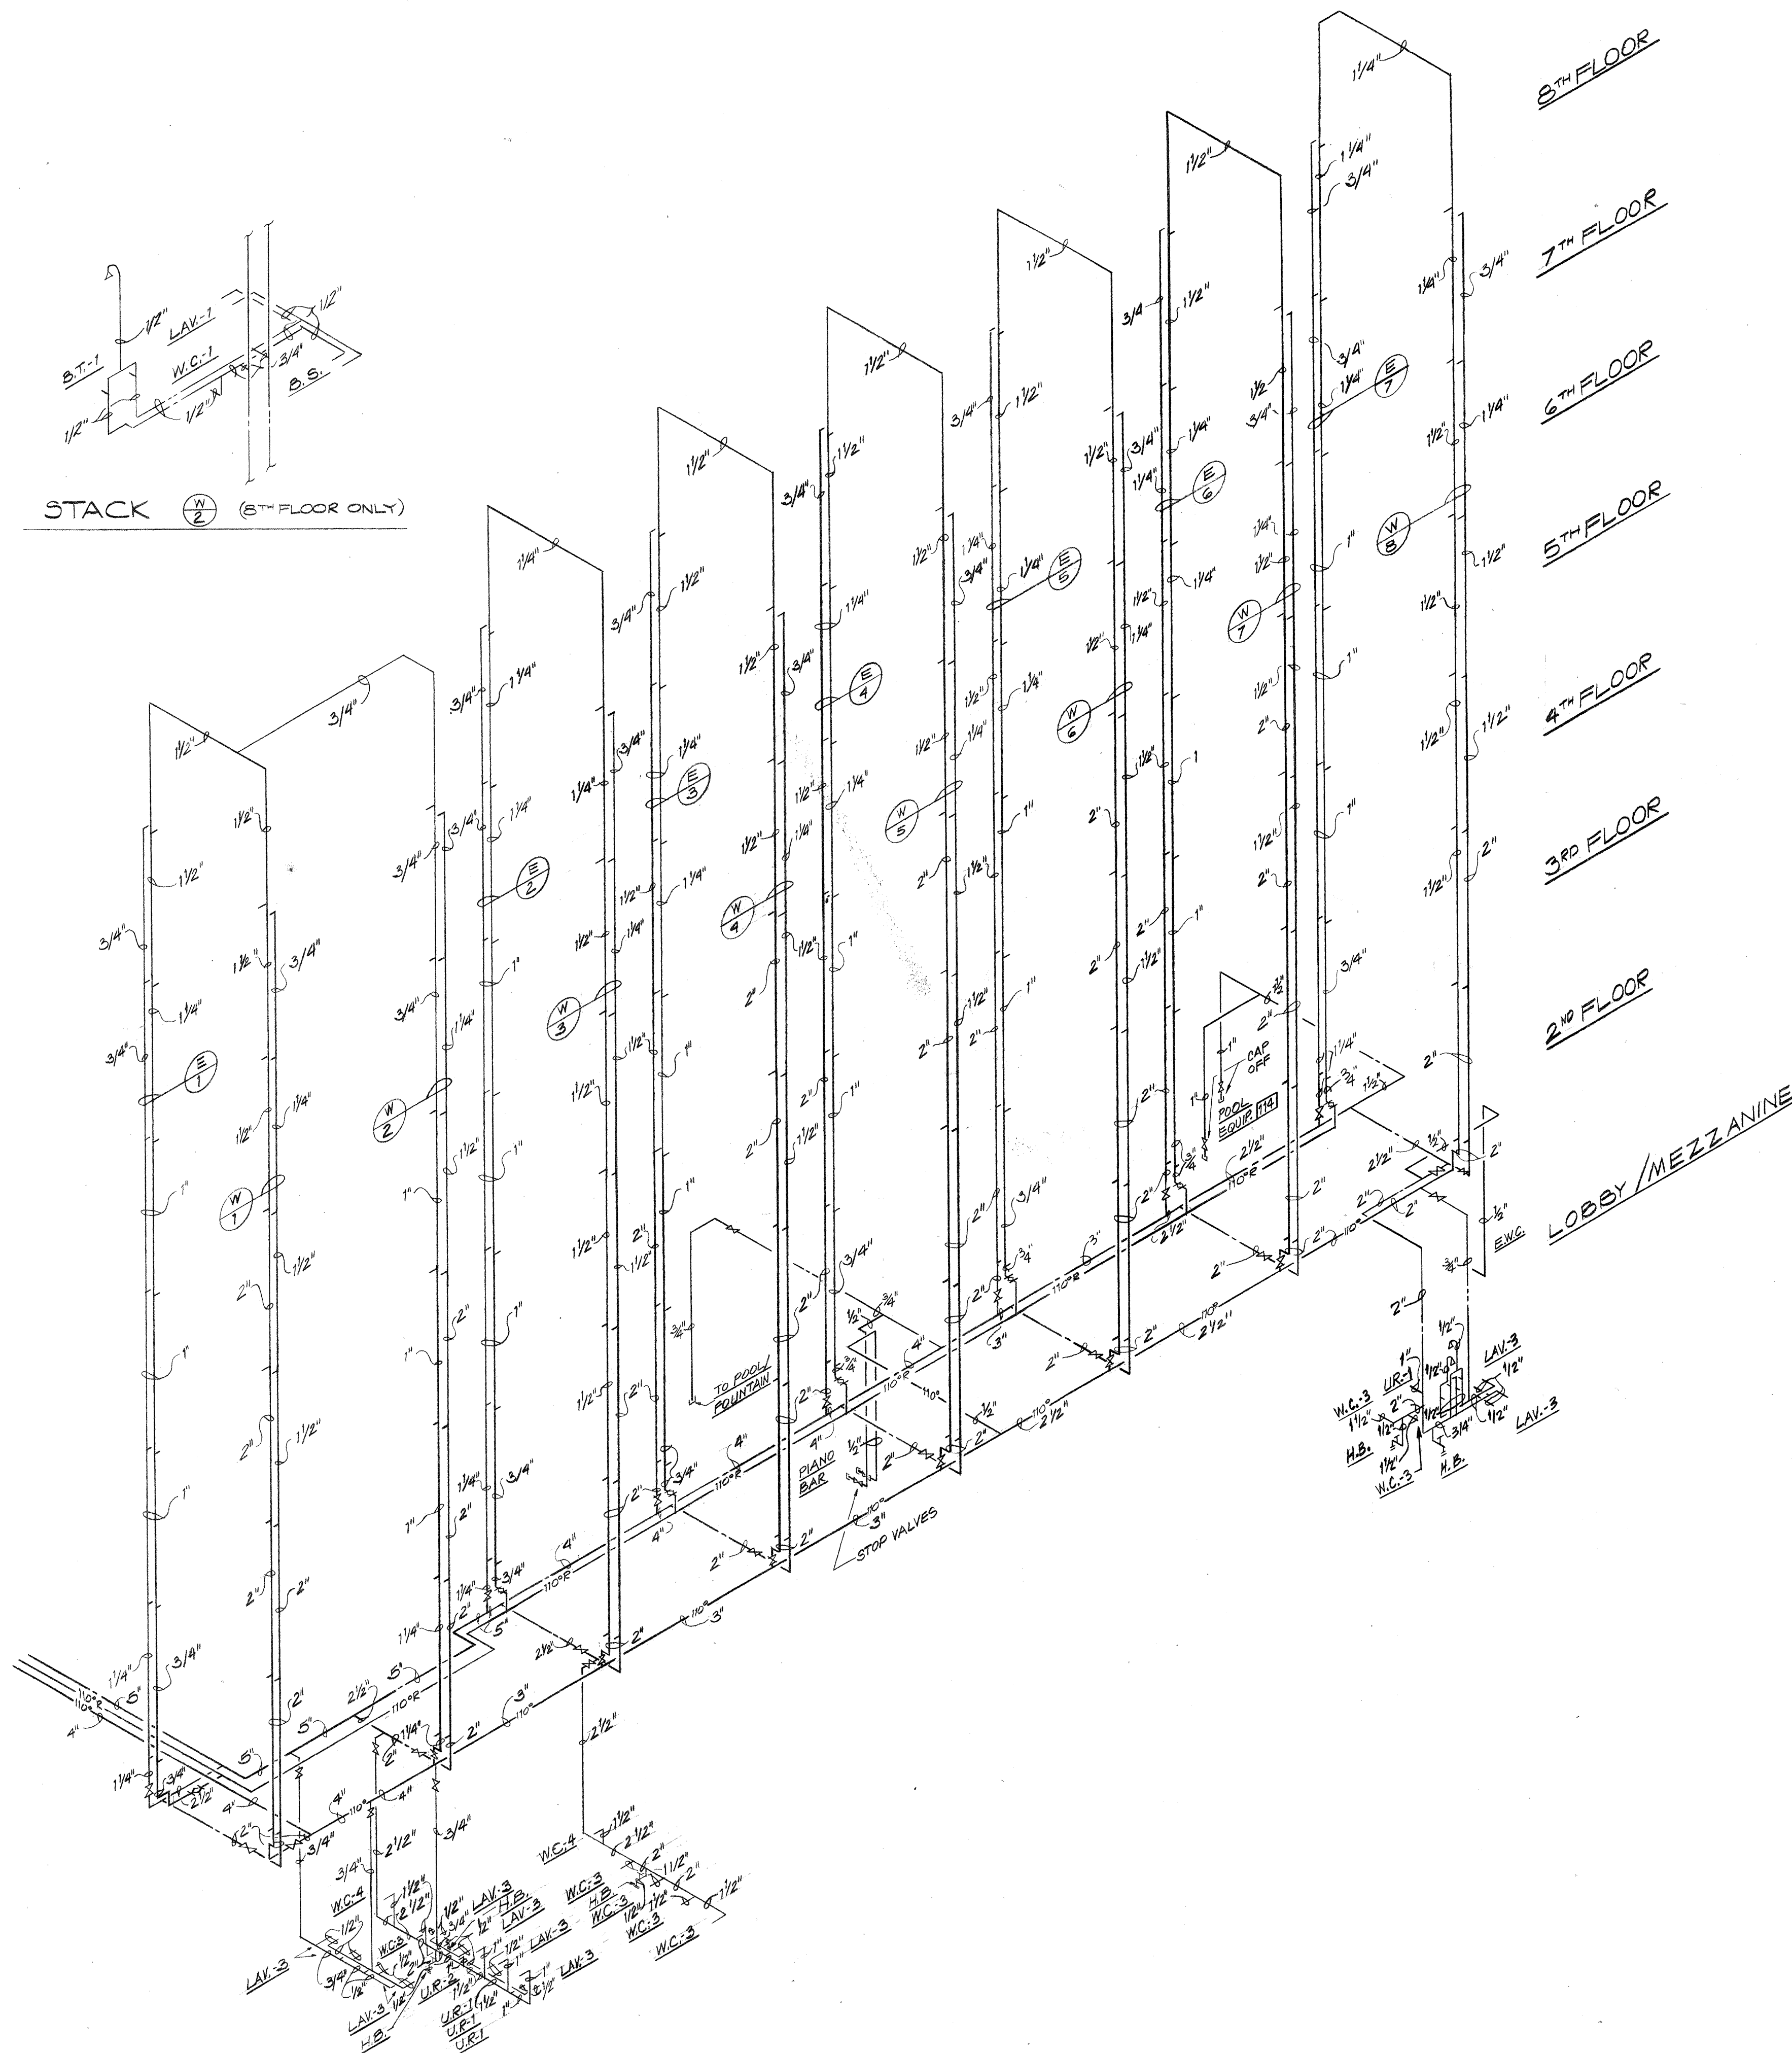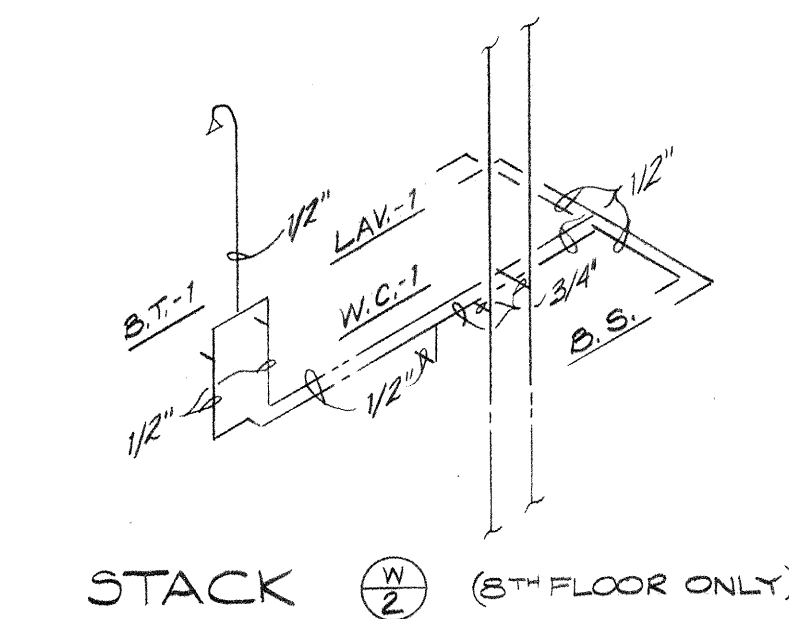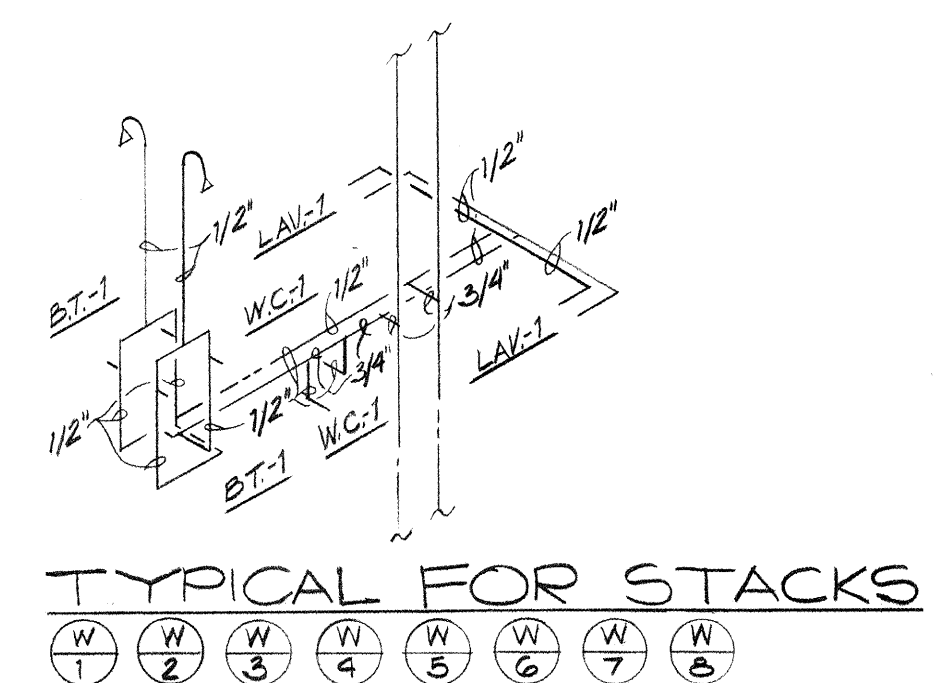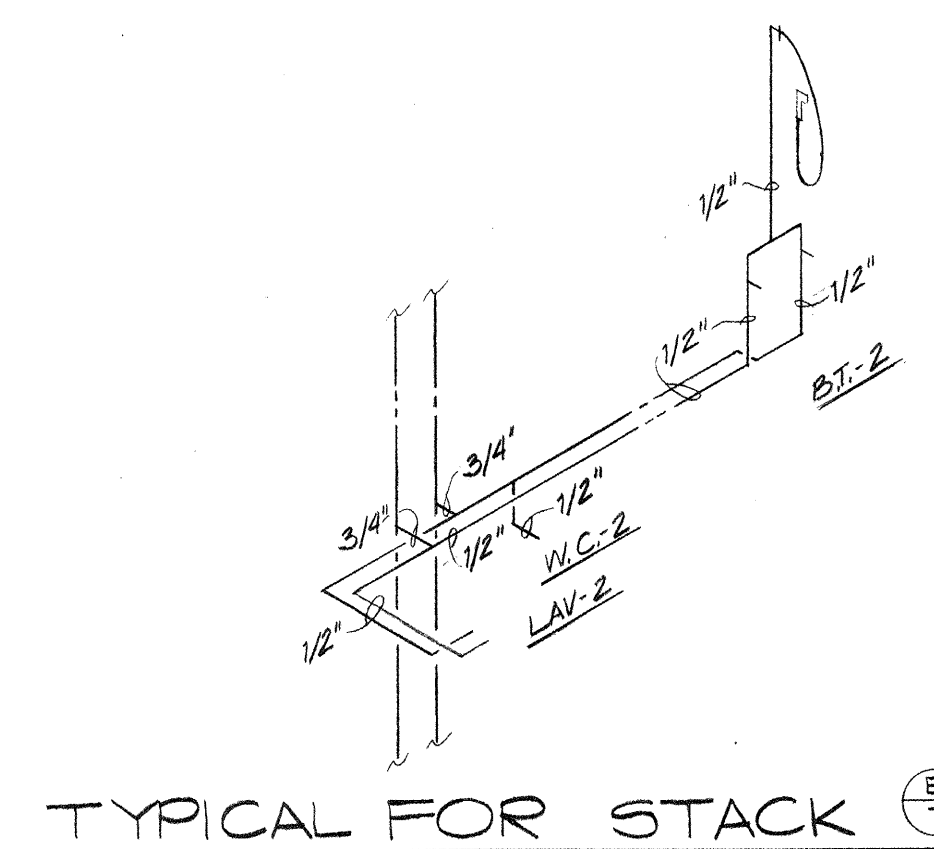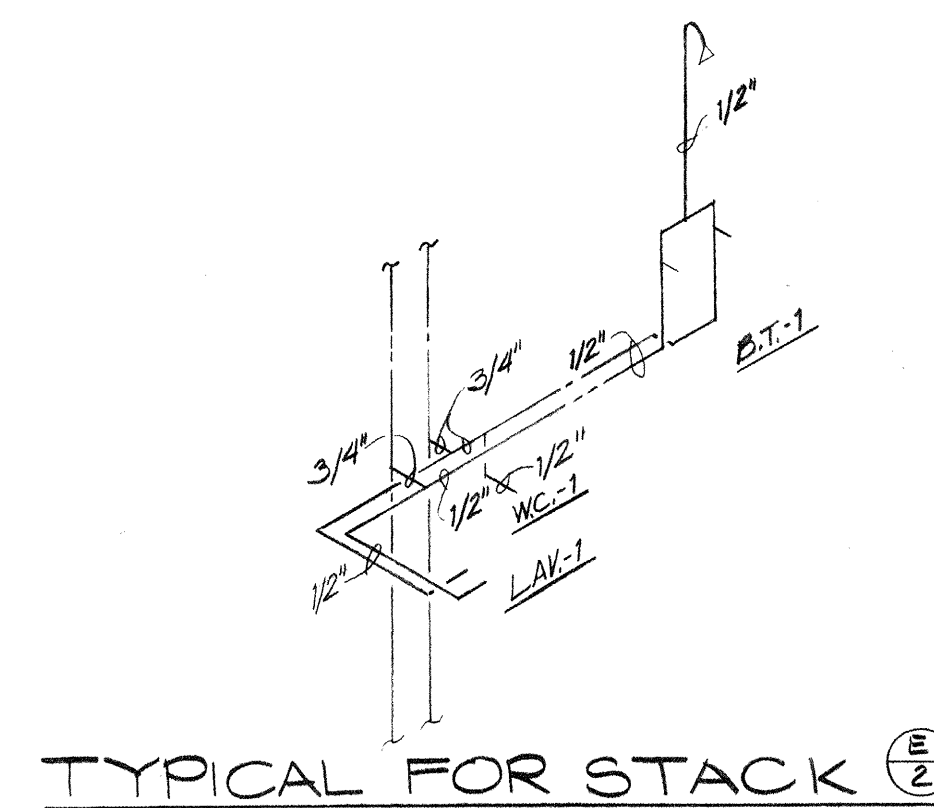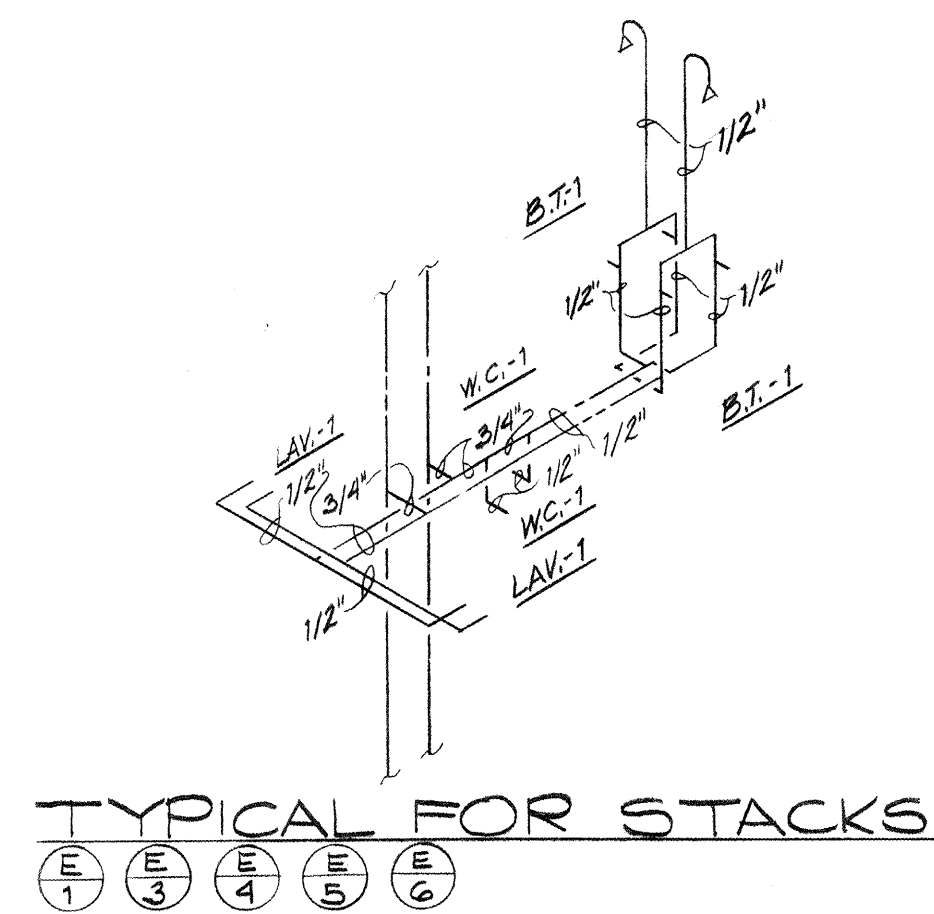

PARTIAL DOMESTIC WATER PIPING DIAGRAM
NO SCALE

NO SCALE

Consulting Engineers
3257 Lochness Drive
Lexington, Kentucky



Consulting Engineers
257 Lochness Drive
Lexington, Kentucky

Lexington, Kentucky

CARTER - FOSTER INC.

CAPITOL PLAZA HOTEL
FRANKFORT / KENTUCKY

FRANKFORT / KENTUCKY

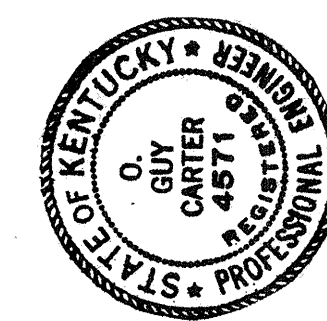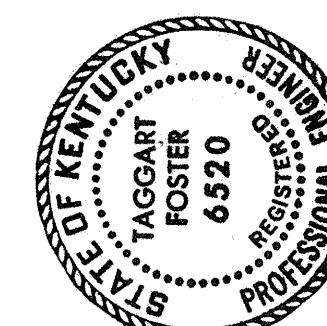

© JOHNSON / ROMANOWITZ / ARCHITECTS / LEXINGTON / KENTUCKY
TEL EDPHONE (606) 252-6781

TELEPHONE 1606/252-6781

TELEPHONE 1606/252-6781

TELEPHONE 1606/252-6781

DRAWN RU	PROJECT
-------------	---------

CHECKED	DATE 5-10-
---------	---------------

PLUMBING

FLOMBING





PARTIAL DOMESTIC WATER PIPING DIAGRAMS

DIAGRAMS

DRAWING

DRAWING
D 16


P-16

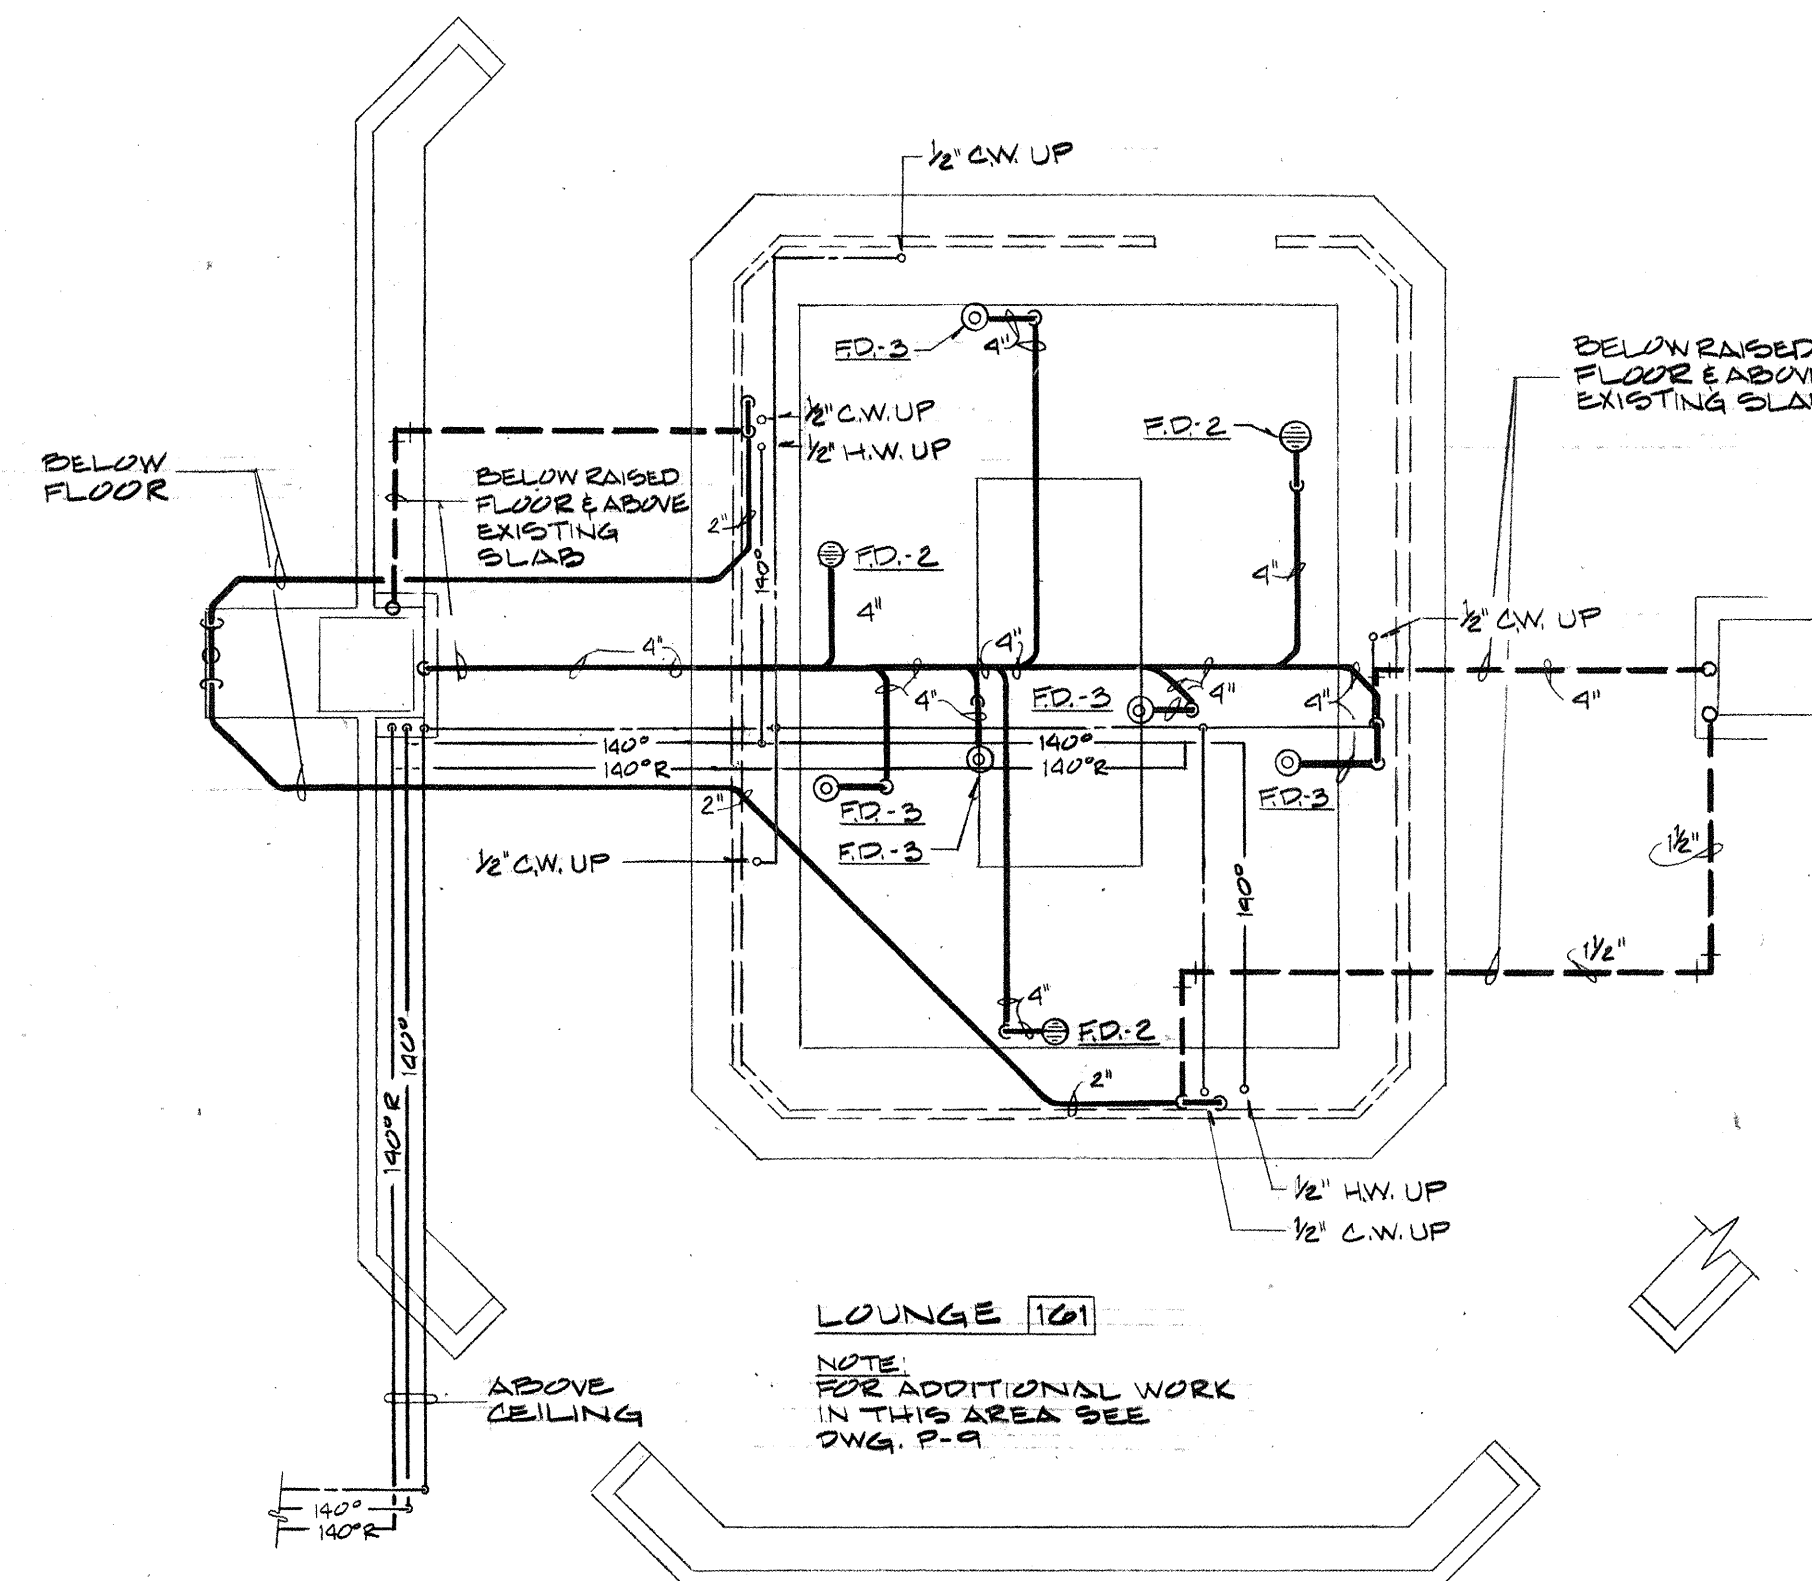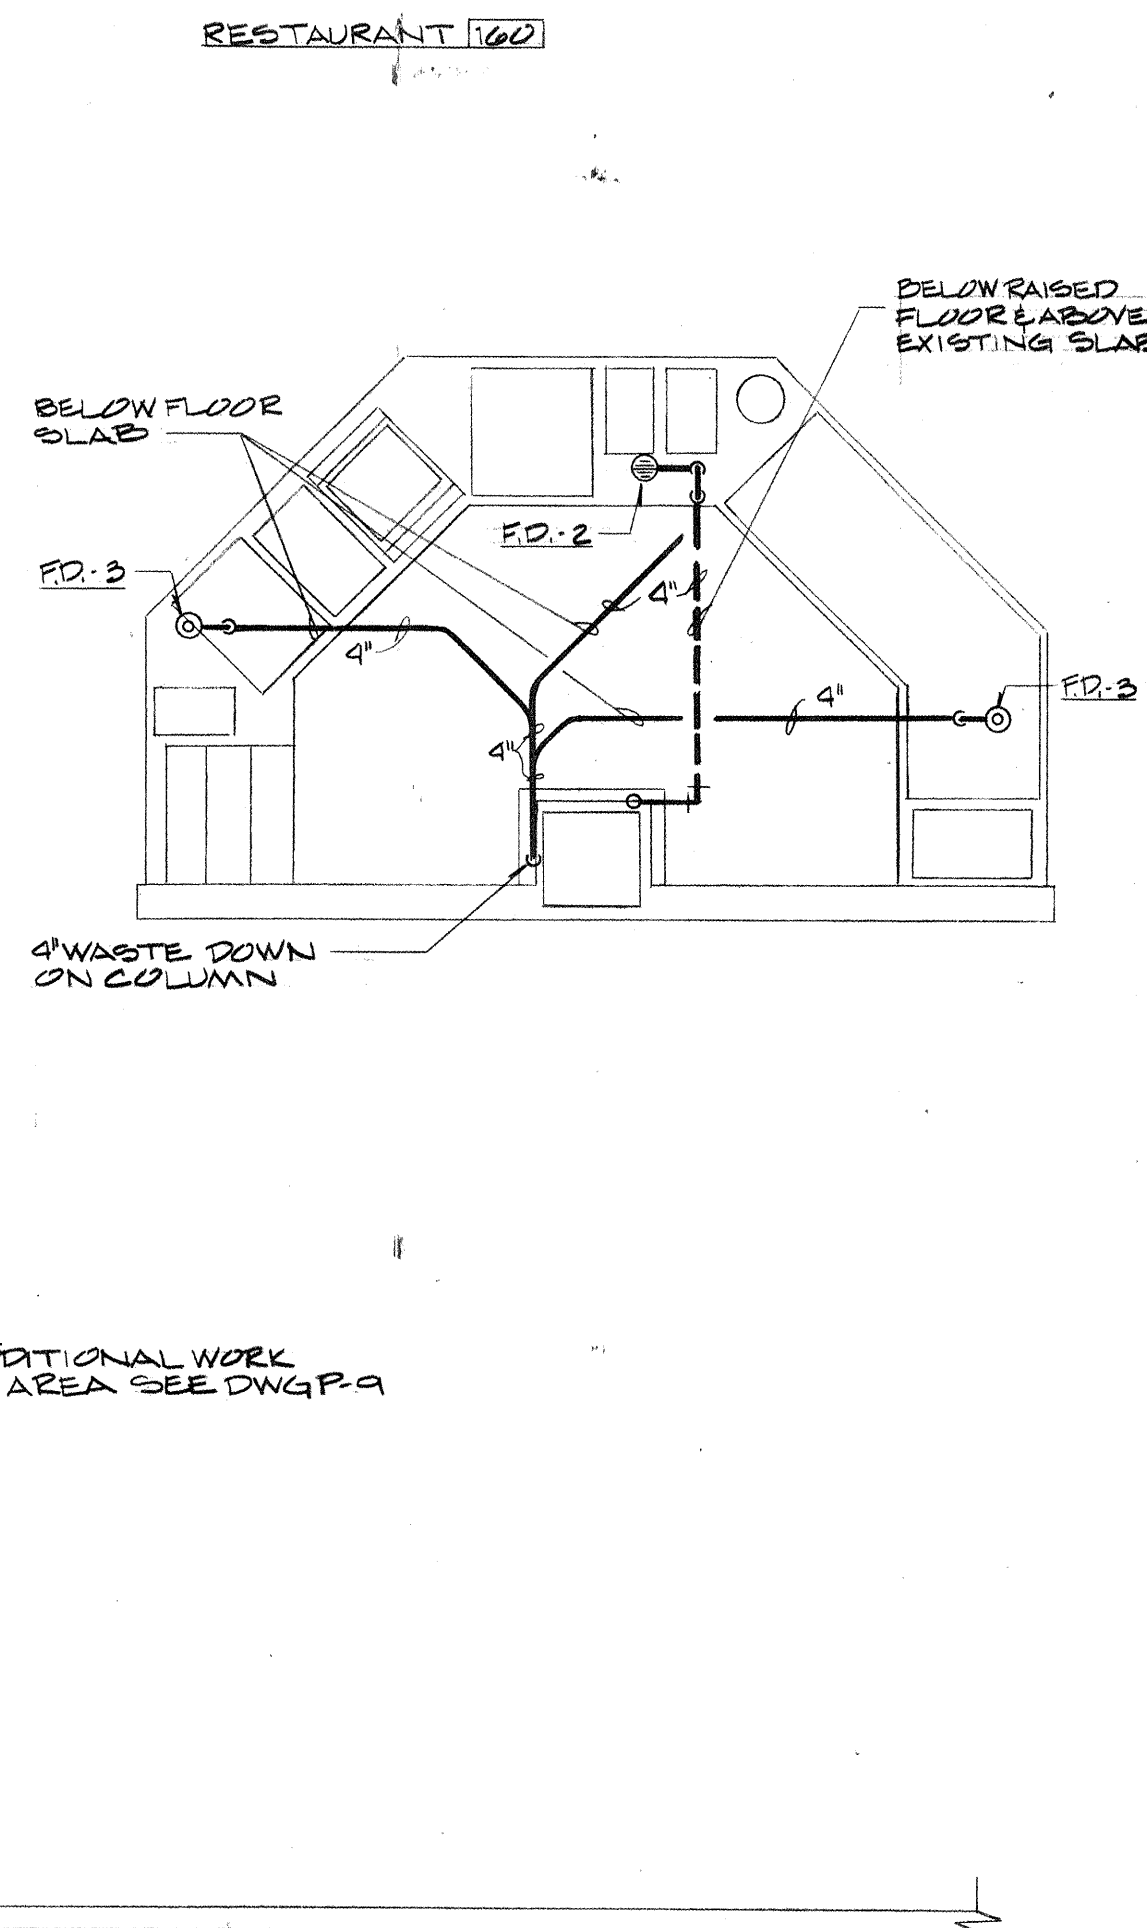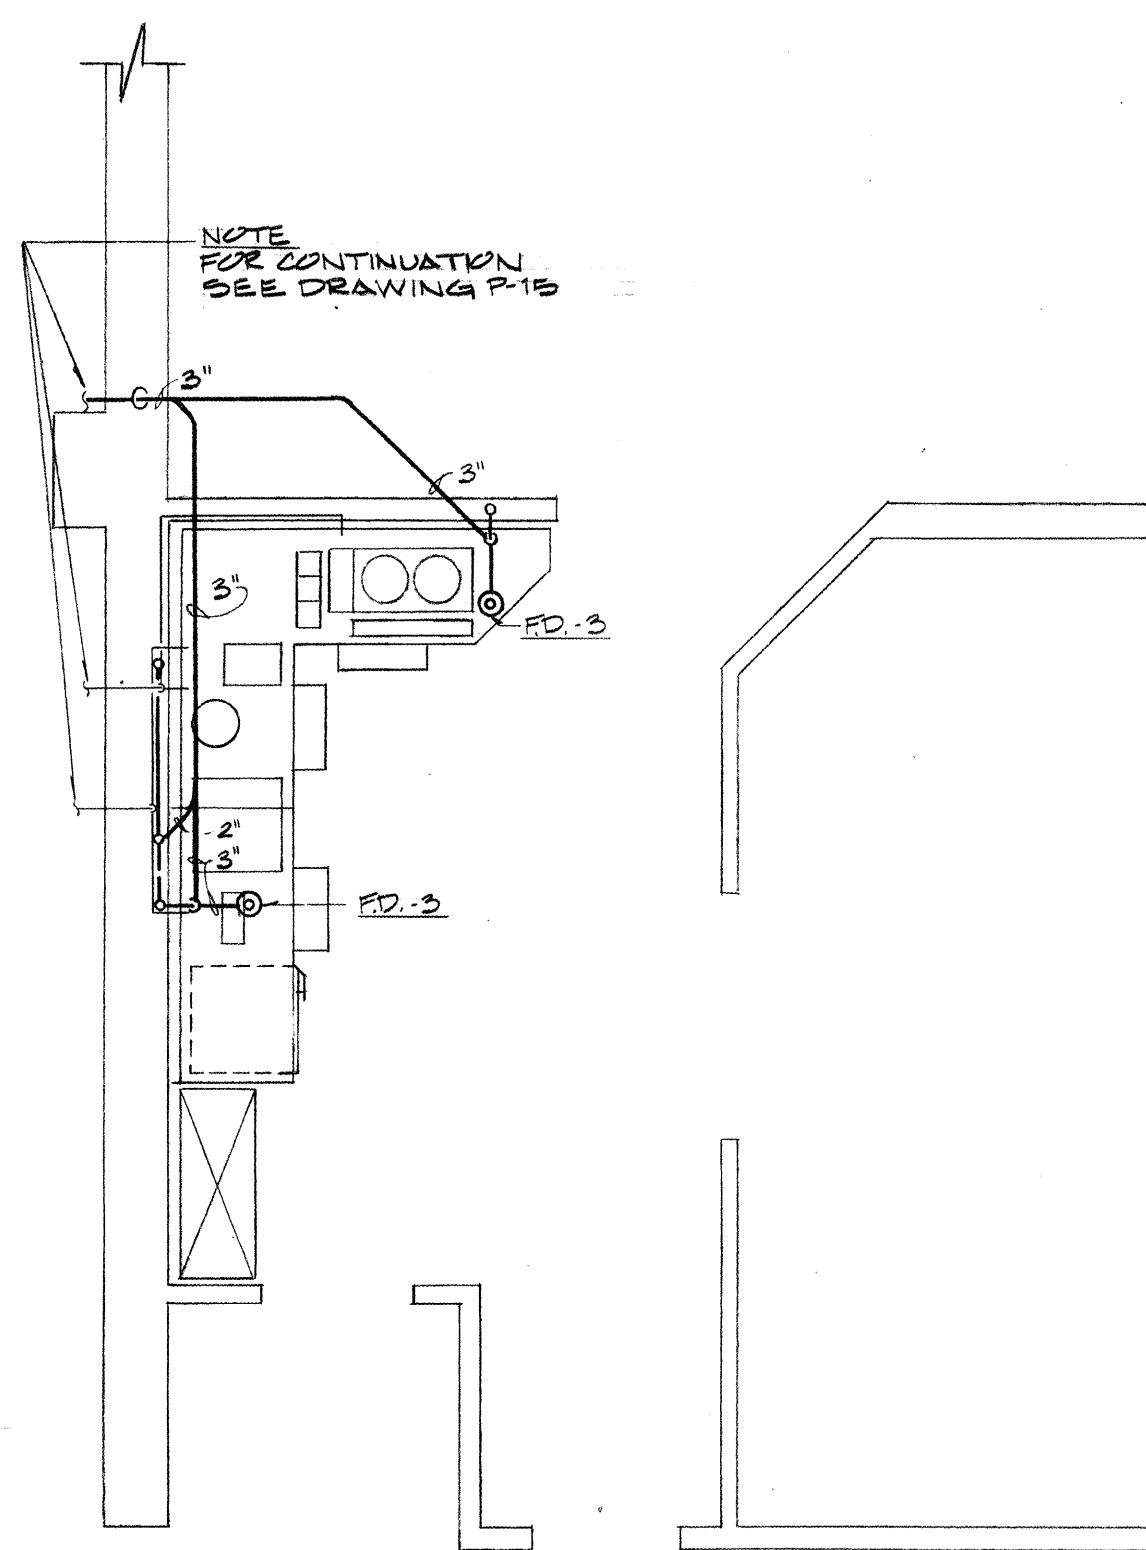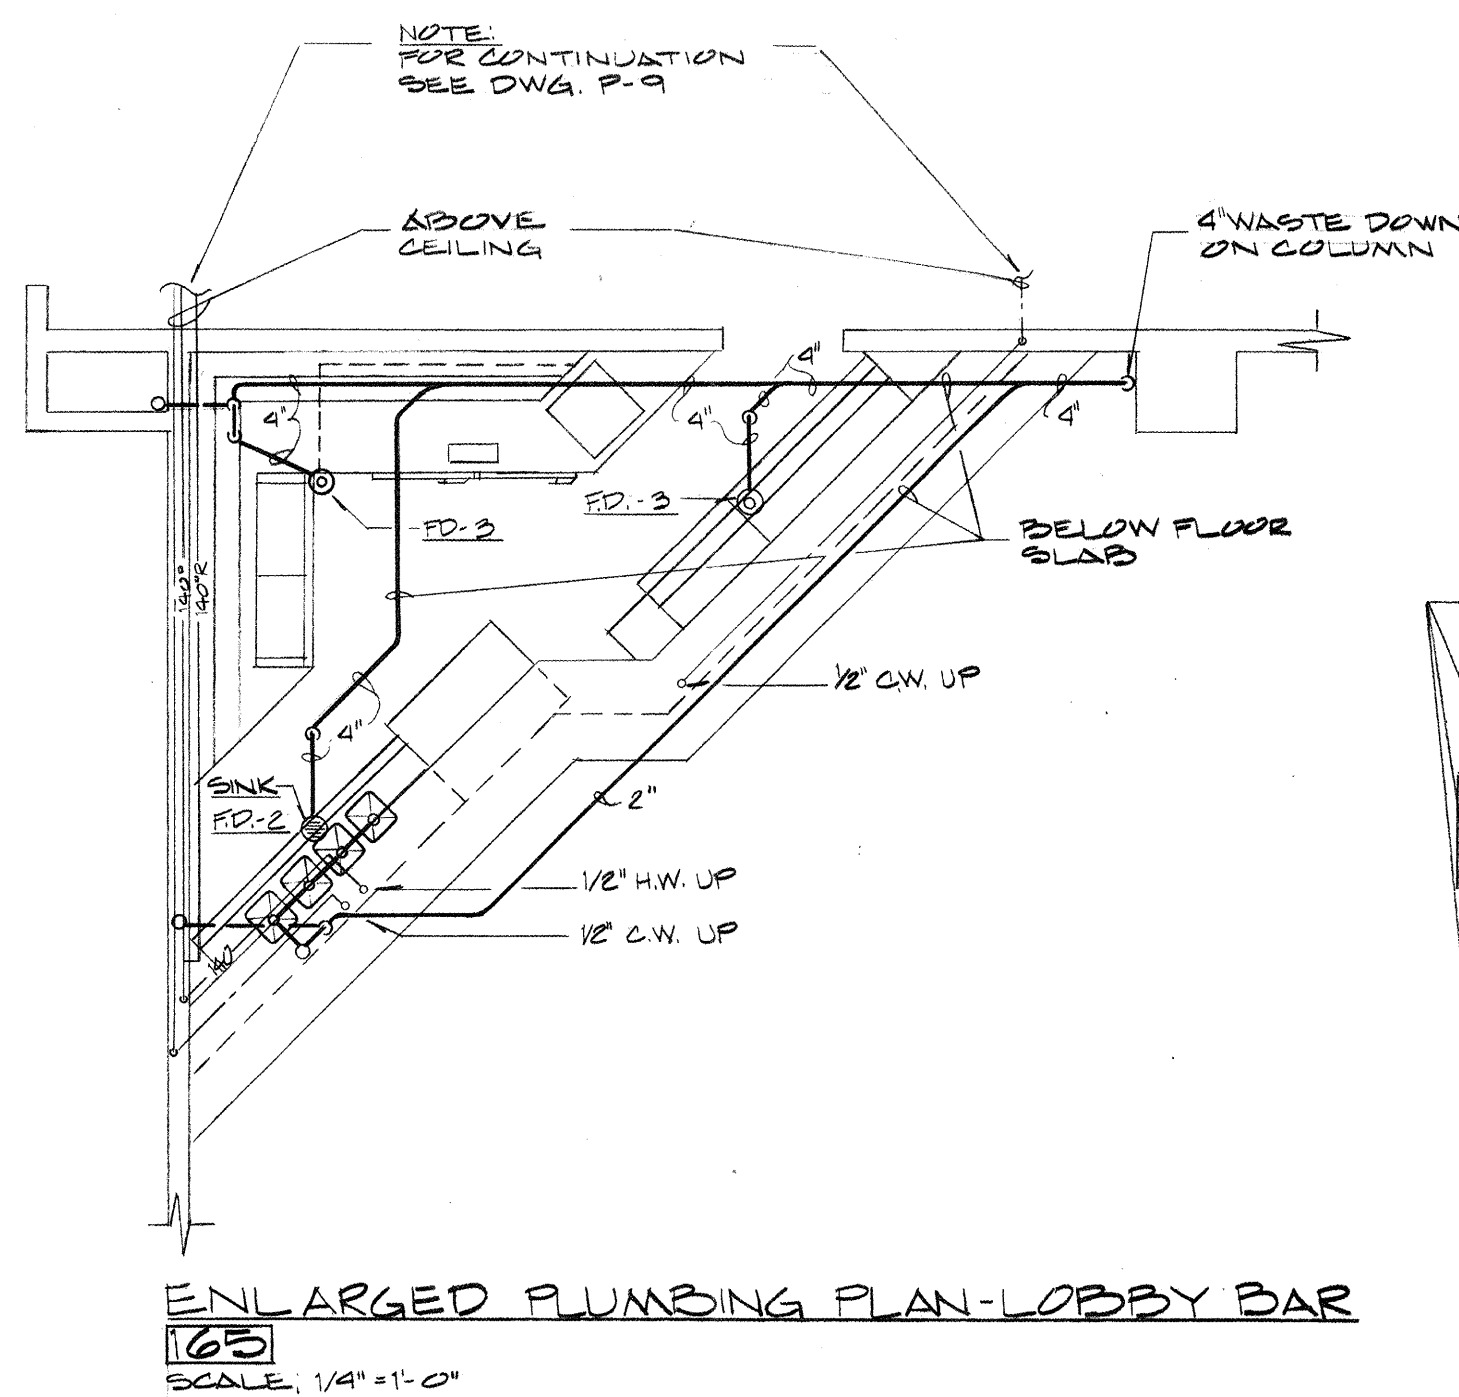

SCHEDULE OF KITCHEN EQUIPMENT


- 8 STOCK POT RANGE
- 9 BAKE OVEN
- 14 WORK TABLE WITH SINK
- 22 POTATO PEELER & DISPOSER
- 23 POTATO PREP TABLE
- 25 PREPARATION TABLE
- 31 ICE MACHINES
- 34 COFFEE URN
- 37 TEA URN
- 38 ICE BINS
- 40 DRINK TOWER & ICE BINS
- 37 BANQUET COUNTER
- 39 TILTING SKILLET
- 60 UTILITY SINK
- 62 OPEN BURNER RANGE WITH SHELF
- 63 HOT TOP RANGE WITH SHELF
- 64 CHAR BOILER
- 66 STEAMER
- 67 TILTING KETTLE
- 71 UPRIGHT BOILER WITH OVEN
- 73 FRYERS
- 75 FRY TOP RANGE
- 76 OPEN BURNER/HOT TOP RANGE
- 78 20 QT. KETTLES
- 92 COLD PAN

ENLARGED PLUMBING PLAN-RESTAURANT AREA 160
SCALE: 1/4"=1'-0"

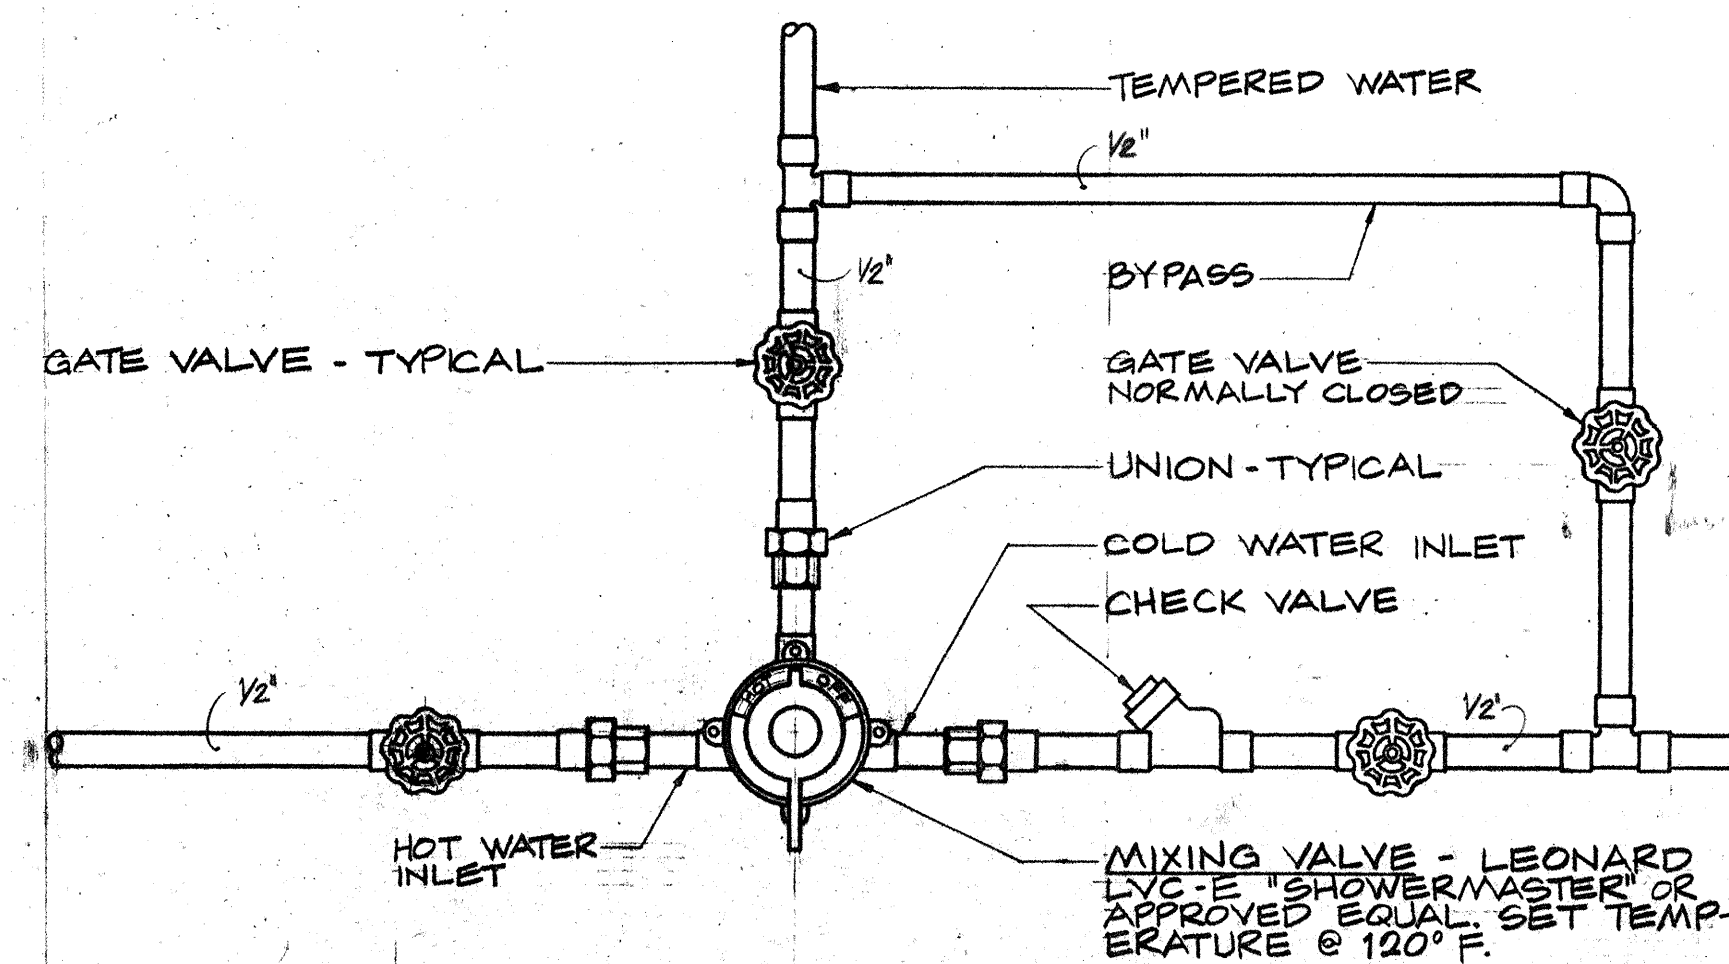

MIXING VALVE PIPING DIAGRAM
NO SCALE

ENLARGED PLUMBING PLAN-LOUNGE 161
SCALE: 1/4"=1'-0"



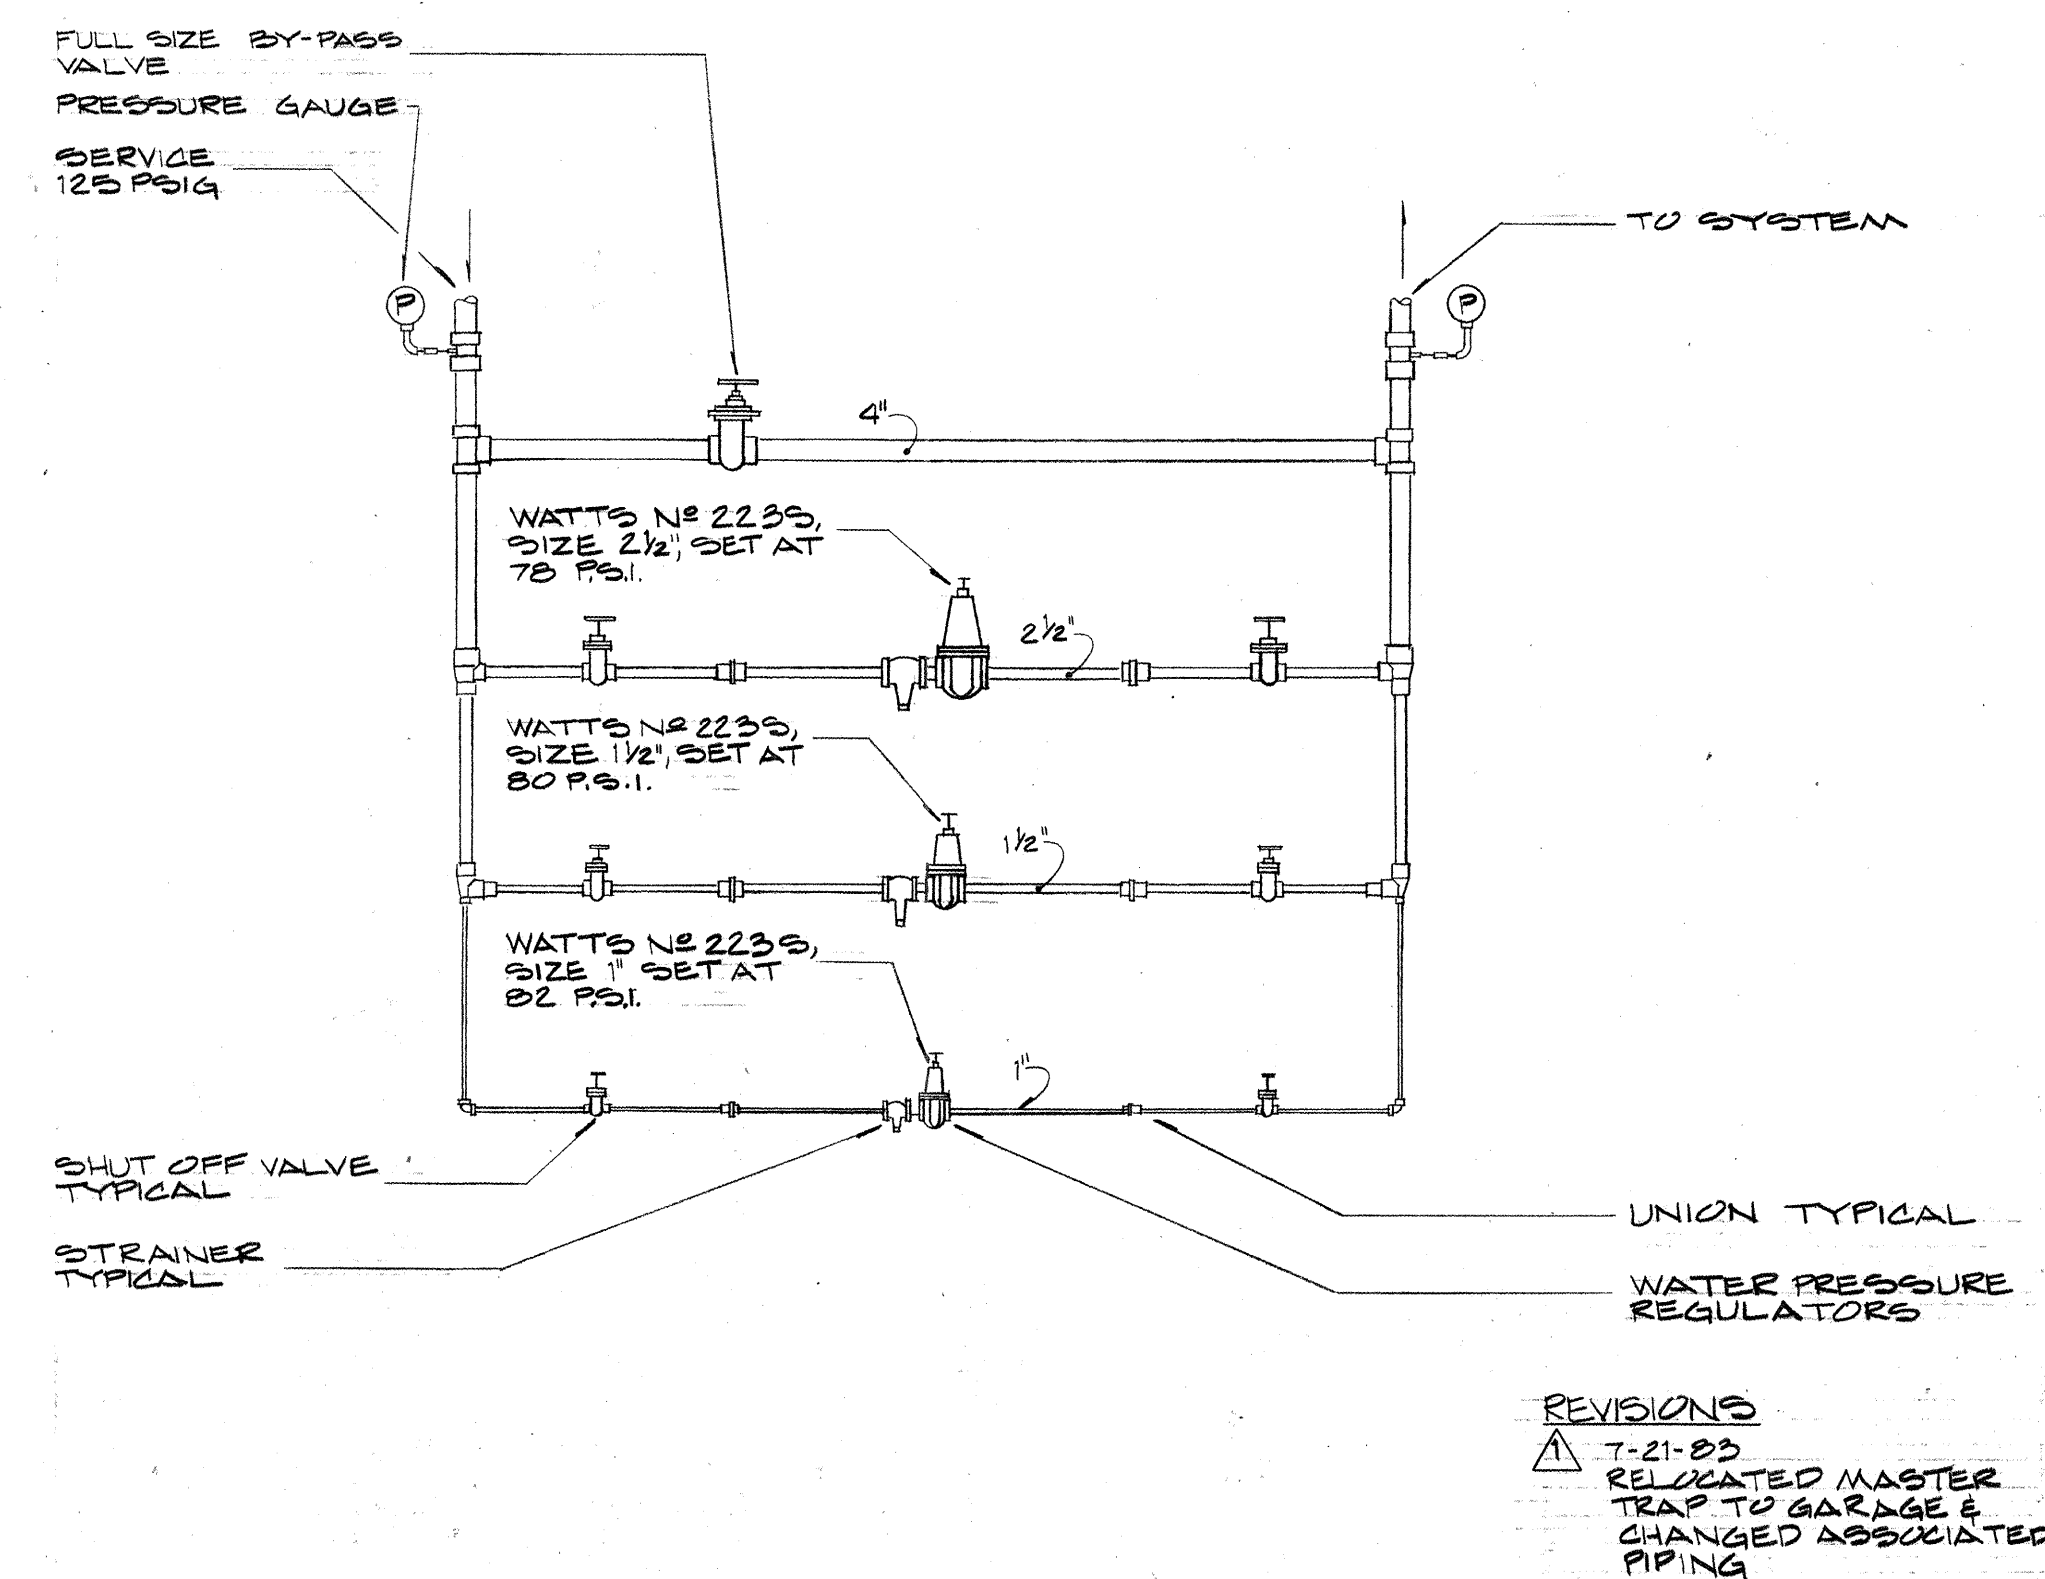


WATER PRESSURE REGULATING STATION
NO SCALE

Consulting Engineers
3257 Locness Drive
Lexington, Kentucky

CARTER - FOSTER INC.

CAPITOL PLAZA HOTEL
FRANKFORT / KENTUCKY

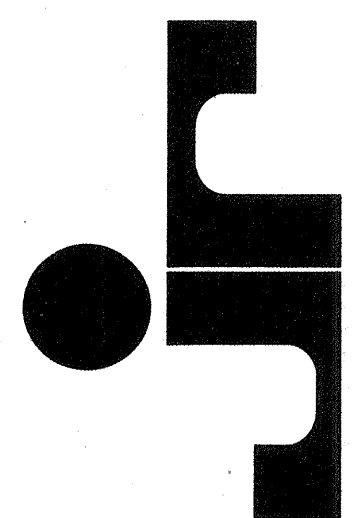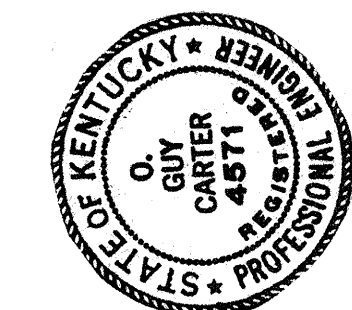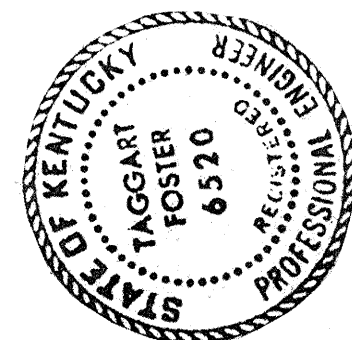

JOHNSON / ROMANOWITZ / ARCHITECTS / LEXINGTON / KENTUCKY
301 EAST VINE STREET, SUITE A
TELEPHONE (606) 252-6761

DRAWN D.H.	PROJECT
CHECKED T.F.	DATE 5-10-83



PLUMBING

ENLARGED PLUMBING
PLANS - SPECIALTY
AREAS

REISSUED 8-2-83

DRAWING
P-16



REVISED 7-5-83

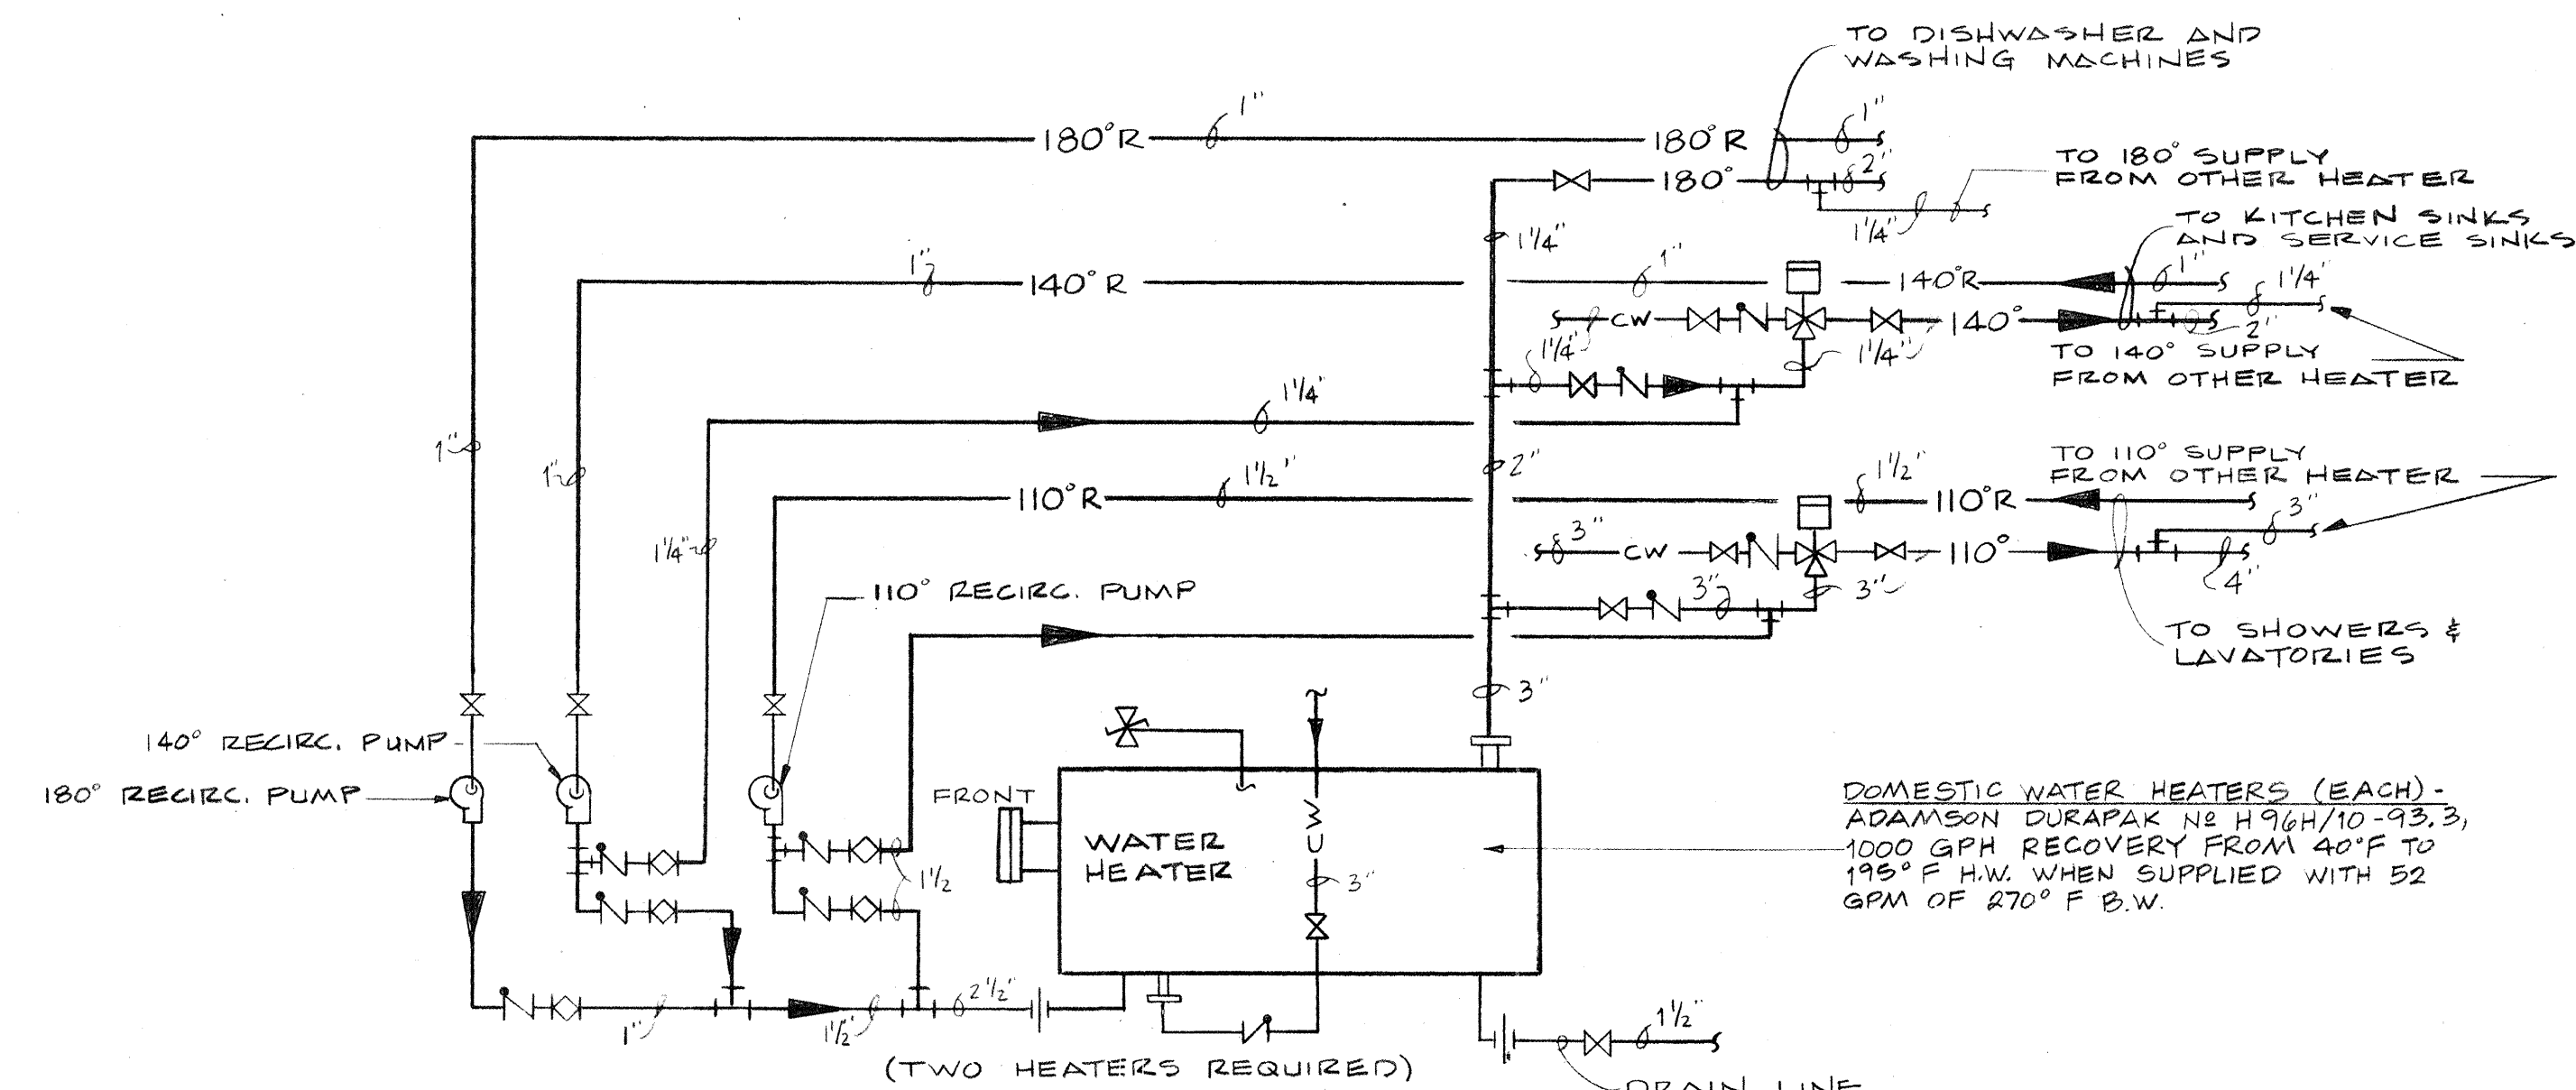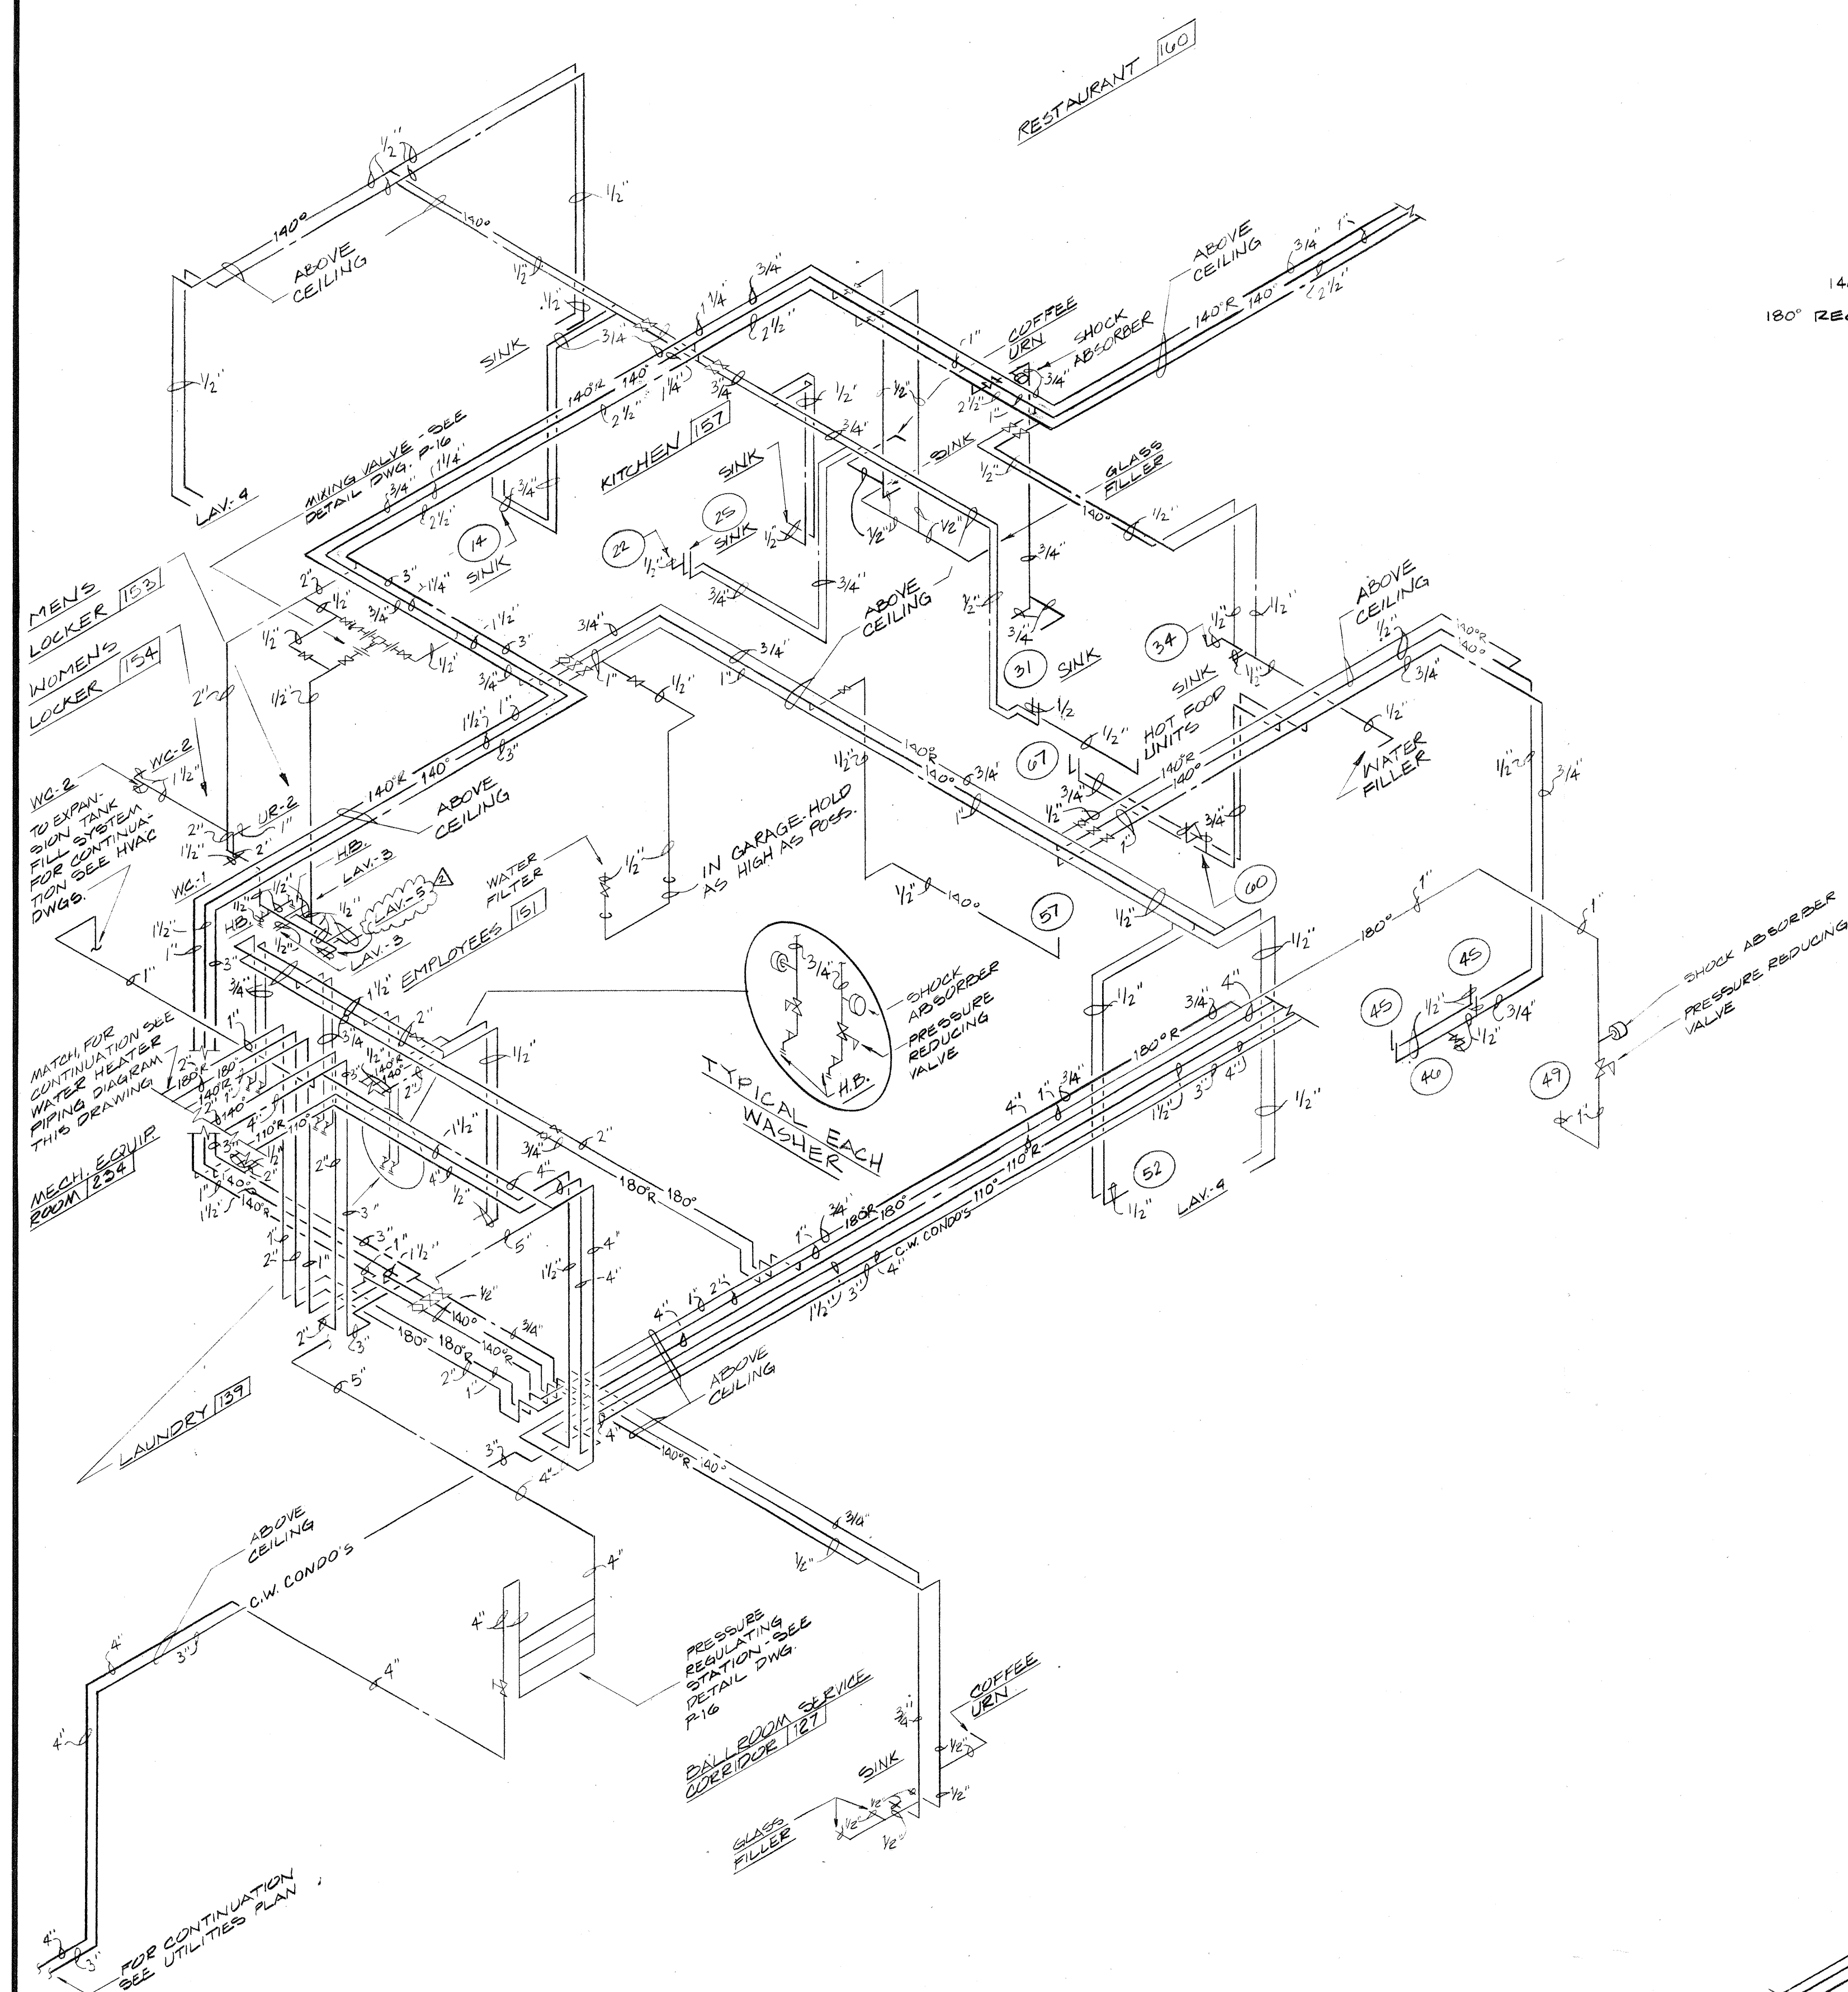

Consulting Engineers
3257 Lochness Drive
Lexington, Kentucky

CARTER - FOSTER INC.

CAPITOL PLAZA HOTEL
FRANKFORT / KENTUCKY

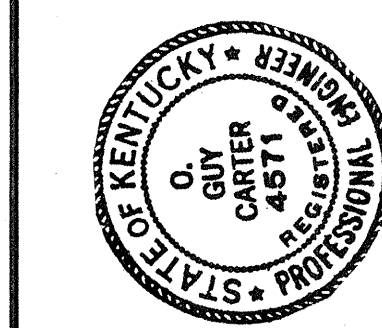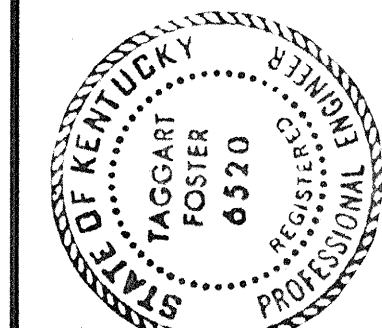

JOHNSON / ROMANOWITZ / ARCHITECTS / LEXINGTON / KENTUCKY
301 EAST VINE STREET, SUITE A
TELEPHONE (606) 252-6781






DRAWN D.G.M.	PROJECT
CHECKED T.F.	DATE 5-10-83

PLUMBING

PARTIAL DOMESTIC WATER
PIPING DIAGRAMS

DRAWING
P-18

VED 9-20-83

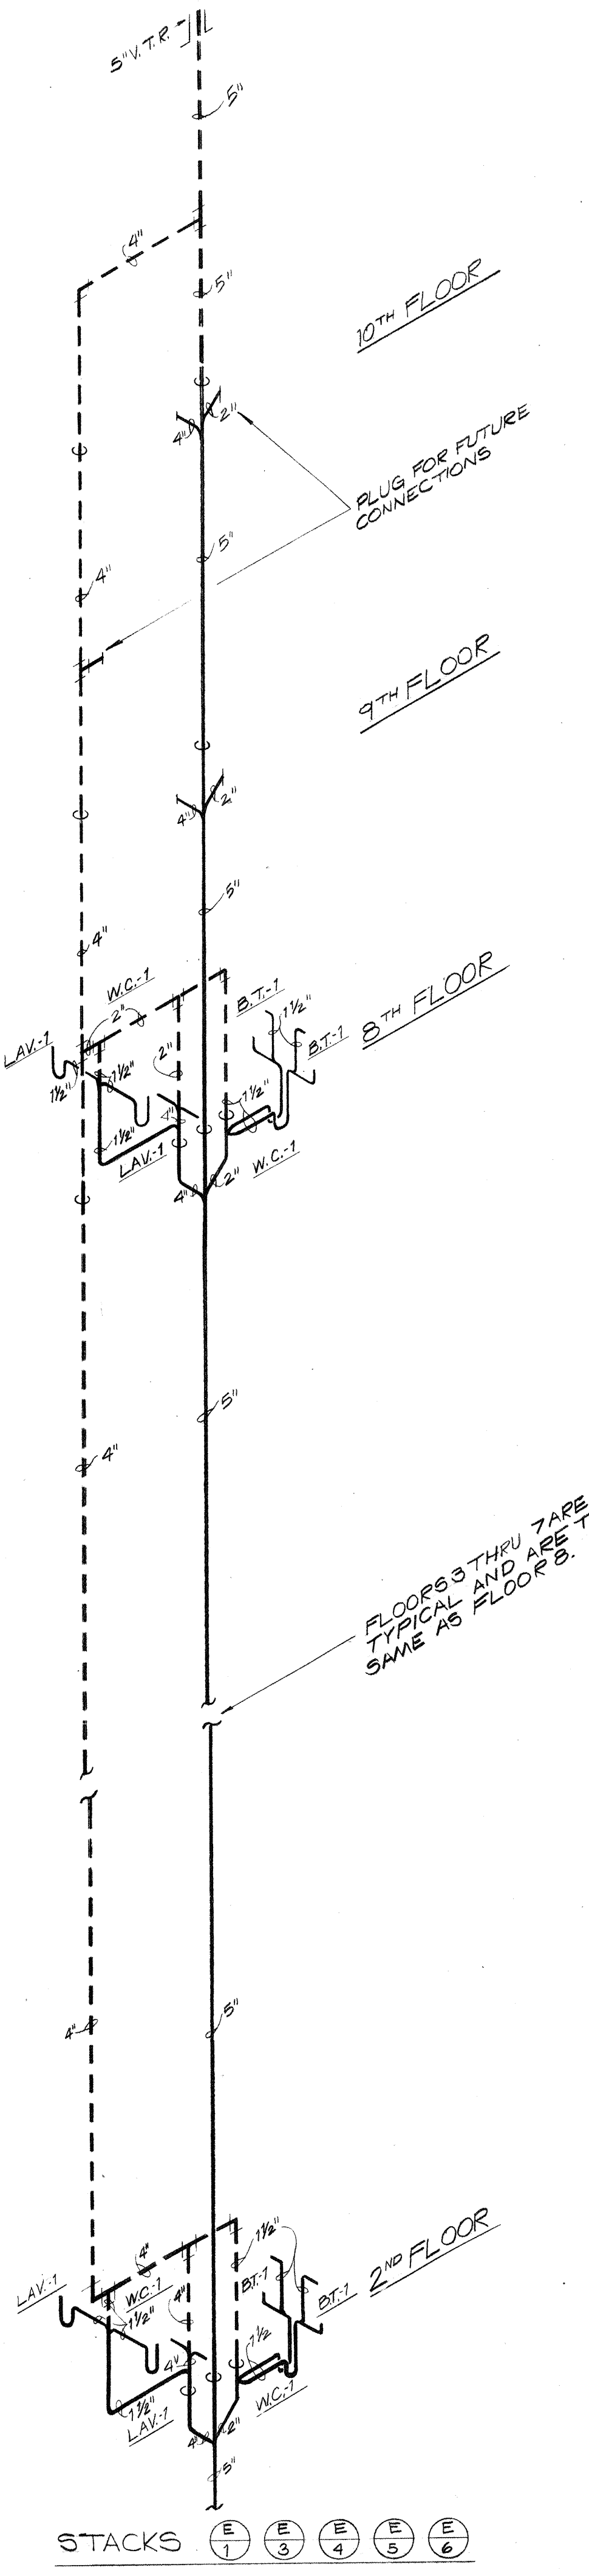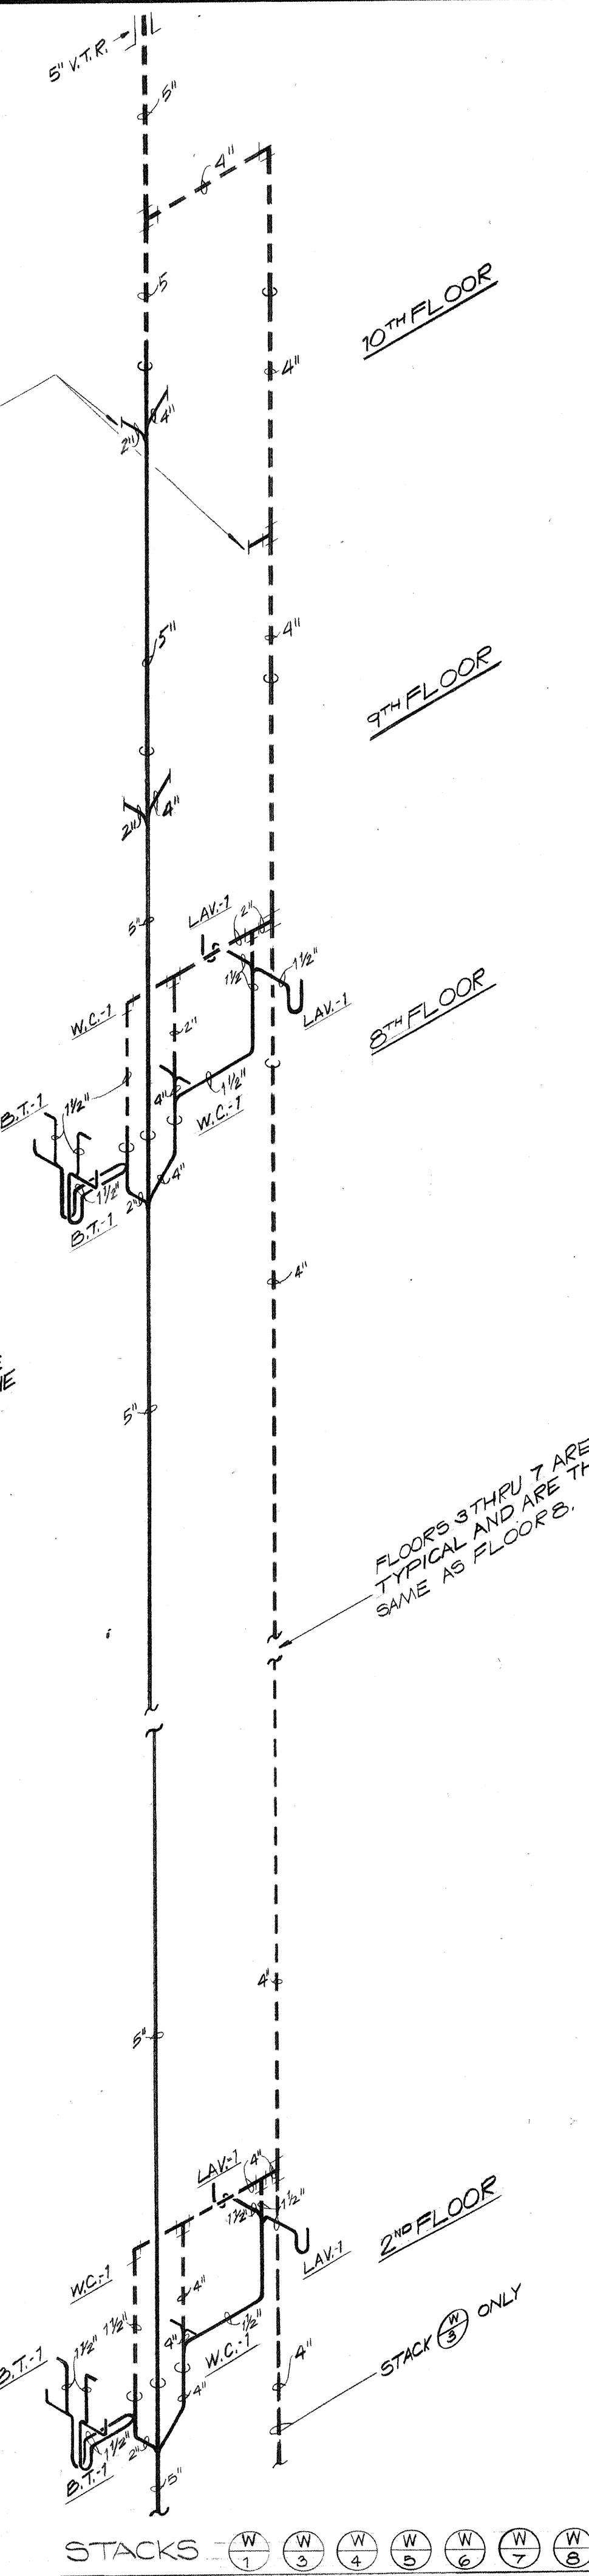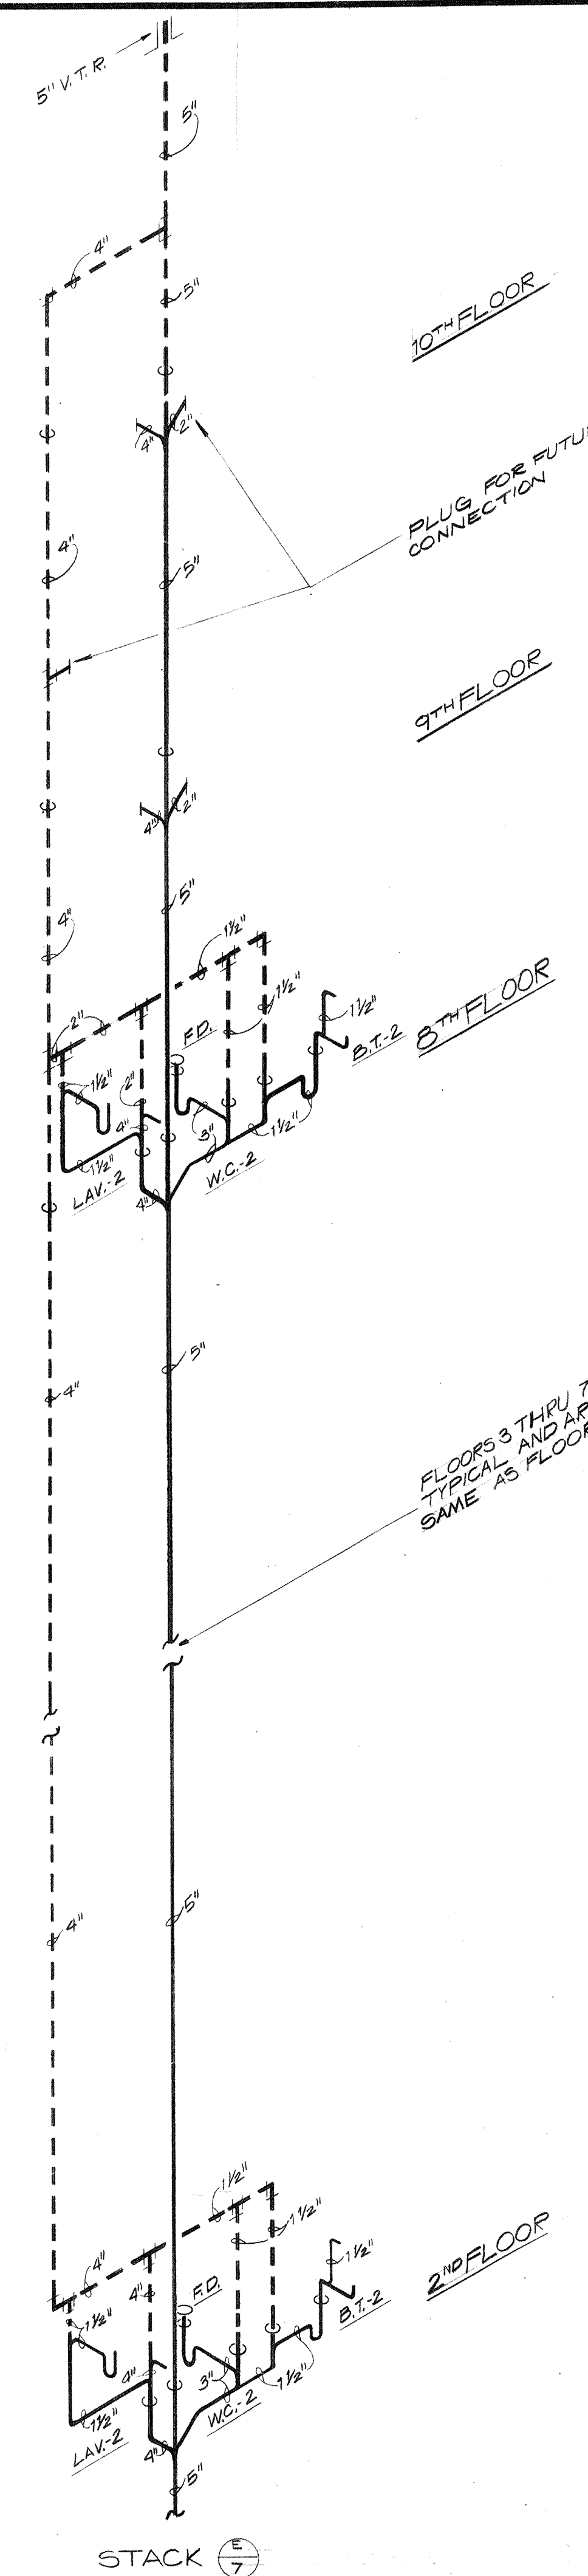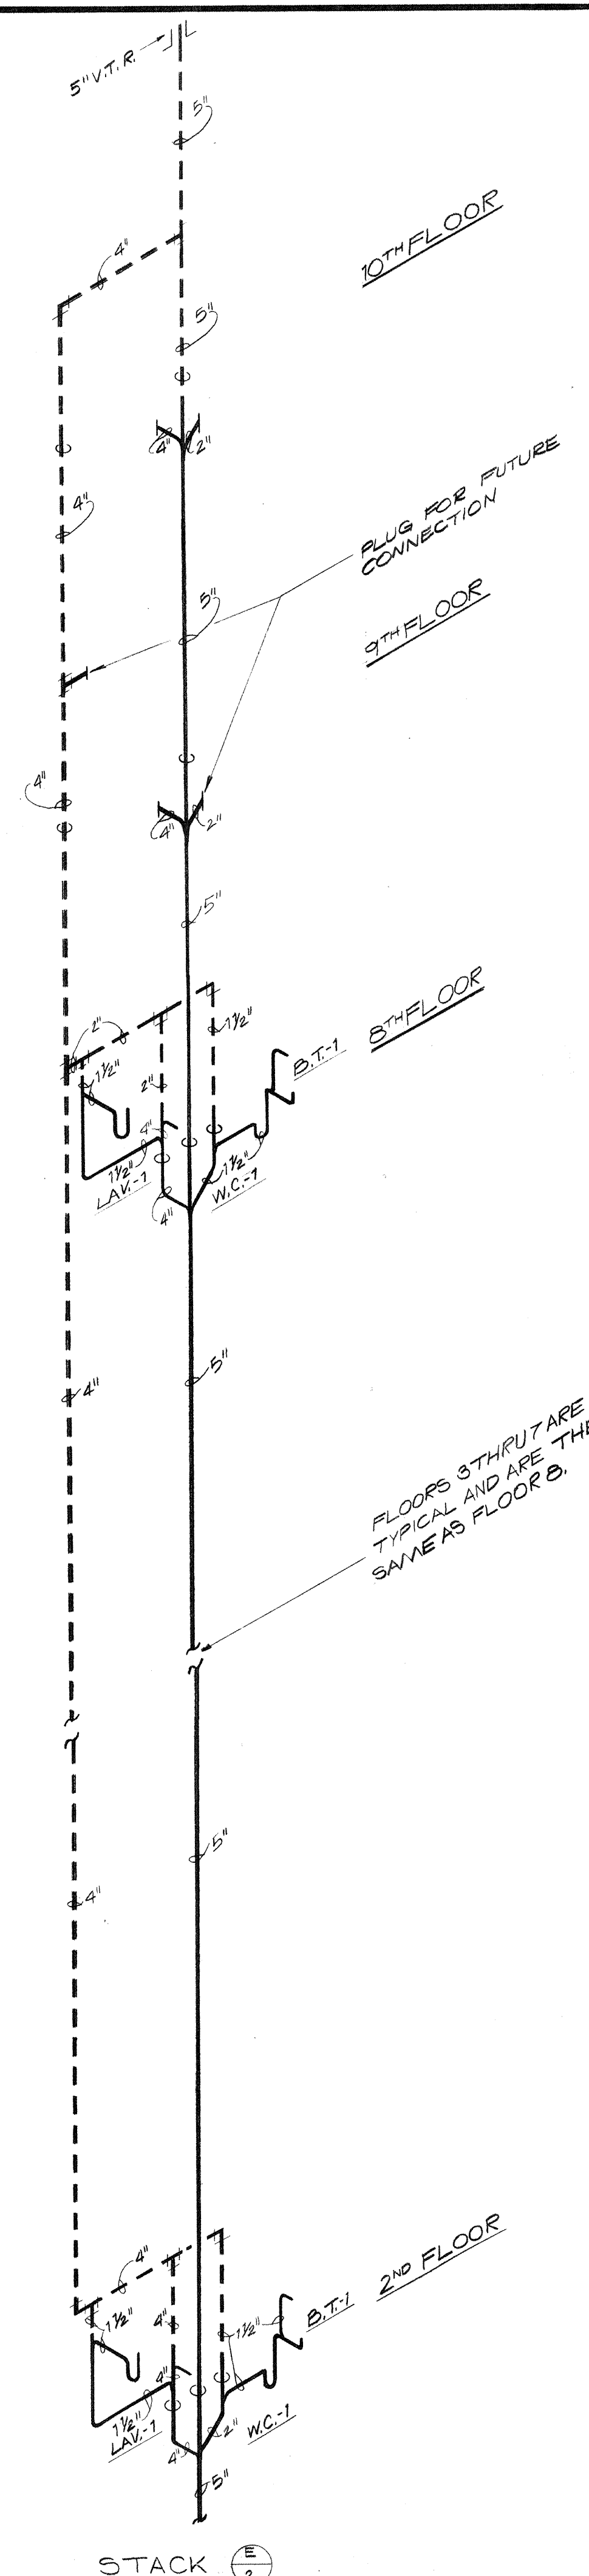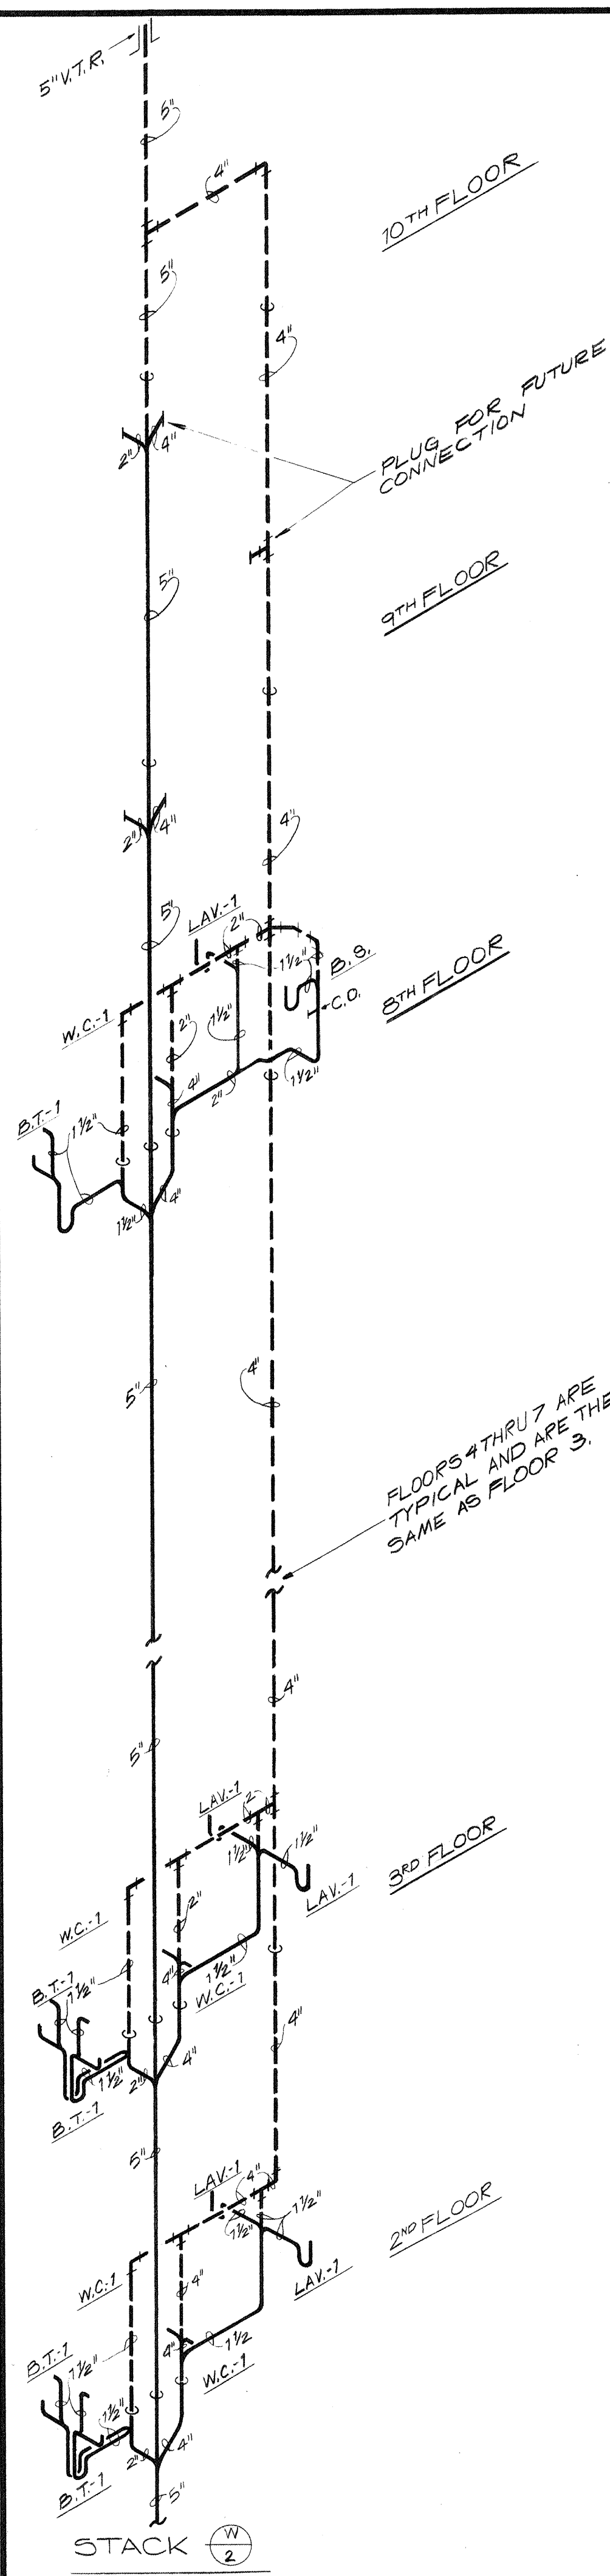

PARTIAL WASTE & VENT PIPING DIAGRAMS
NO SCALE




CARTER - FOSTER INC.

Consulting Engineers
3257 Lochness Drive
Lexington, Kentucky



CAPITOL PLAZA HOTEL
FRANKFORT / KENTUCKY

JOHNSON / ROMANOWITZ / ARCHITECTS / LEXINGTON / KENTUCKY

DRAWN R.H.	PROJECT
CHECKED	DATE 5-10-83
PLUMBING	
PARTIAL WASTE & VENT PIPING DIAGRAM	
DRAWING	
P-18	

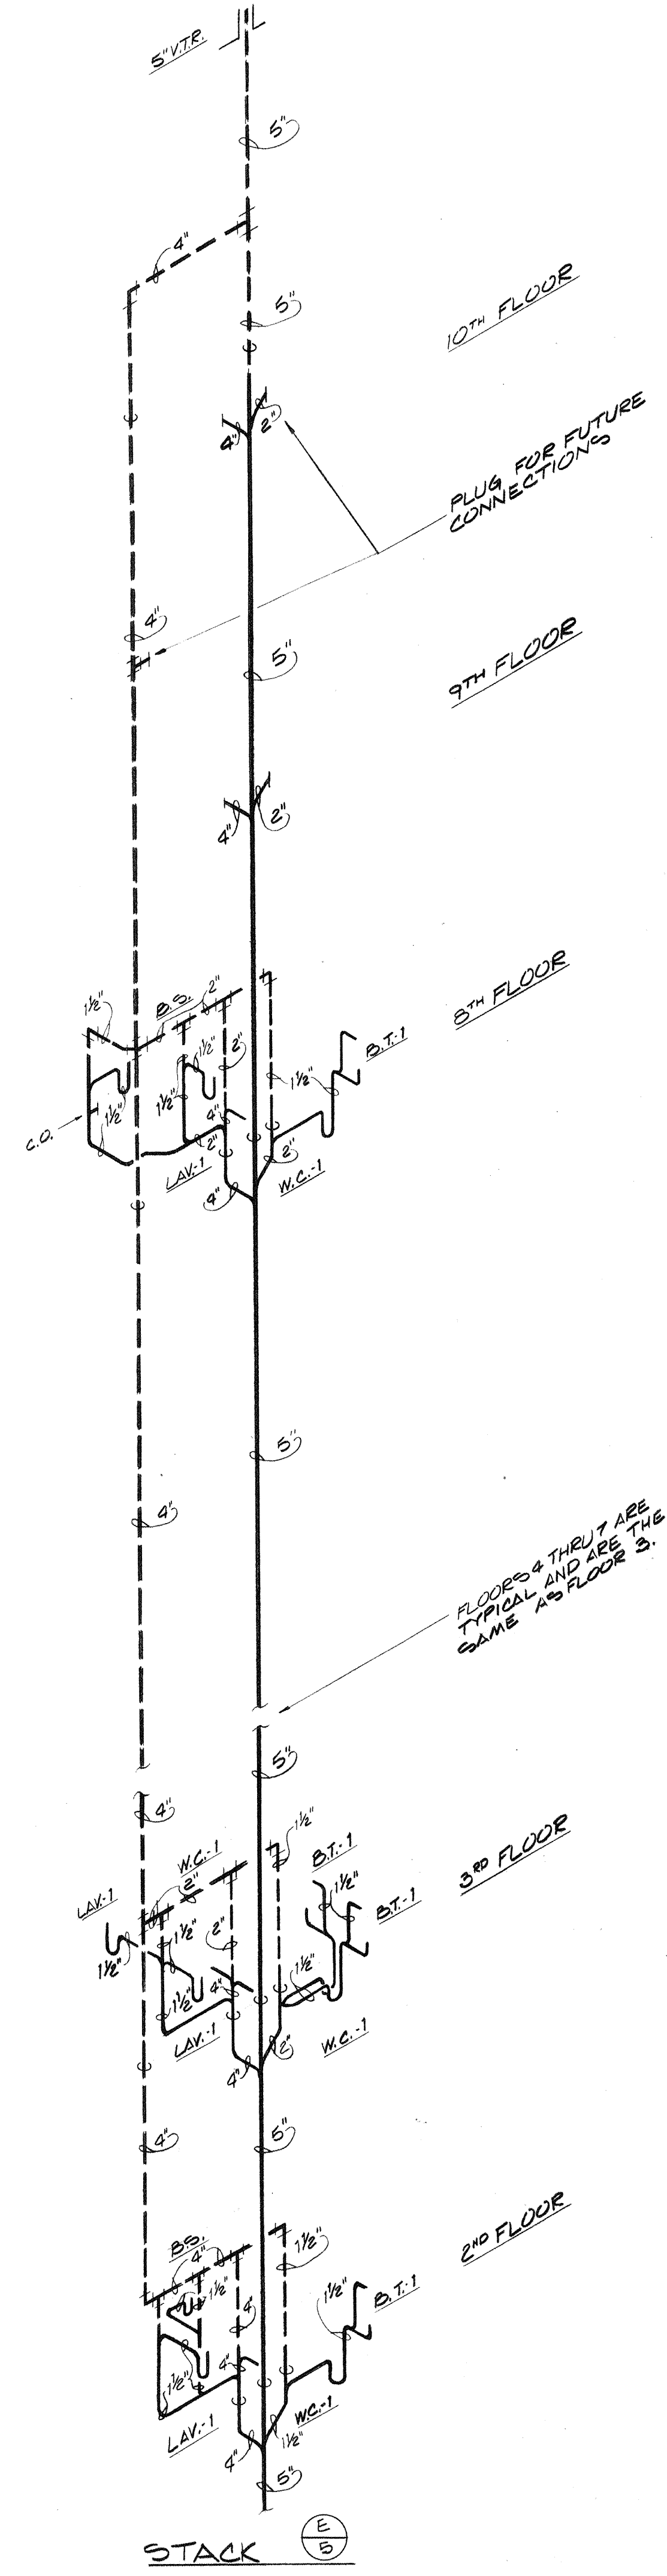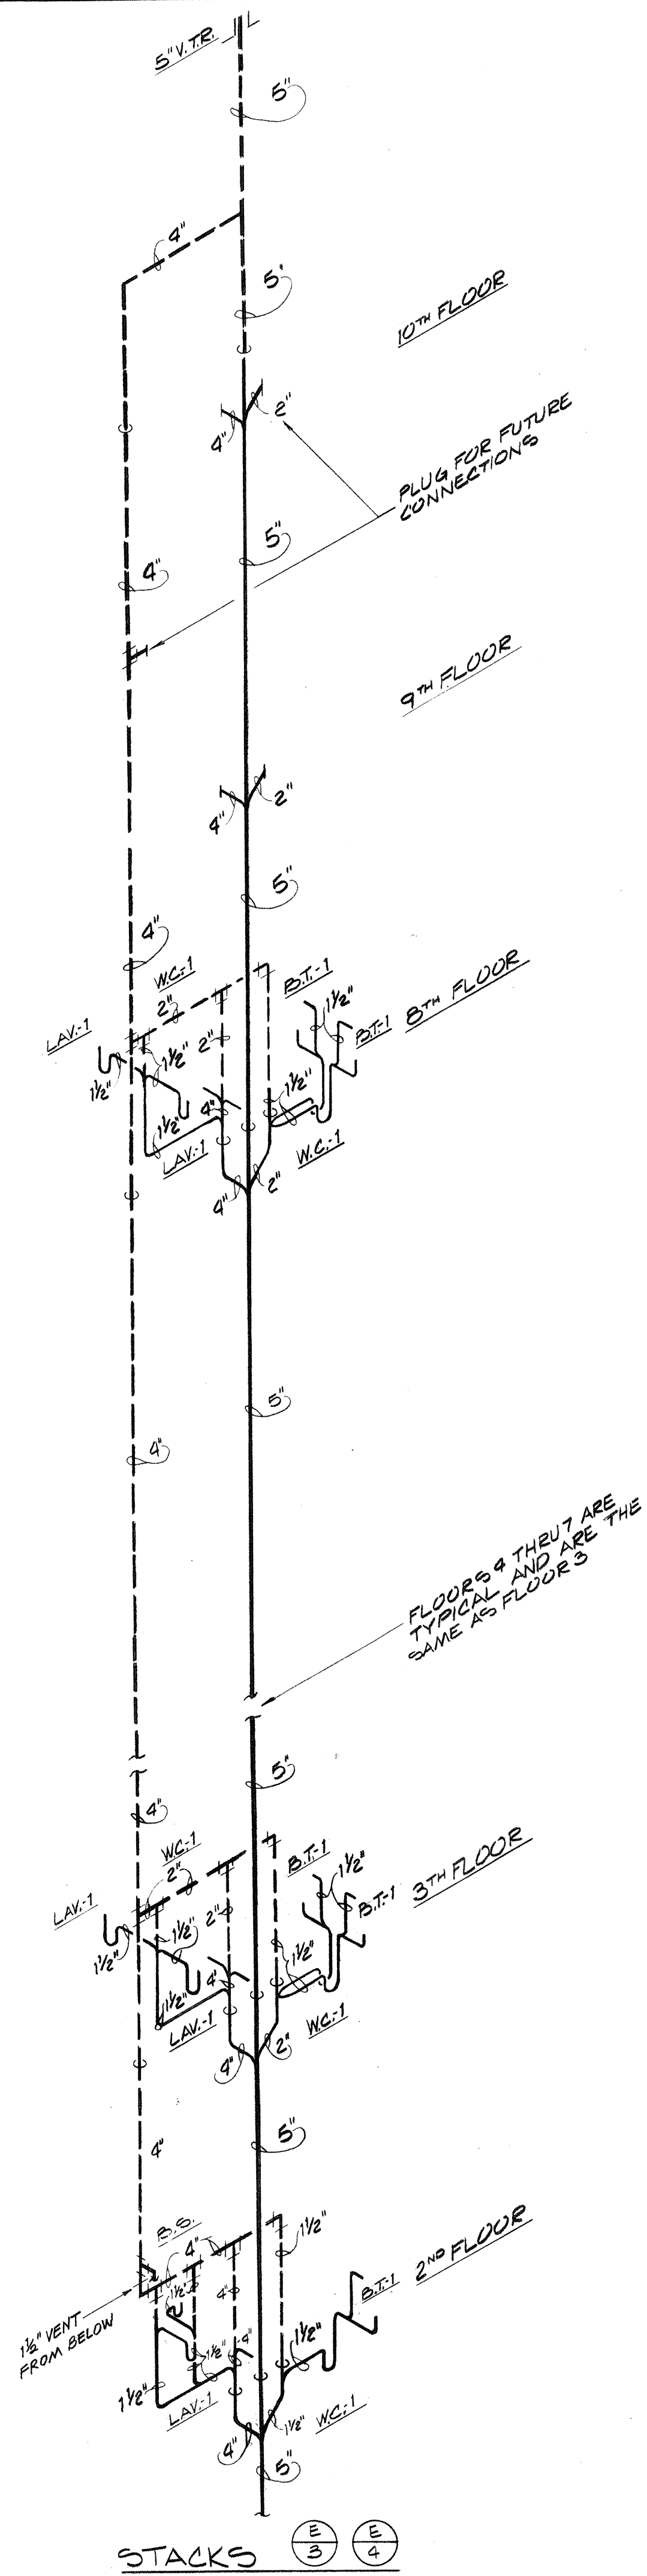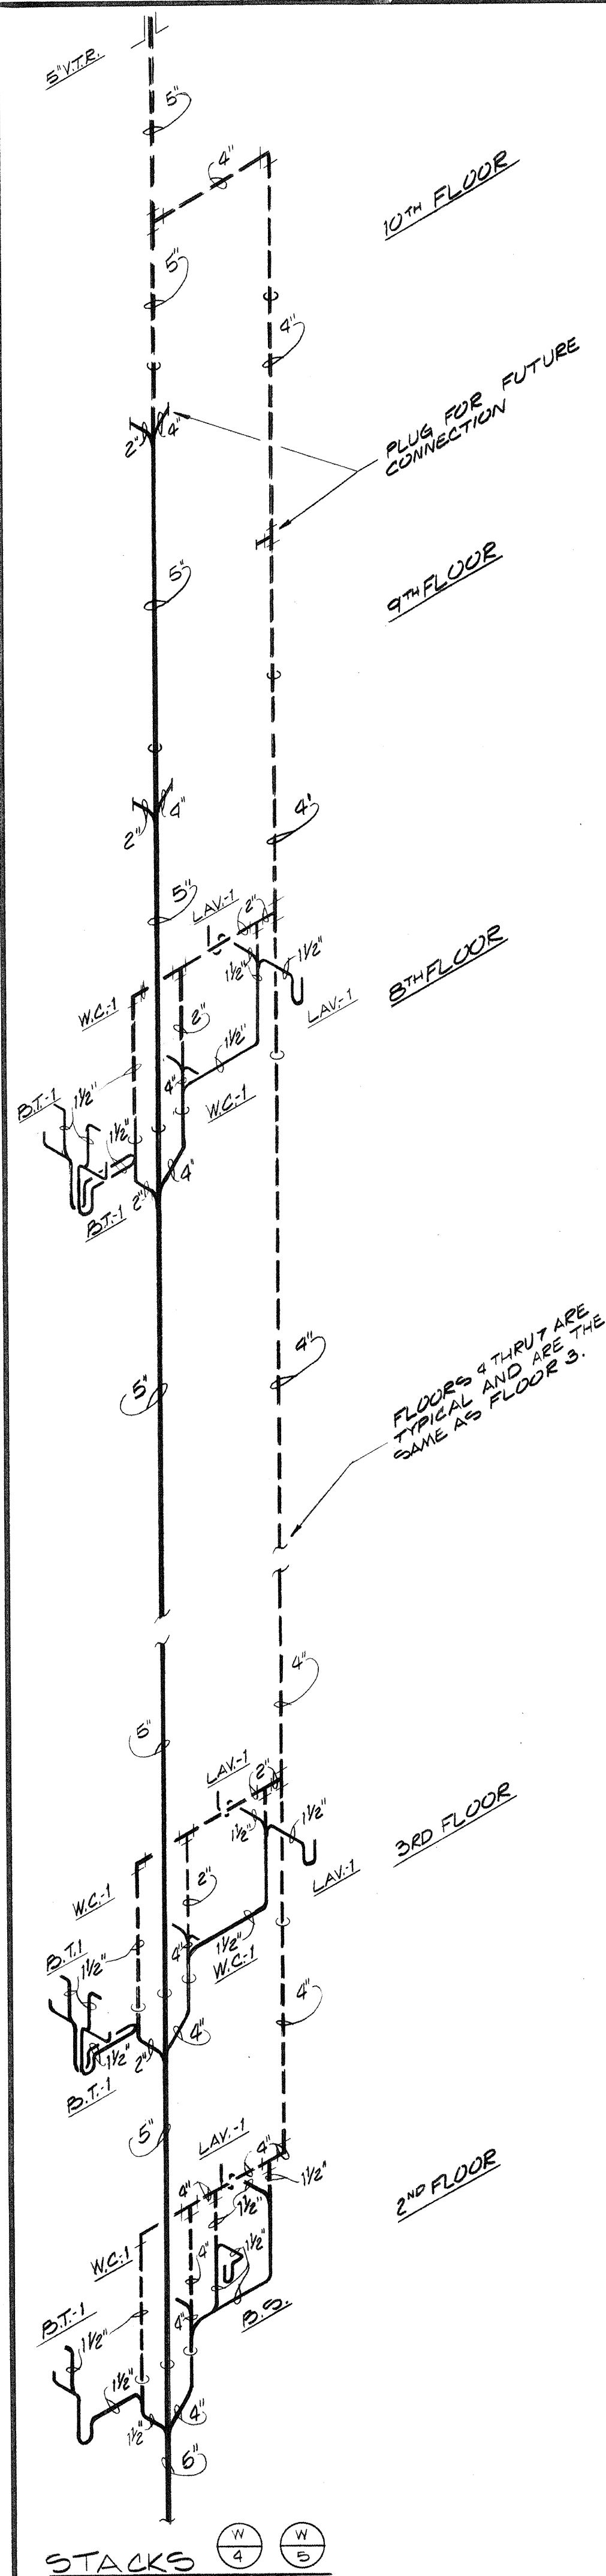

PARTIAL WASTE & VENT PIPING DIAGRAM
NO SCALE

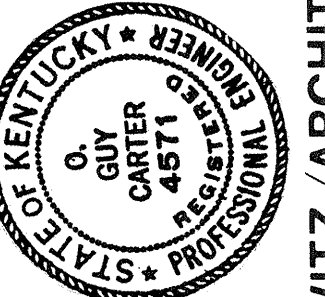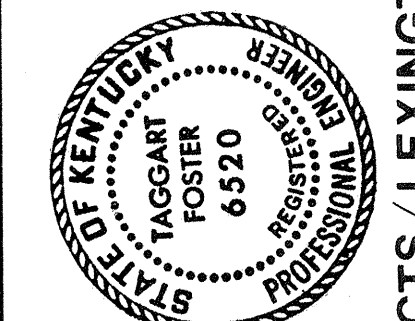

JOHNSON/ROMANOWITZ ARCHITECTS / LEXINGTON / KENTUCKY
301 EAST VINE STREET, SUITE A
TELEPHONE (606) 252-6781

Consulting Engineers
3257 Lochness Drive
Lexington, Kentucky

CARTER - FOSTER INC.


CAPITOL PLAZA HOTEL
FRANKFORT / KENTUCKY

DRAWN	PROJECT
CHECKED	DATE 5-10-83

PLUMBING




PARTIAL WASTE & VENT
PIPING DIAGRAM

DRAWING
P-19

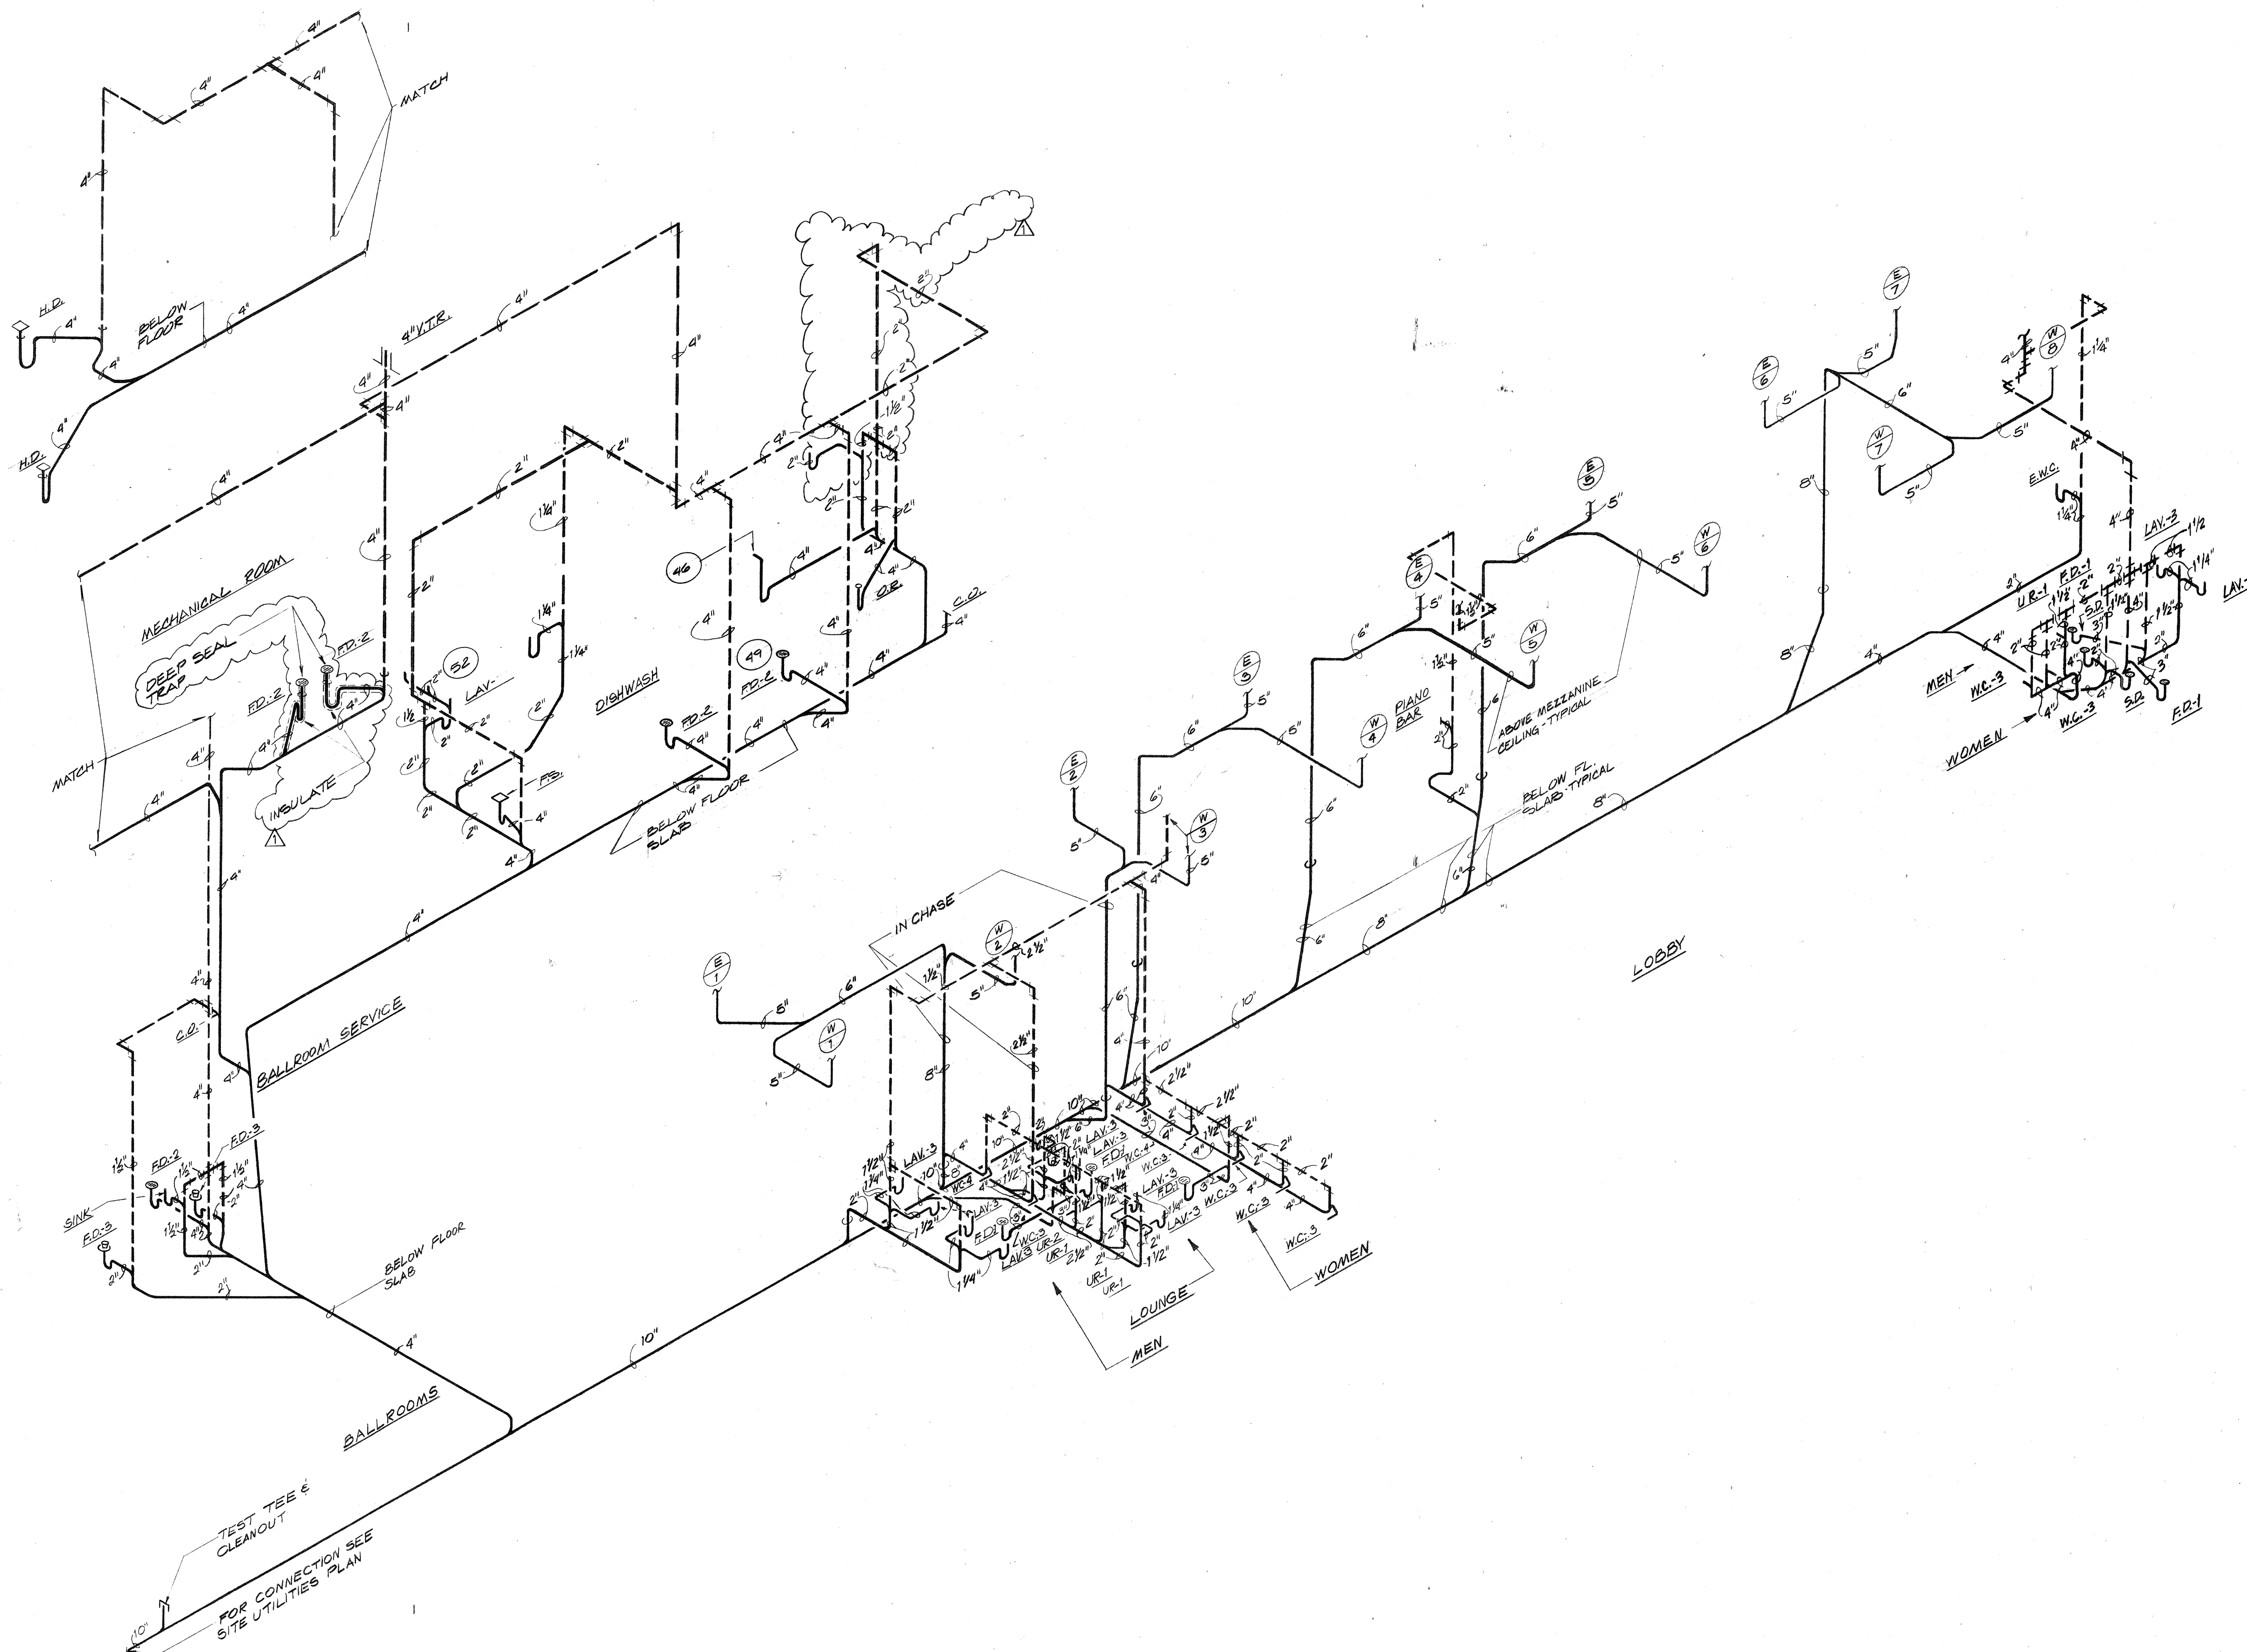

PARTIAL WASTE & VENT PIPING DIAGRAM
NO SCALE

REVISIONS
7-21-83
CHANGED VENT
PIPING & SIZES
ADDED INSULATION
TO DRAIN

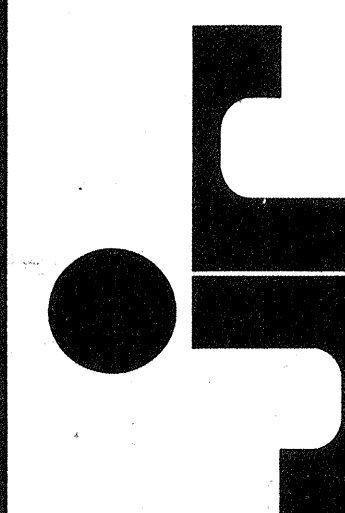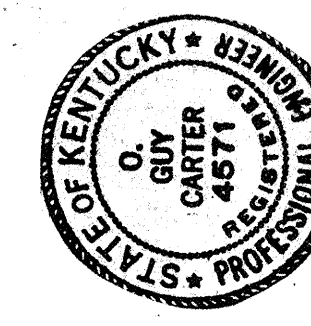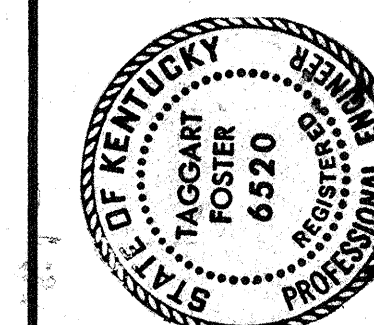

JOHNSON/ROMANOWICZ ARCHITECTS / LEXINGTON / KENTUCKY
301 EAST VINE STREET, SUITE A
LEXINGTON, KENTUCKY 40501
TELEPHONE (606) 252-6781


CARTER - FOSTER INC.

Consulting Engineers
3257 Lochness Drive
Lexington, Kentucky

CAPITOL PLAZA HOTEL
FRANKFORT / KENTUCKY

DRAWN SH	PROJECT
CHECKED T.F.	DATE 5-10-83
PLUMBING	
PARTIAL WASTE & VENT PIPING DIAGRAM	
REISSUED 8-2-83	
DRAWING P-19	

REVISED 7-5-83

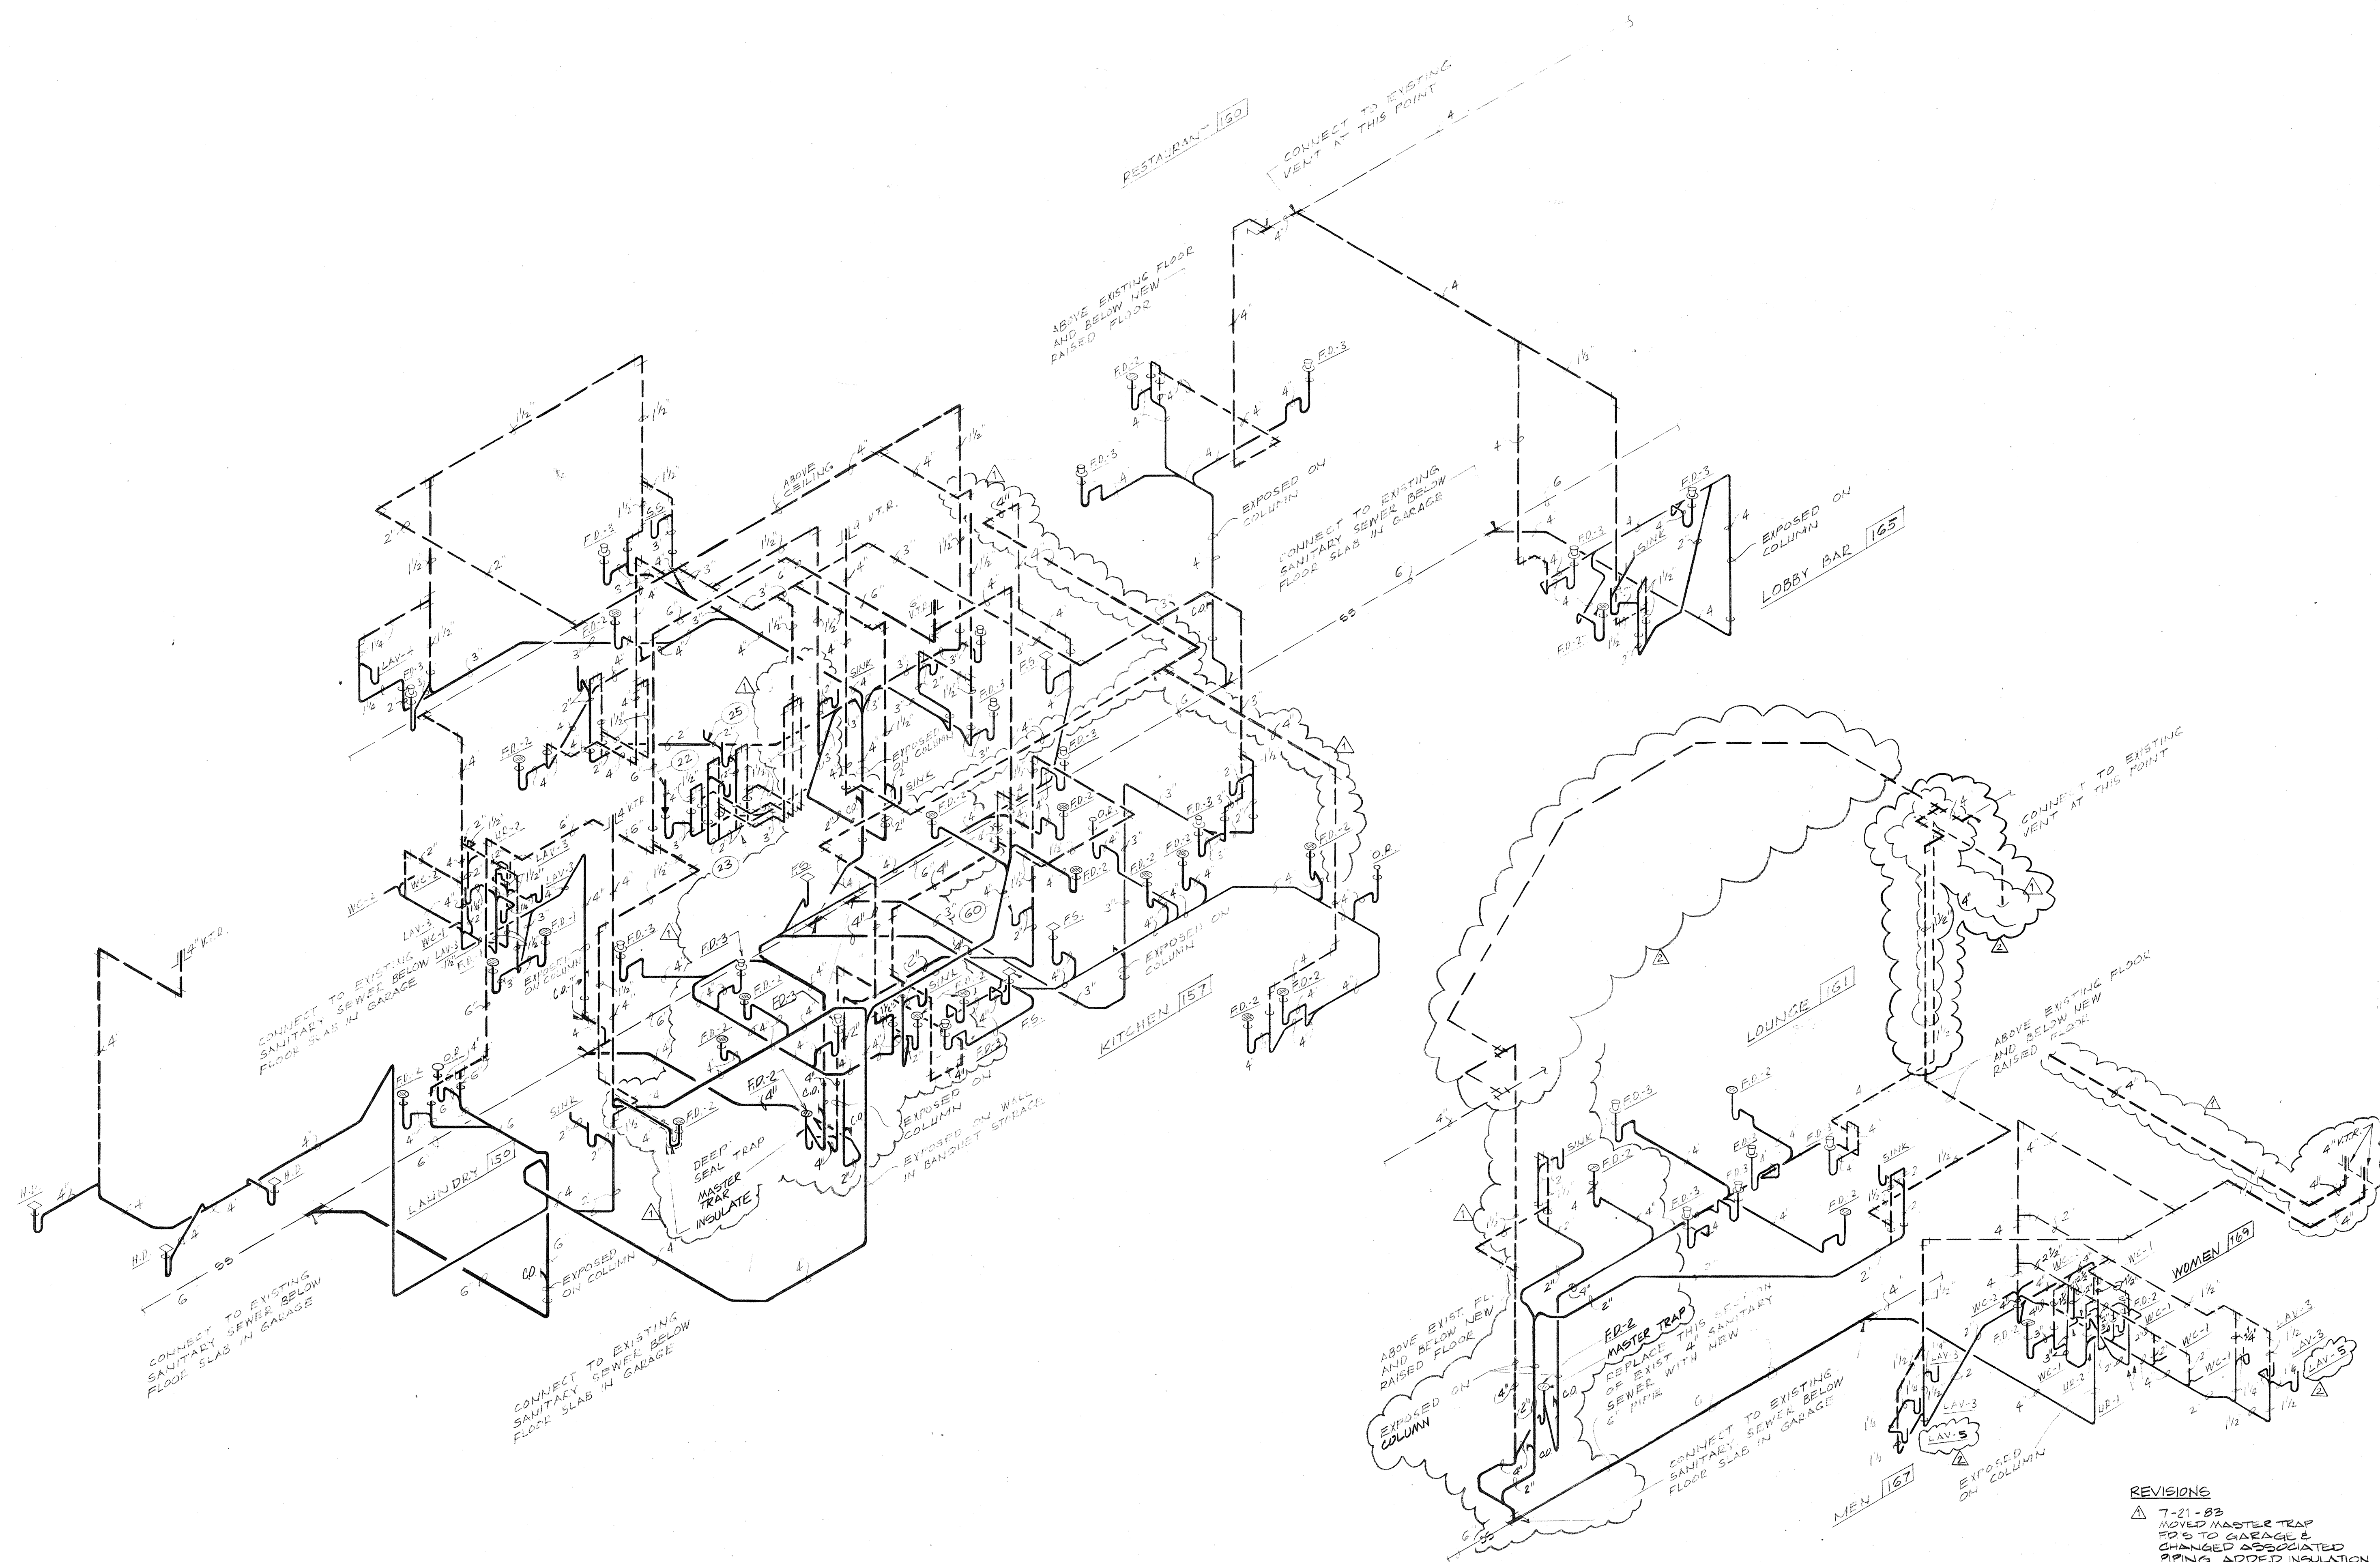

PARTIAL WASTE AND VENT PIPING DIAGRAM
NO SCALE

REVISIONS

- 7-21-83
MOVED MASTER TRAP
FD'S TO GARAGE &
CHANGED ASSOCIATED
PIPING ADDED INSULATION
TO FD
- 9-7-83

DRAWN B.H.	PROJECT
CHECKED T.F.	DATE 6-27-83
PARTIAL WASTE AND VENT PIPING DIAGRAM	
REISSUED 8-2-83	
DRAWING P-20	

CARTER - FOSTER INC.


Consulting Engineers
3257 Lochness Drive
Lexington, Kentucky

CAPITOL PLAZA HOTEL
FRANKFORT / KENTUCKY

STATE OF KENTUCKY
TAGCART
FOSTER
6520
REGISTERED
PROFESSIONAL

STATE OF KENTUCKY
TAGCART
CARTER
4571
REGISTERED
PROFESSIONAL

JOHNSON / ROMANOWITZ / ARCHITECTS / LEXINGTON / KENTUCKY
301 EAST VINE STREET, SUITE A
TELEPHONE (606) 252-6781

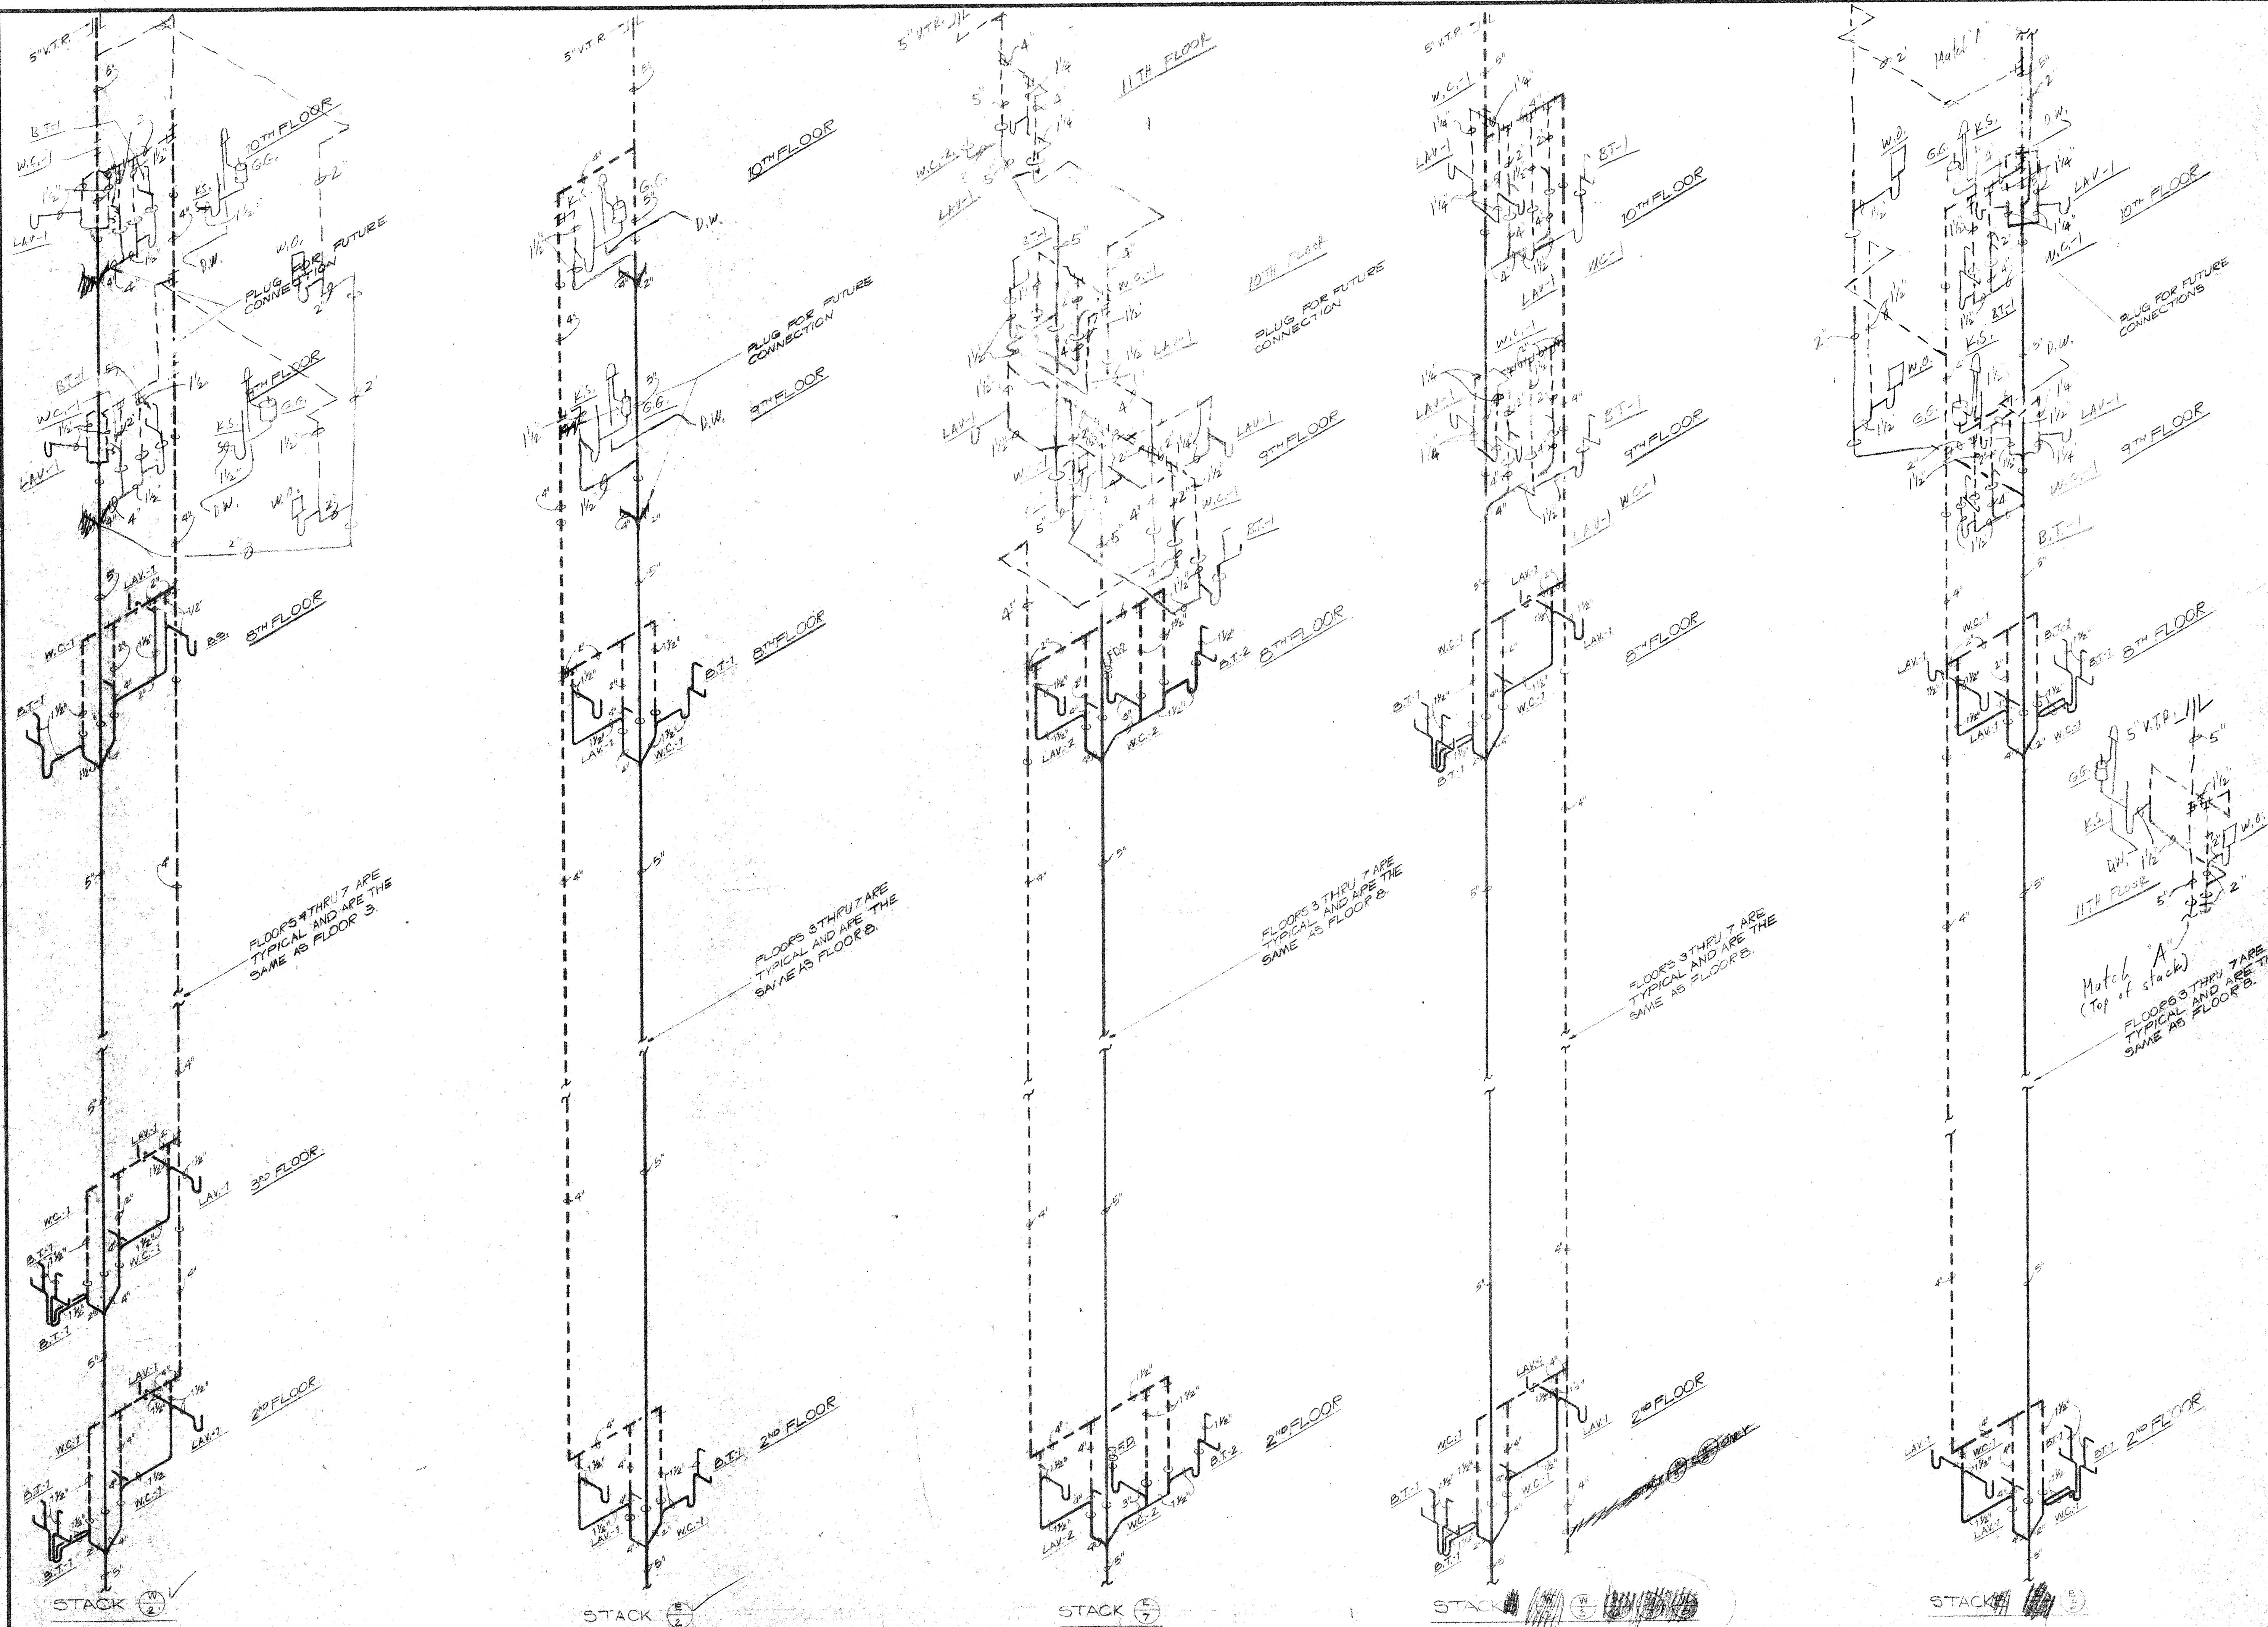

PARTIAL WASTE & VENT PIPING DIAGRAMS
NO SCALE

Consulting Engineers
3257 Lochness Drive
Lexington, Kentucky

CARTER - FOSTER INC.


CAPITOL PLAZA HOTEL
FRANKFORT / KENTUCKY

JOHNSON / ROMANOWITZ / ARCHITECTS / LEXINGTON / KENTUCKY

DRAWN E.H.	PROJECT
CHECKED T.F.	DATE 5-10-83
PLUMBING	
PARTIAL WASTE & VENT PIPING DIAGRAM	
DRAWING P-21	

Dec 12, 1983




REVISED 7-5-83

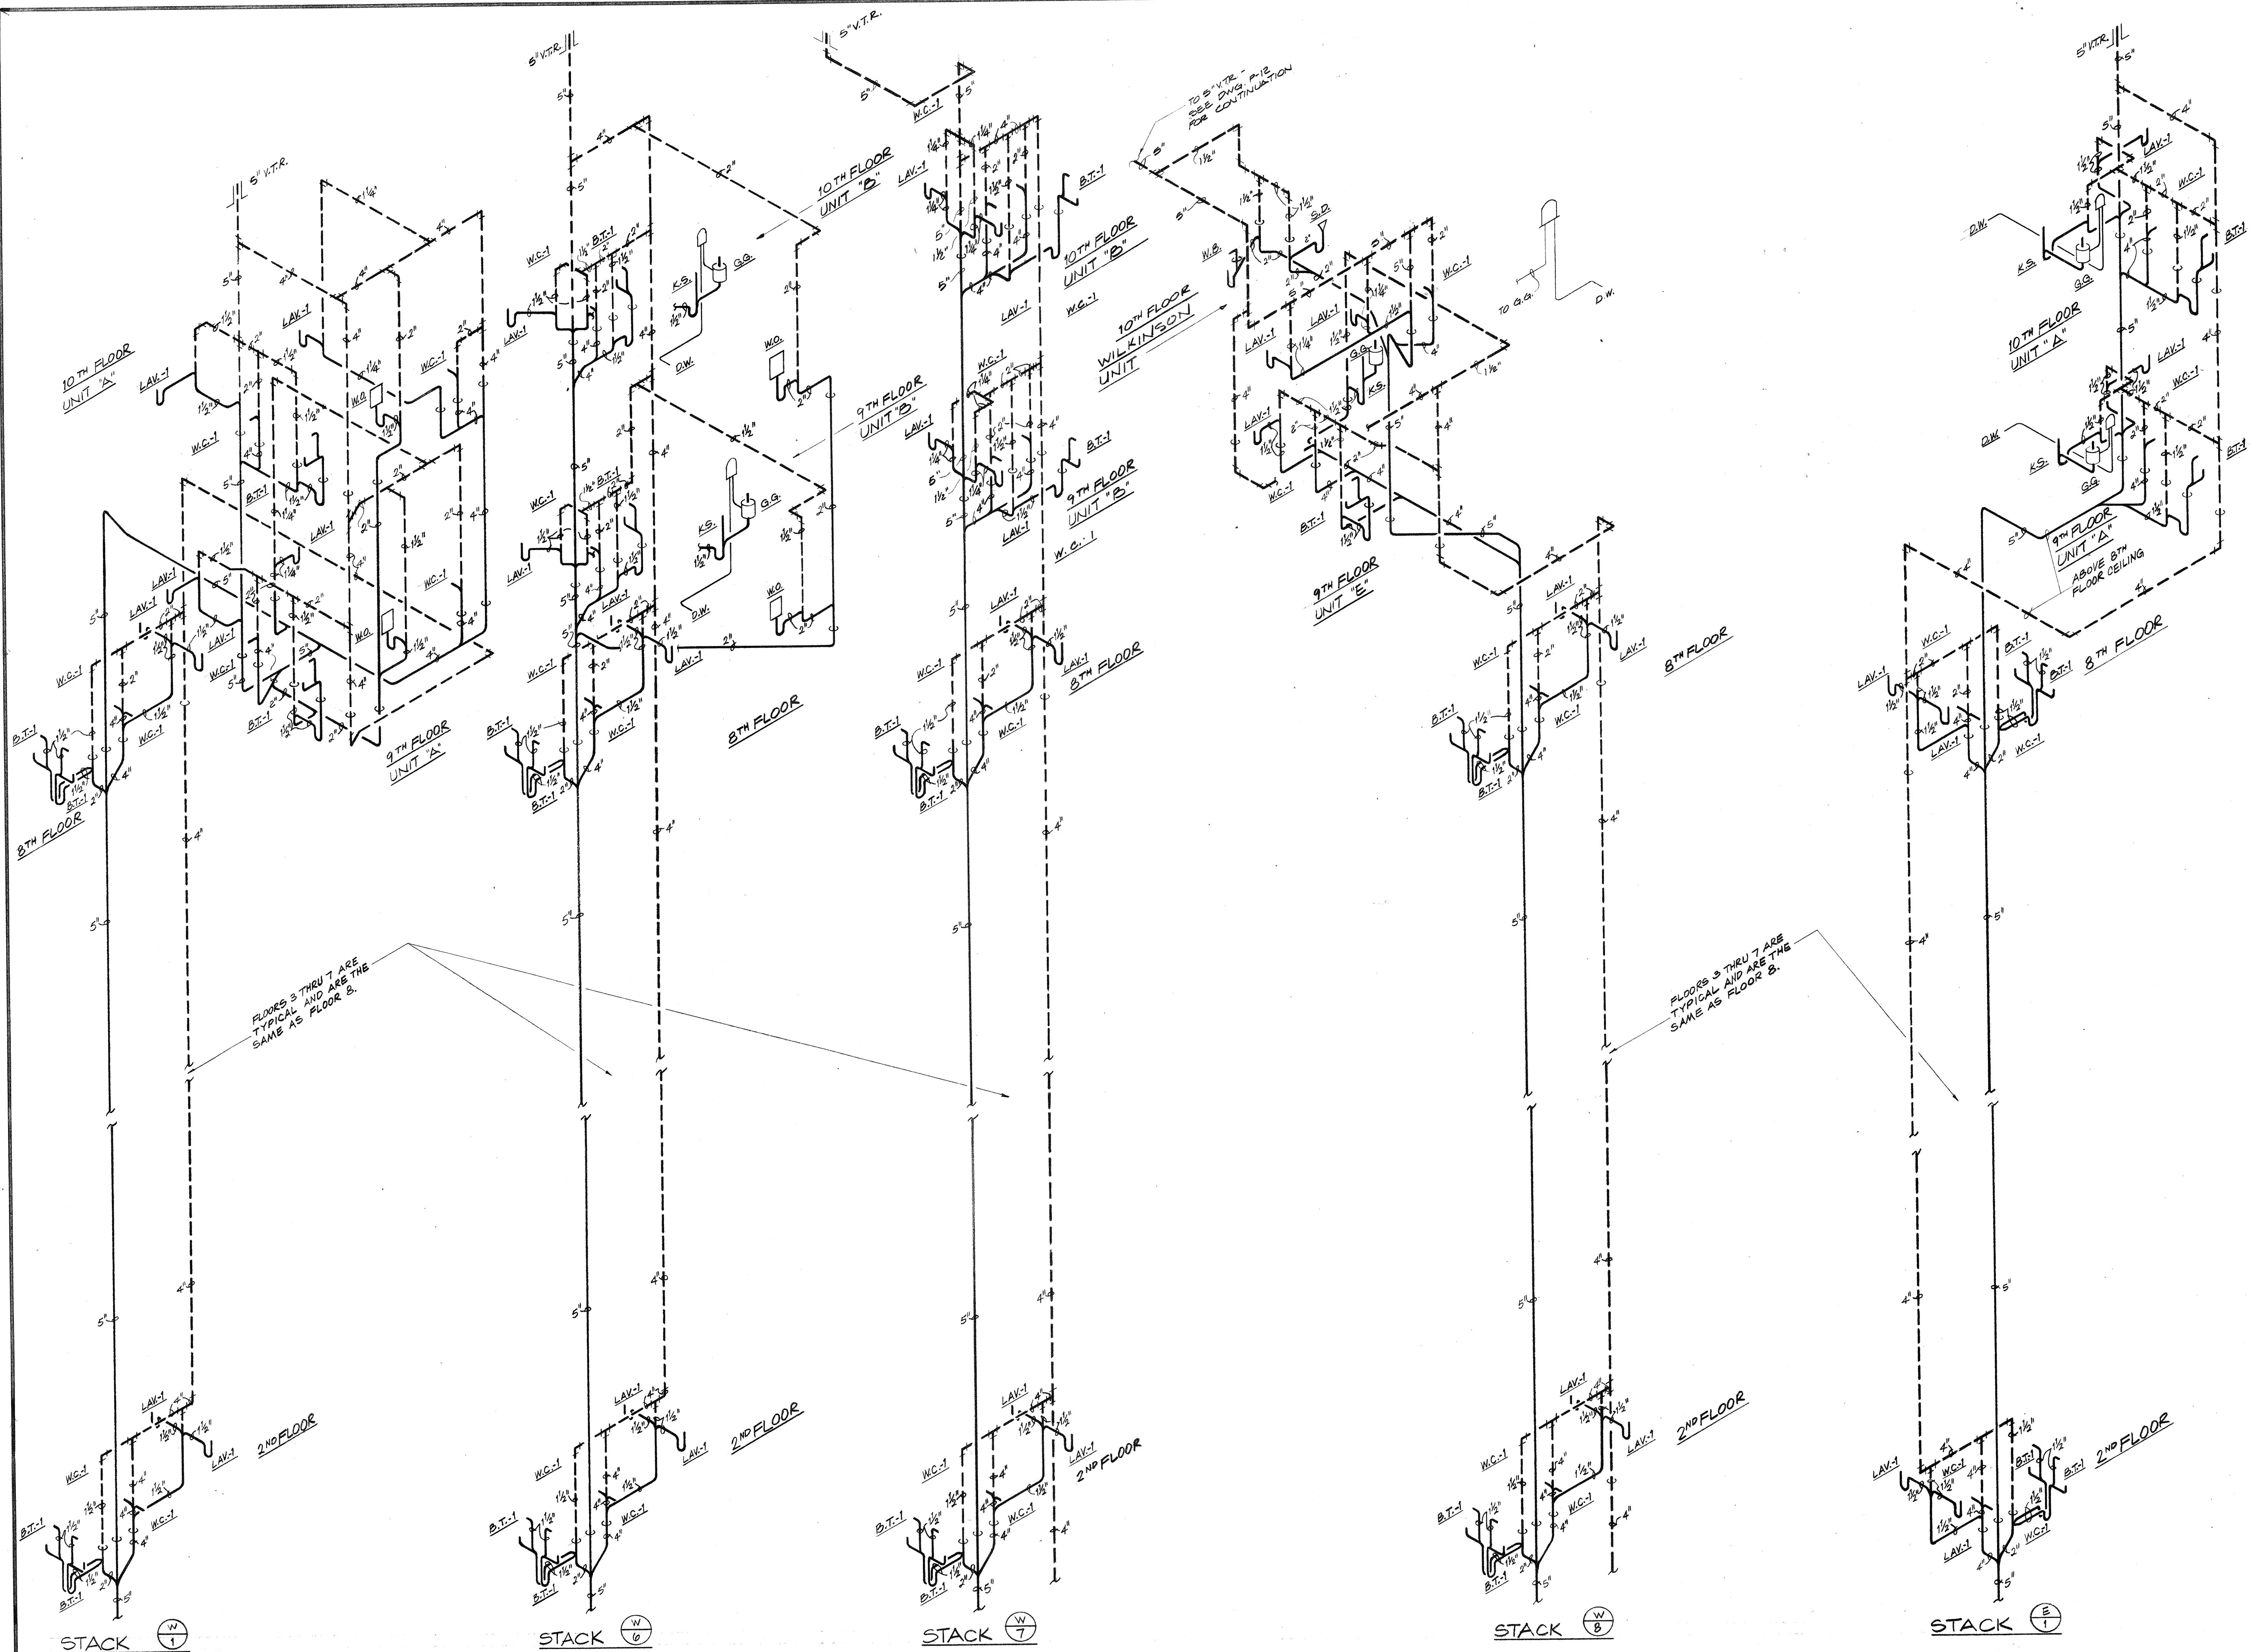

Consulting Engineers
3257 Lochness Drive
Lexington, Kentucky

CARTER - FOSTER INC.

CAPITOL PLAZA HOTEL
FRANKFORT / KENTUCKY

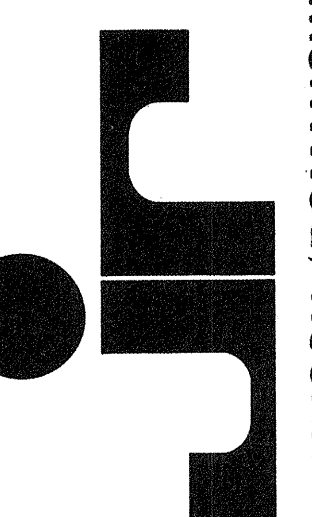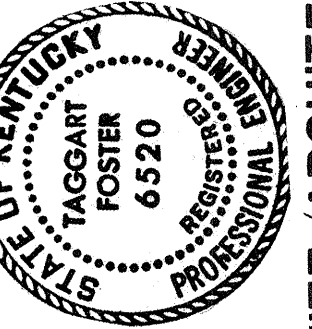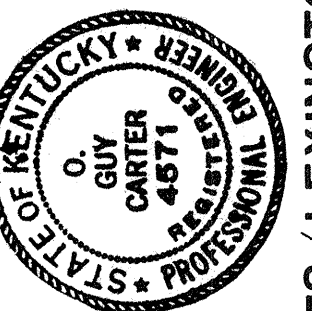

JOHNSON / ROMANOWITZ ARCHITECTS / LEXINGTON / KENTUCKY
301 EAST VINE STREET, SUITE "A"
TELEPHONE (606) 252-6781

DRAWN B.H.	PROJECT
CHECKED T.F.	DATE 1-3-84
PLUMBING	
PARTIAL WASTE & VENT PIPING DIAGRAM	
DRAWING P-21A PRINTED 2-27-84	






NEW DRAWING 1-3-84

10TH FLOOR
B.T.2 5TH FLOOR

FLOORS 3 THRU 7 ARE
TYPICAL AND ARE THE
SAME AS FLOOR 8.

2ND FLOOR
B.T.2

GRAMS

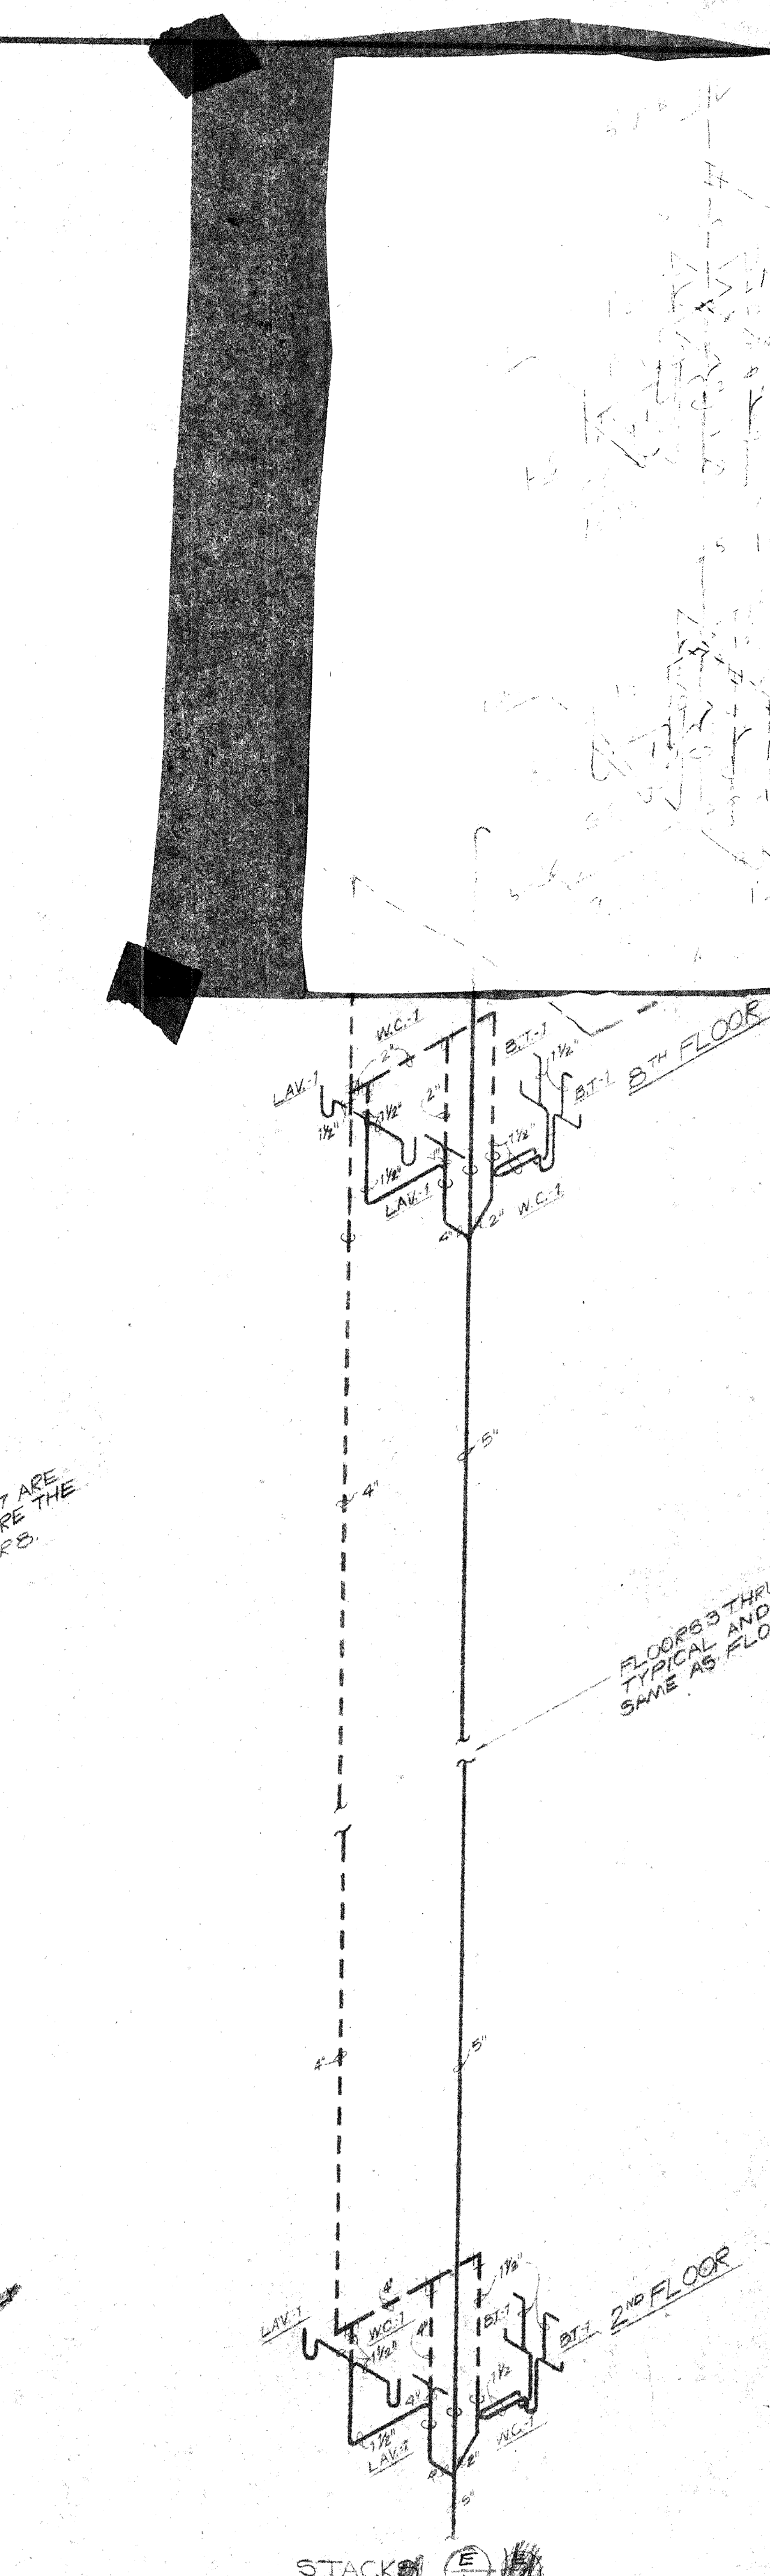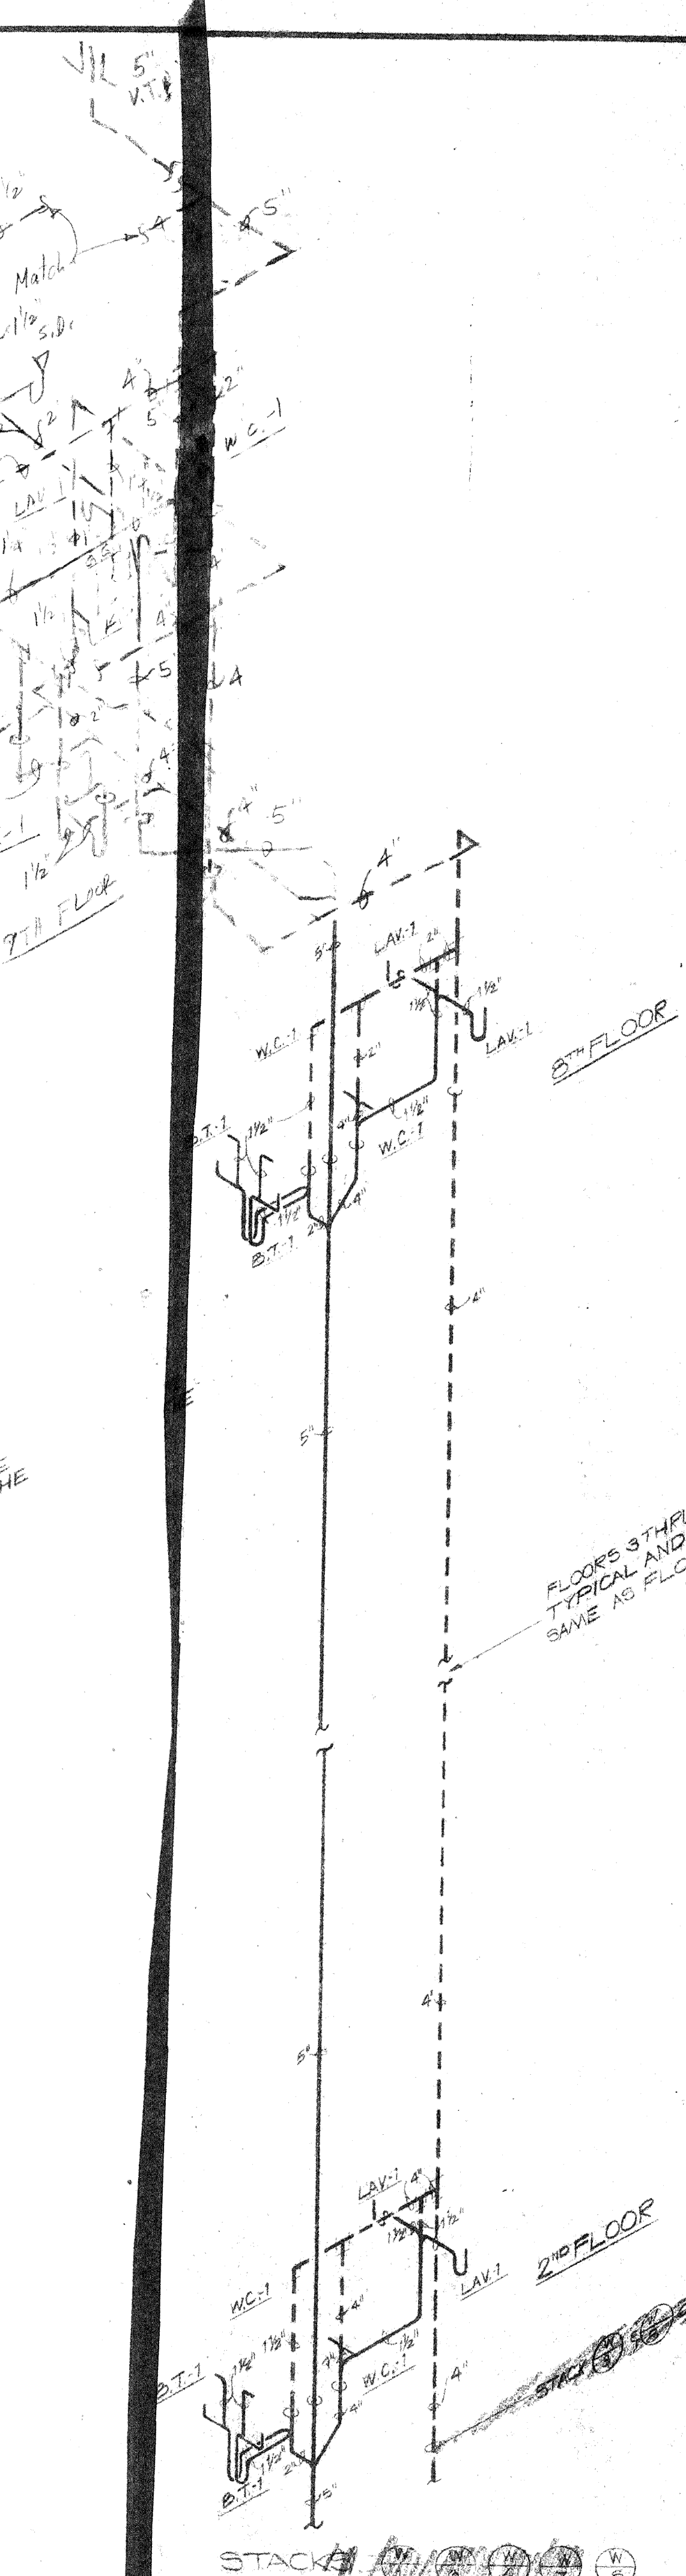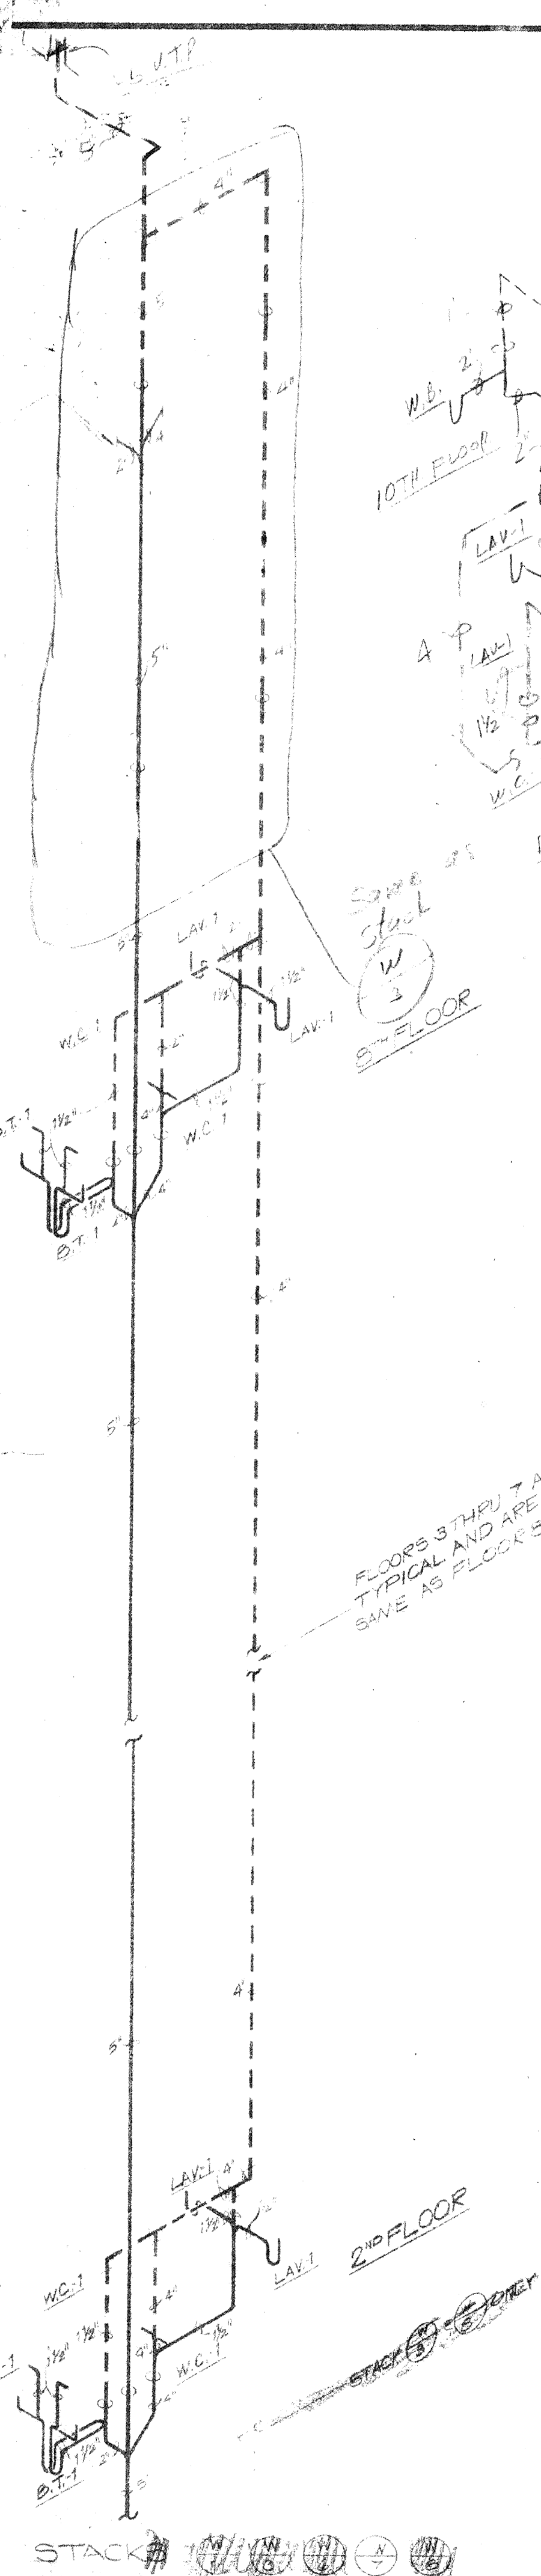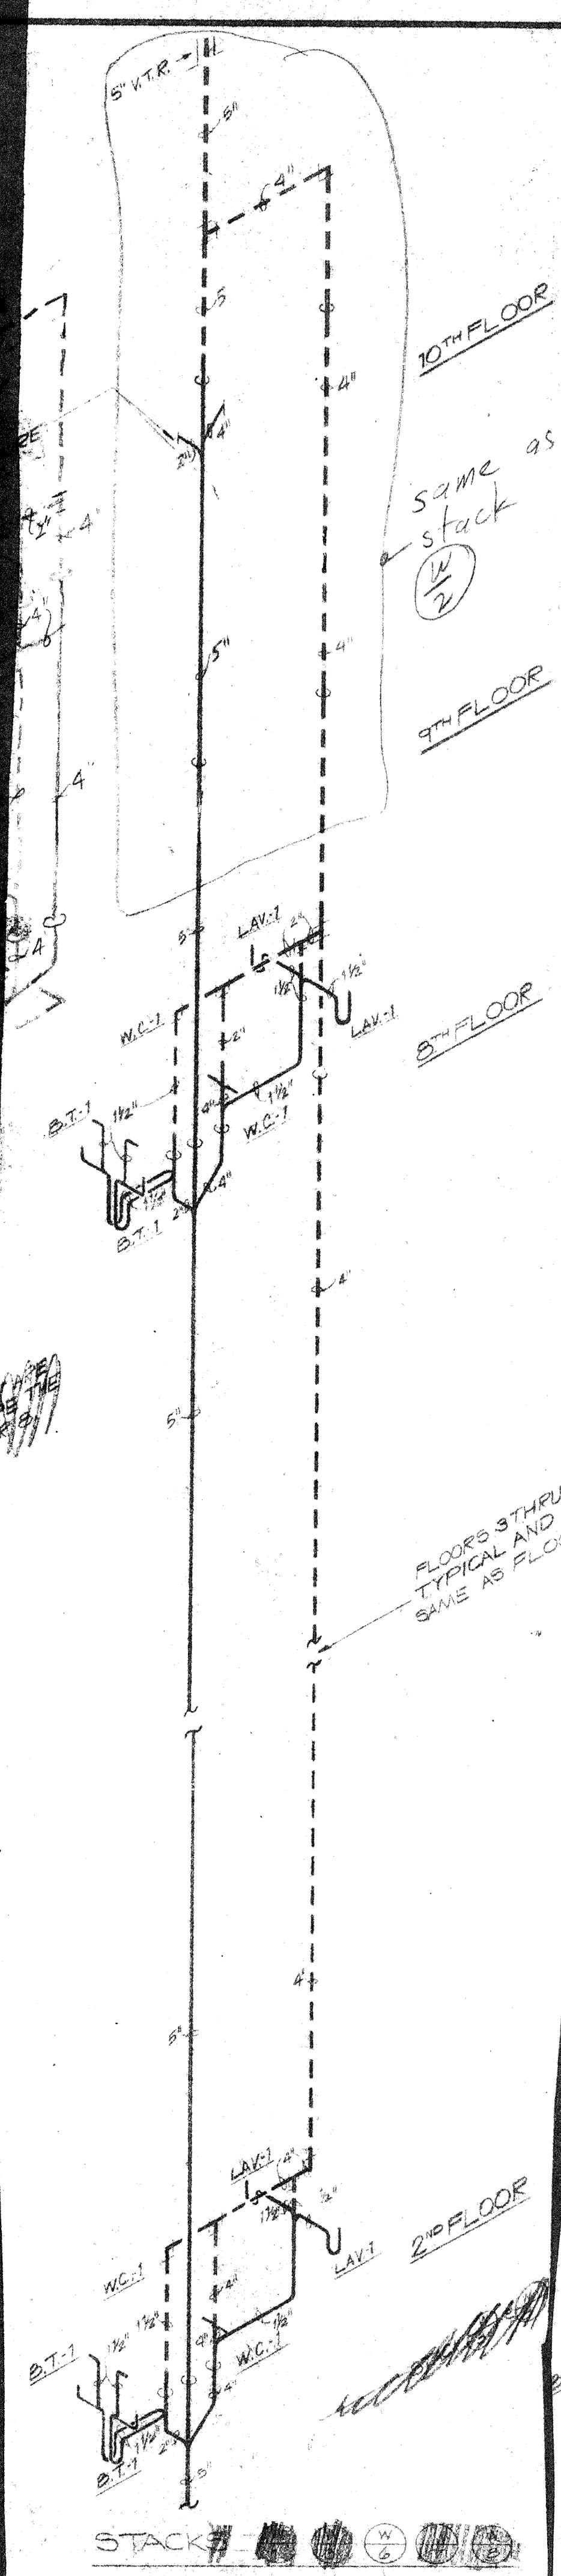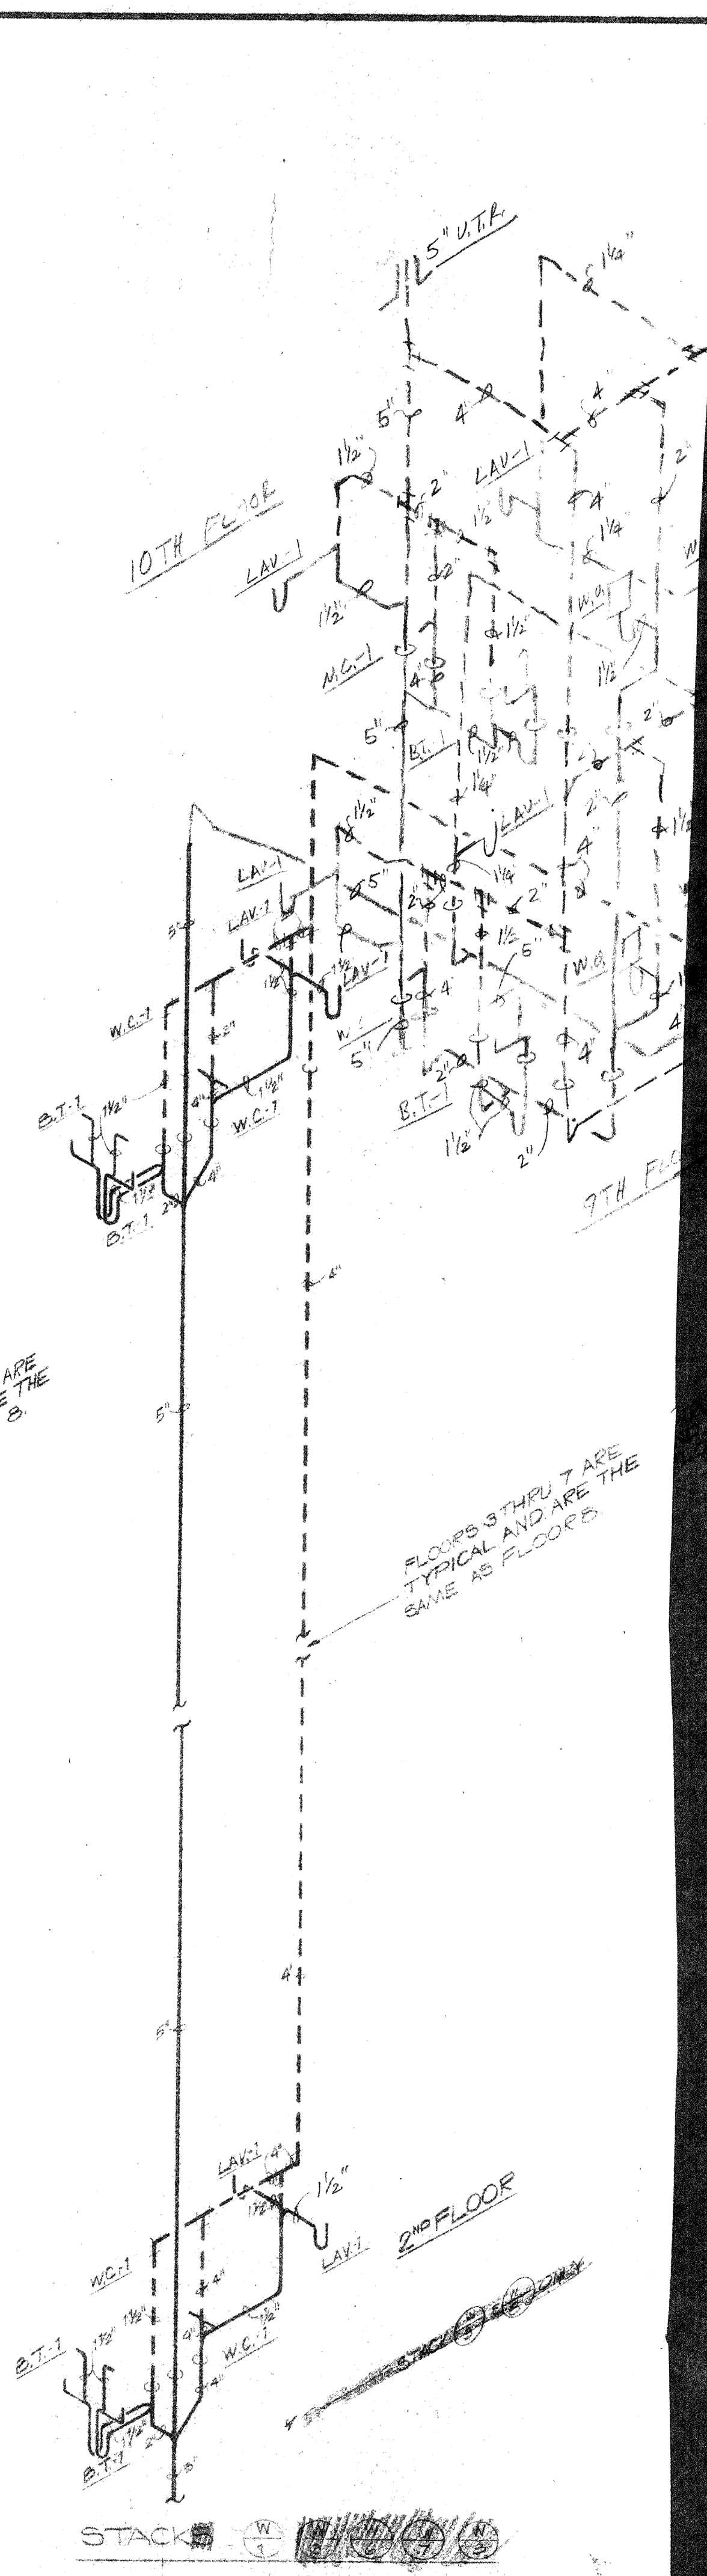

Consulting Engineers
1957 Lakeside Drive
Lexington, Kentucky

CARTER - FOSTER, INC.

CAPITOL PLAZA HOTEL
FRANKFORT / KENTUCKY

JOHNSON / ROMANOWITZ / ARCHITECTS / LEXINGTON / KENTUCKY

Professional Engineer
Kentucky License No. 6350
CARTER - FOSTER, INC.

Professional Engineer
Kentucky License No. 4871
CARTER - FOSTER, INC.


PLUMBING
PARTIAL WASTE &
VENT PIPING DIAGRAM


DRAWING
P-21A

Dec 12, 1983



REVISED 7-5-83

DRAWN R.H.	PROJECT
CHECKED T.F.	DATE 5-10-83

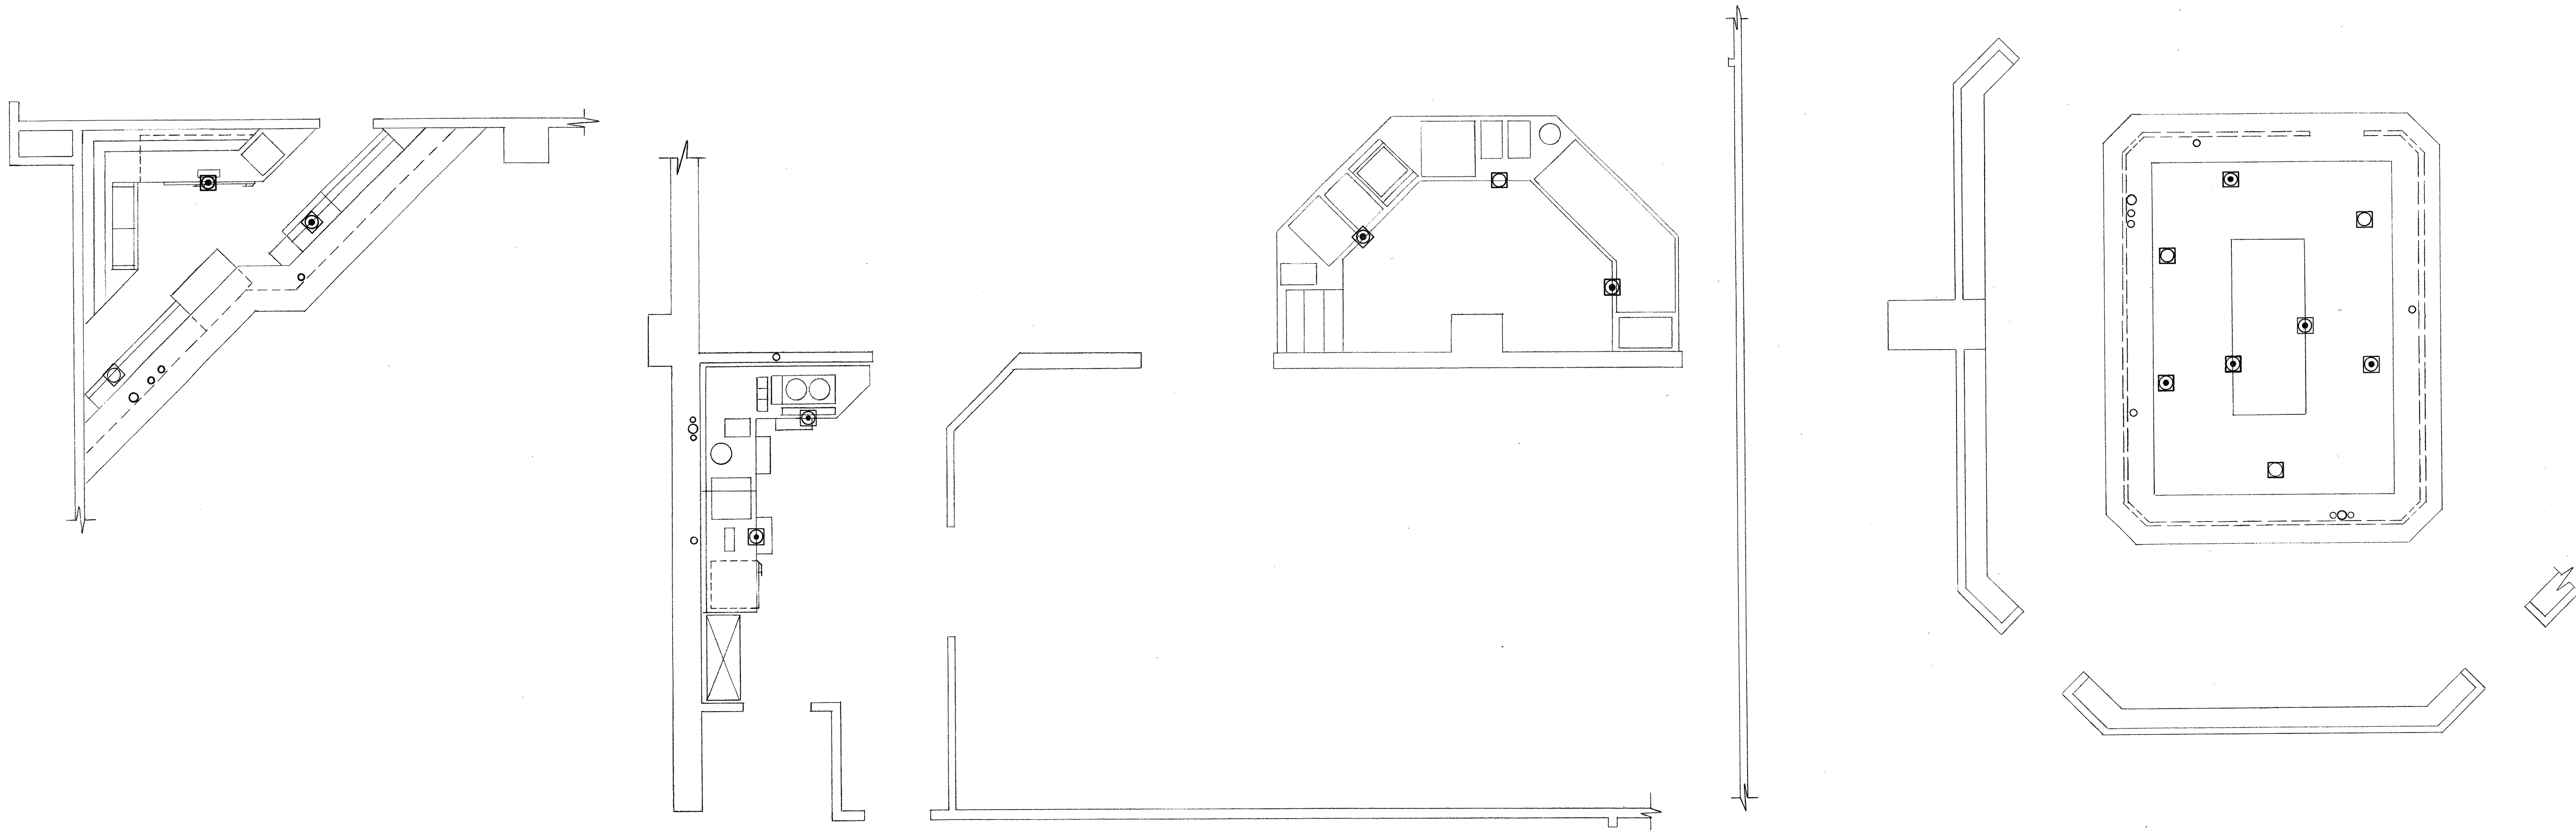

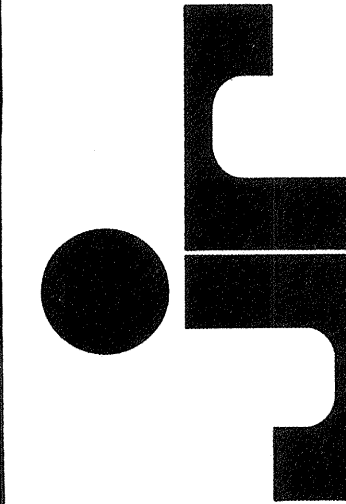

JOHNSON/ROMANOWITZ ARCHITECTS / LEXINGTON, KENTUCKY
301 EAST VINE STREET, SUITE A

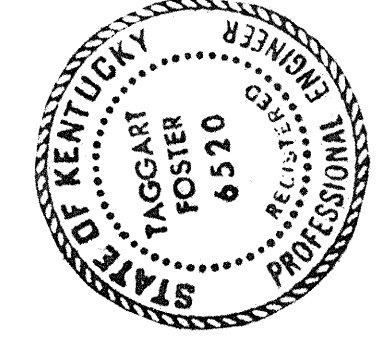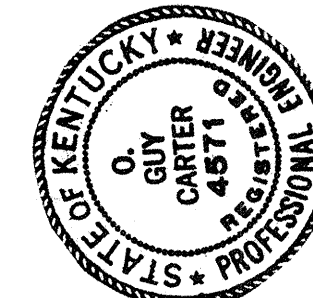


JOHNSON/ROMANOWITZ ARCHITECTS / LEXINGTON, KENTUCKY
301 EAST VINE STREET, SUITE A
TELEPHONE (606) 252-6781

CARTER - FOSTER INC.
Consulting Engineers
3257 Lochness Drive
Lexington, Kentucky

CAPITOL PLAZA HOTEL
FRANKFORT / KENTUCKY

DRAWN	PROJECT
CHECKED	DATE 5-10-83
PLUMBING	
ENLARGED PLUMBING PLANS - SPECIALTY AREAS	
DRAWING P-21	

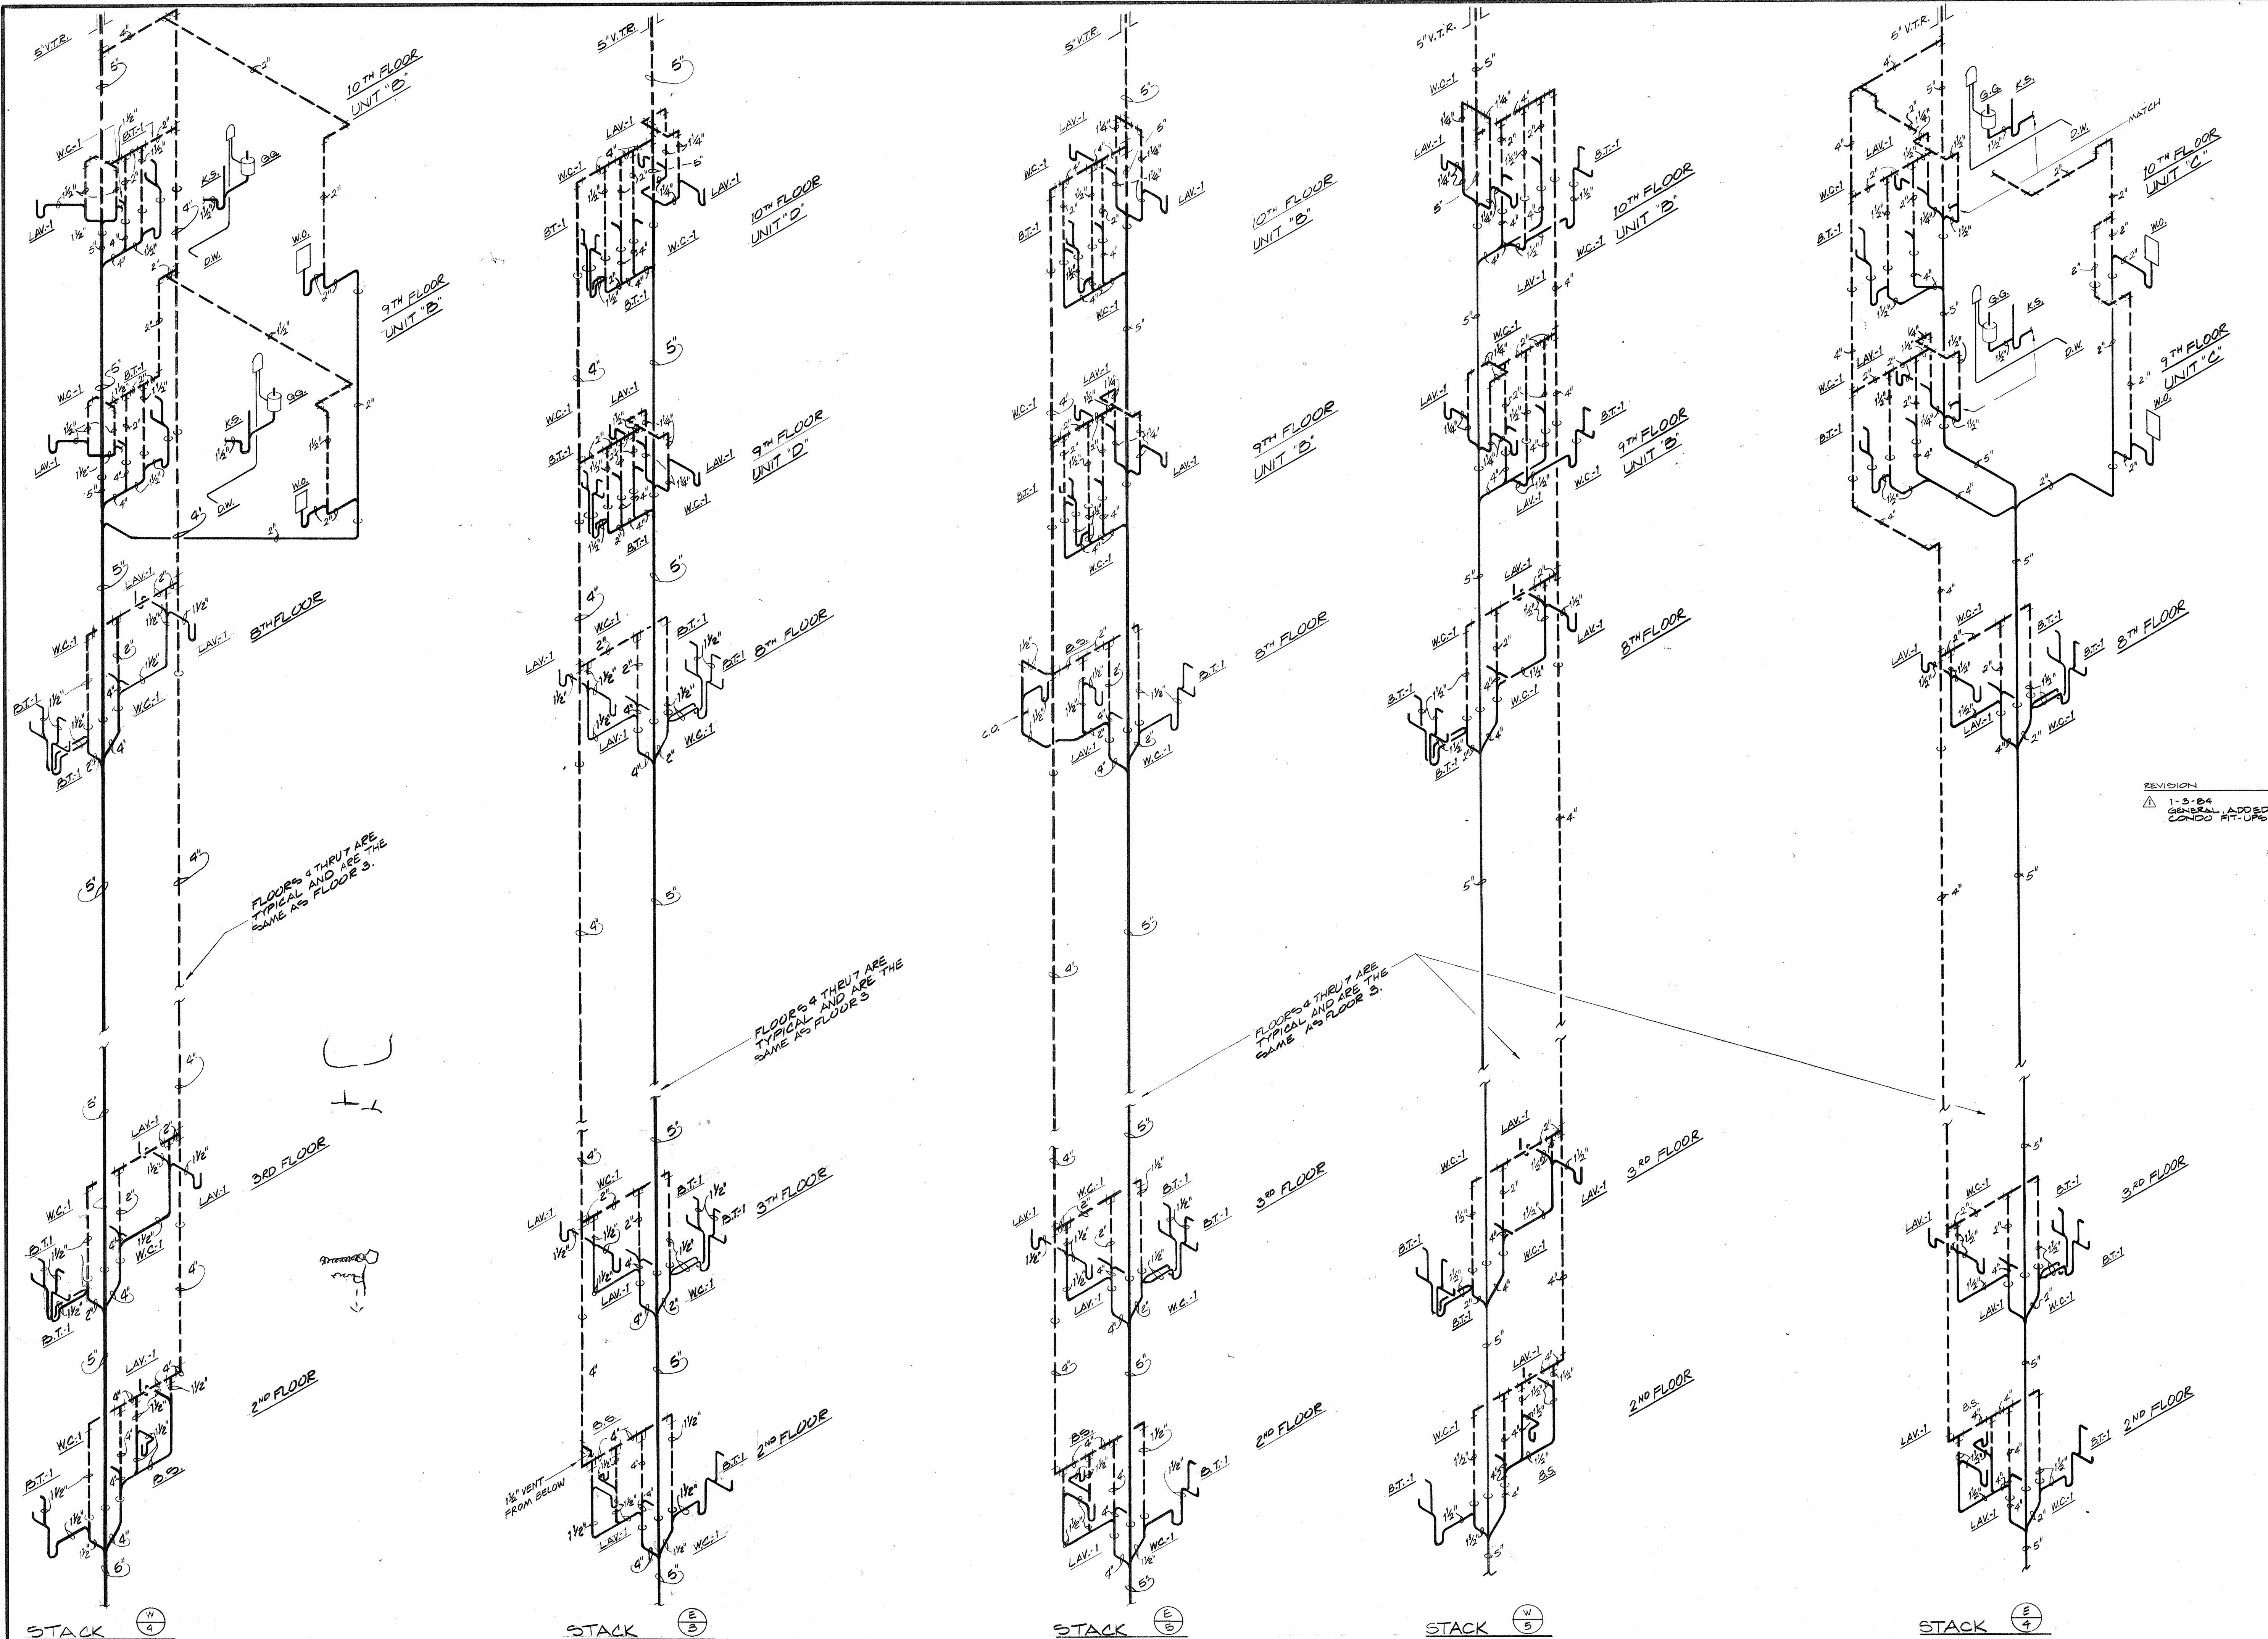

Consulting Engineers
3257 Lochness Drive
Lexington, Kentucky

CARTER - FOSTER INC.


CAPITOL PLAZA HOTEL
FRANKFORT / KENTUCKY

JOHNSON / ROMANOWITZ / ARCHITECTS / LEXINGTON / KENTUCKY
301 EAST VINE STREET, SUITE A
TELEPHONE 1606 / 252-6781




REGISTERED PROFESSIONAL ENGINEER
STATE OF KENTUCKY
CARTER
4571

REGISTERED PROFESSIONAL ARCHITECT
STATE OF KENTUCKY
ROMANOWITZ
6320


DRAWN B.H.	PROJECT
CHECKED T.F.	DATE 5-10-83
PLUMBING	
PARTIAL WASTE & VENT PIPING DIAGRAM	
DRAWING P-22	
PRINTED 2-27-84 REVISED 7-5-83	

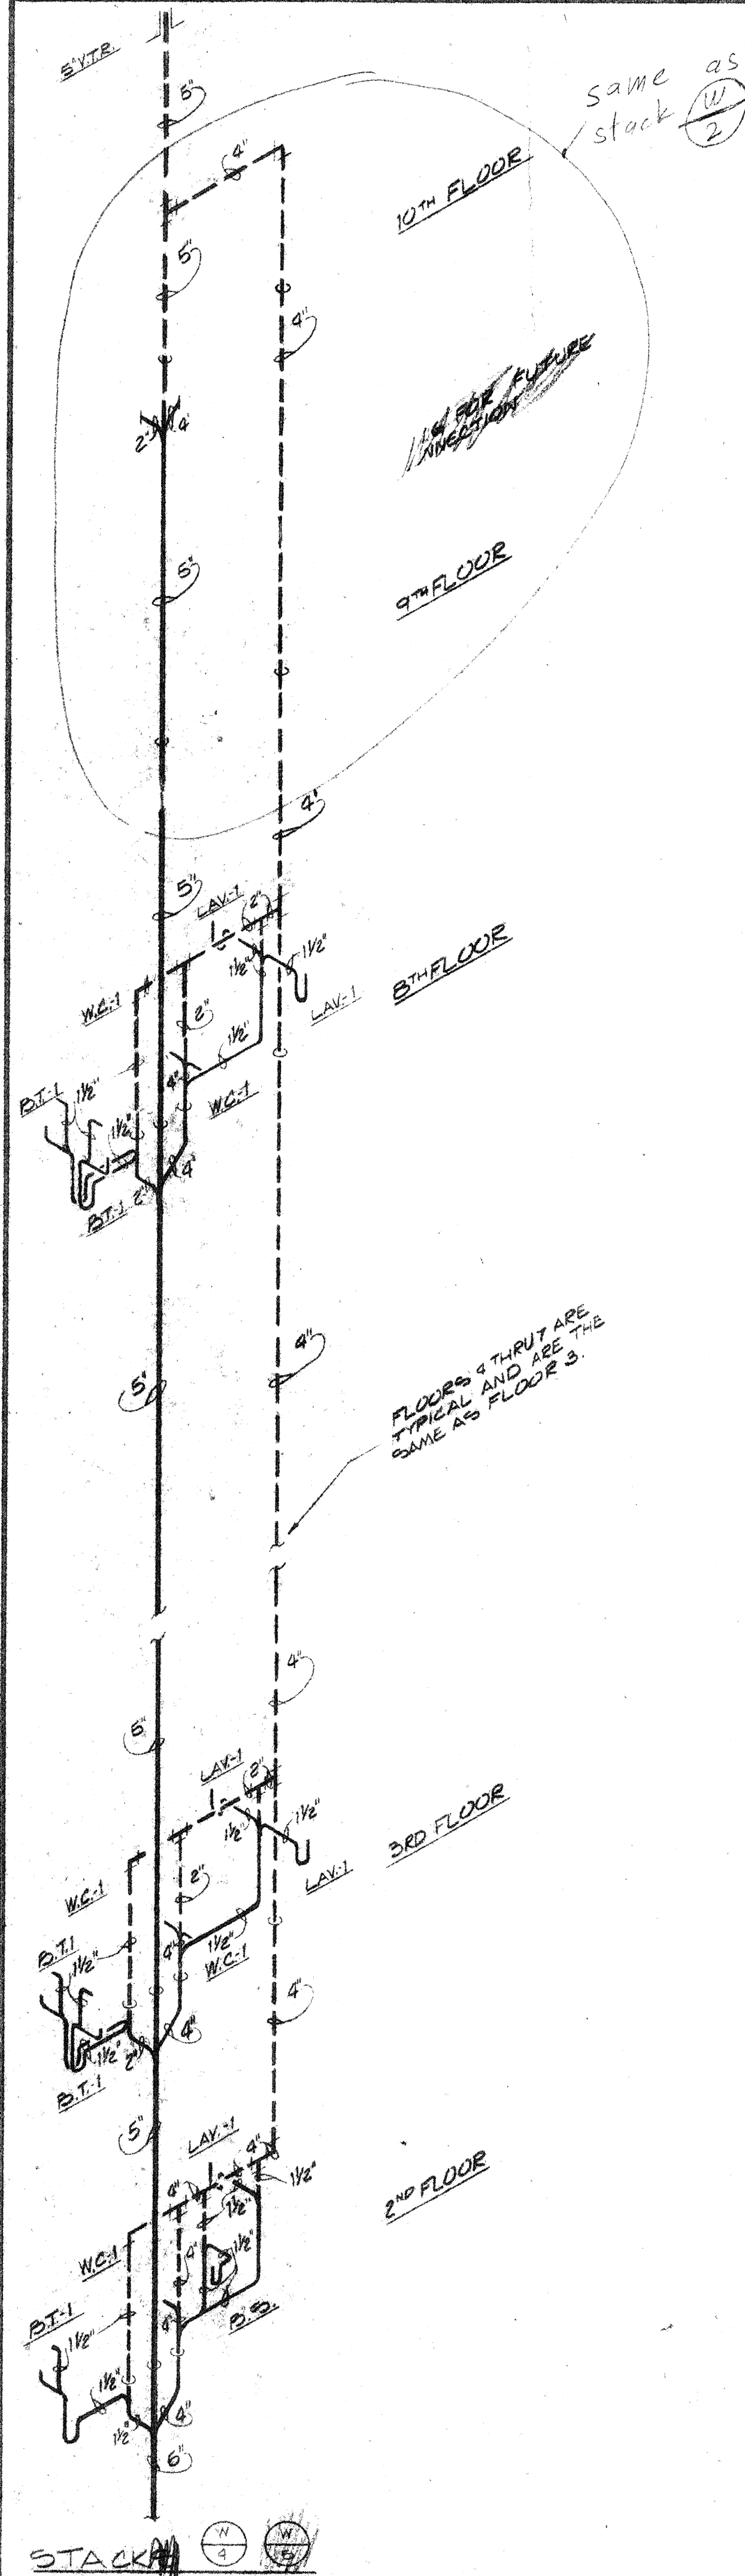

PARTIAL WASTE & VENT PIPING DIAGRAM
NO SCALE

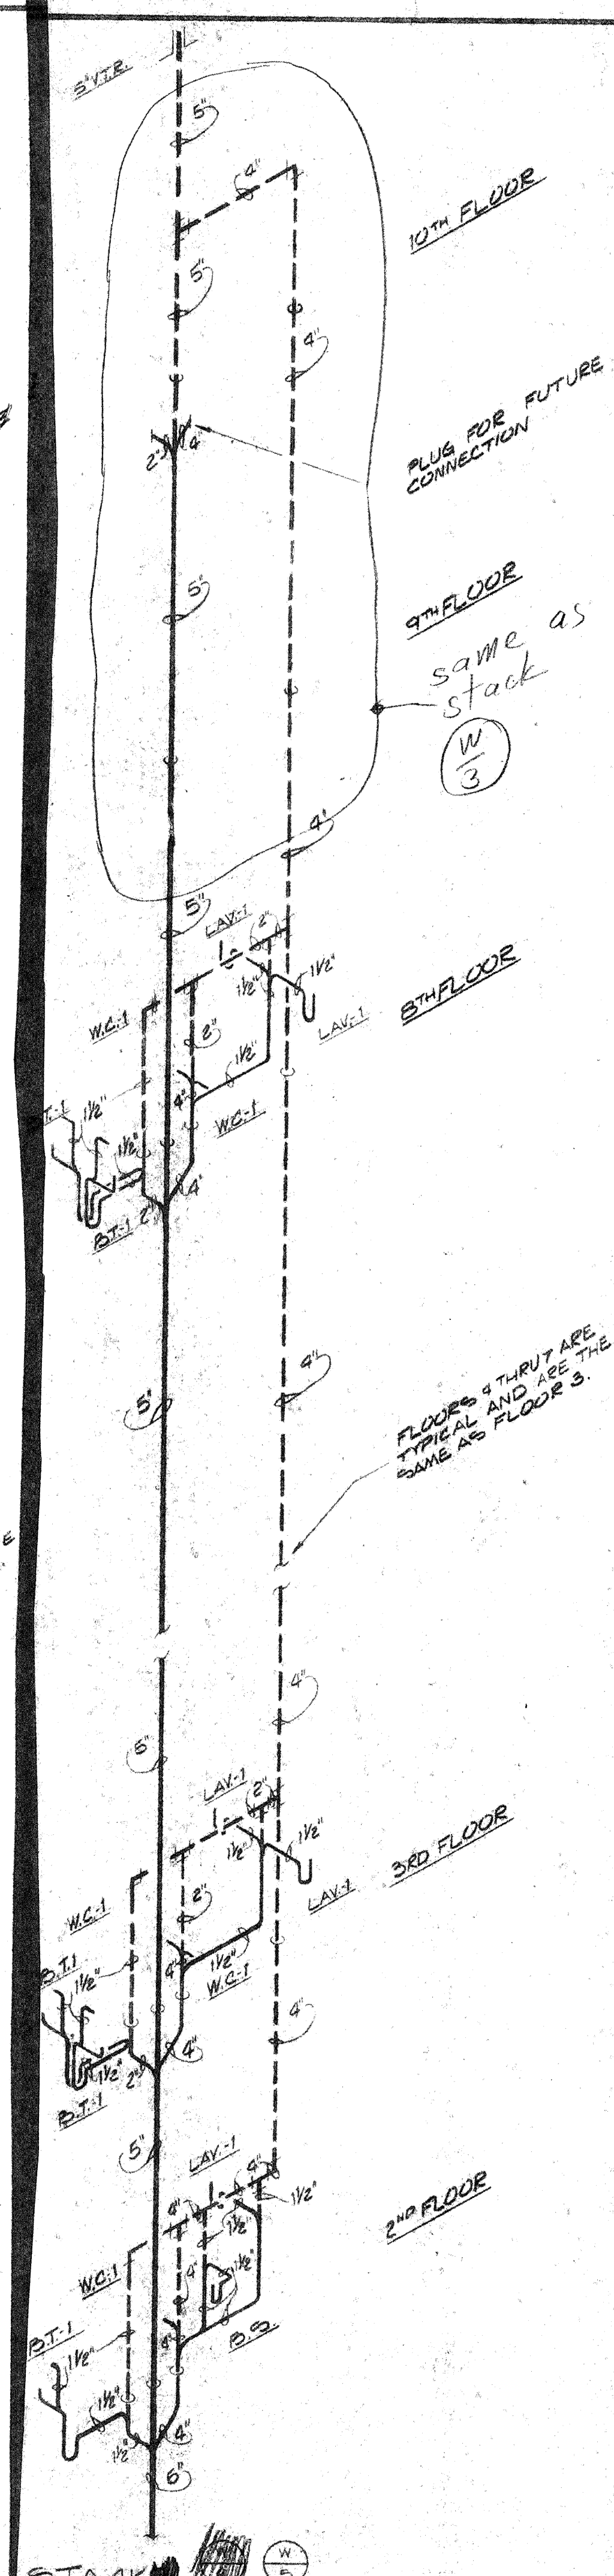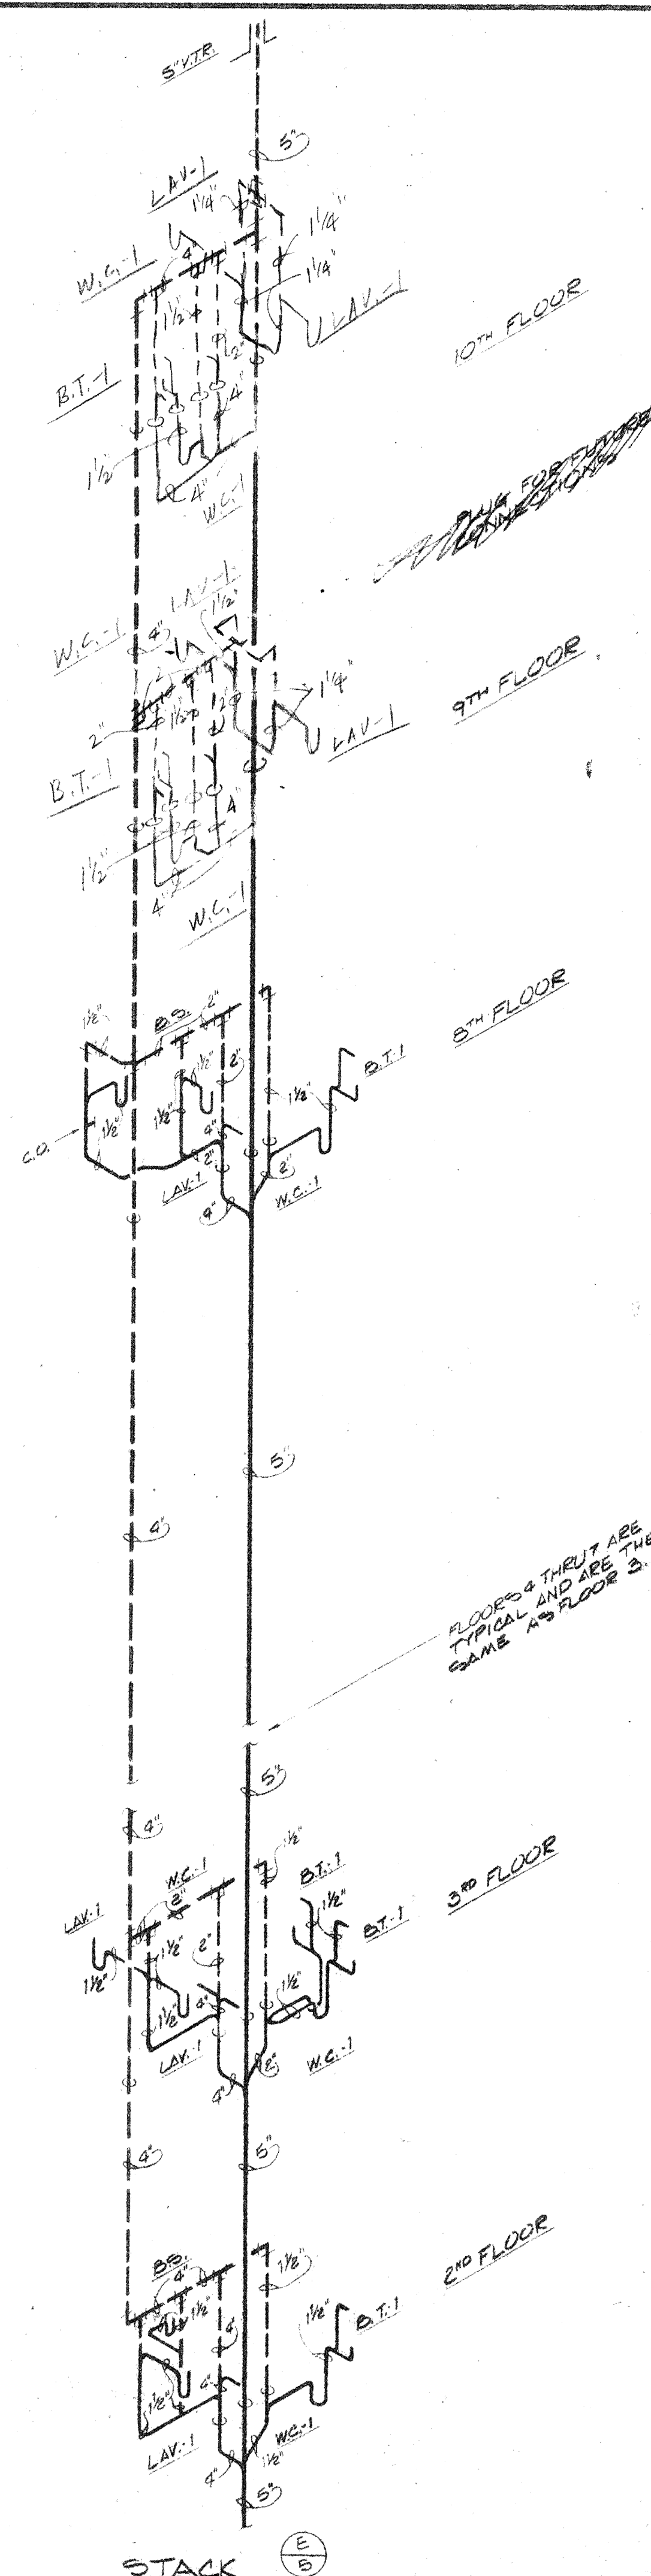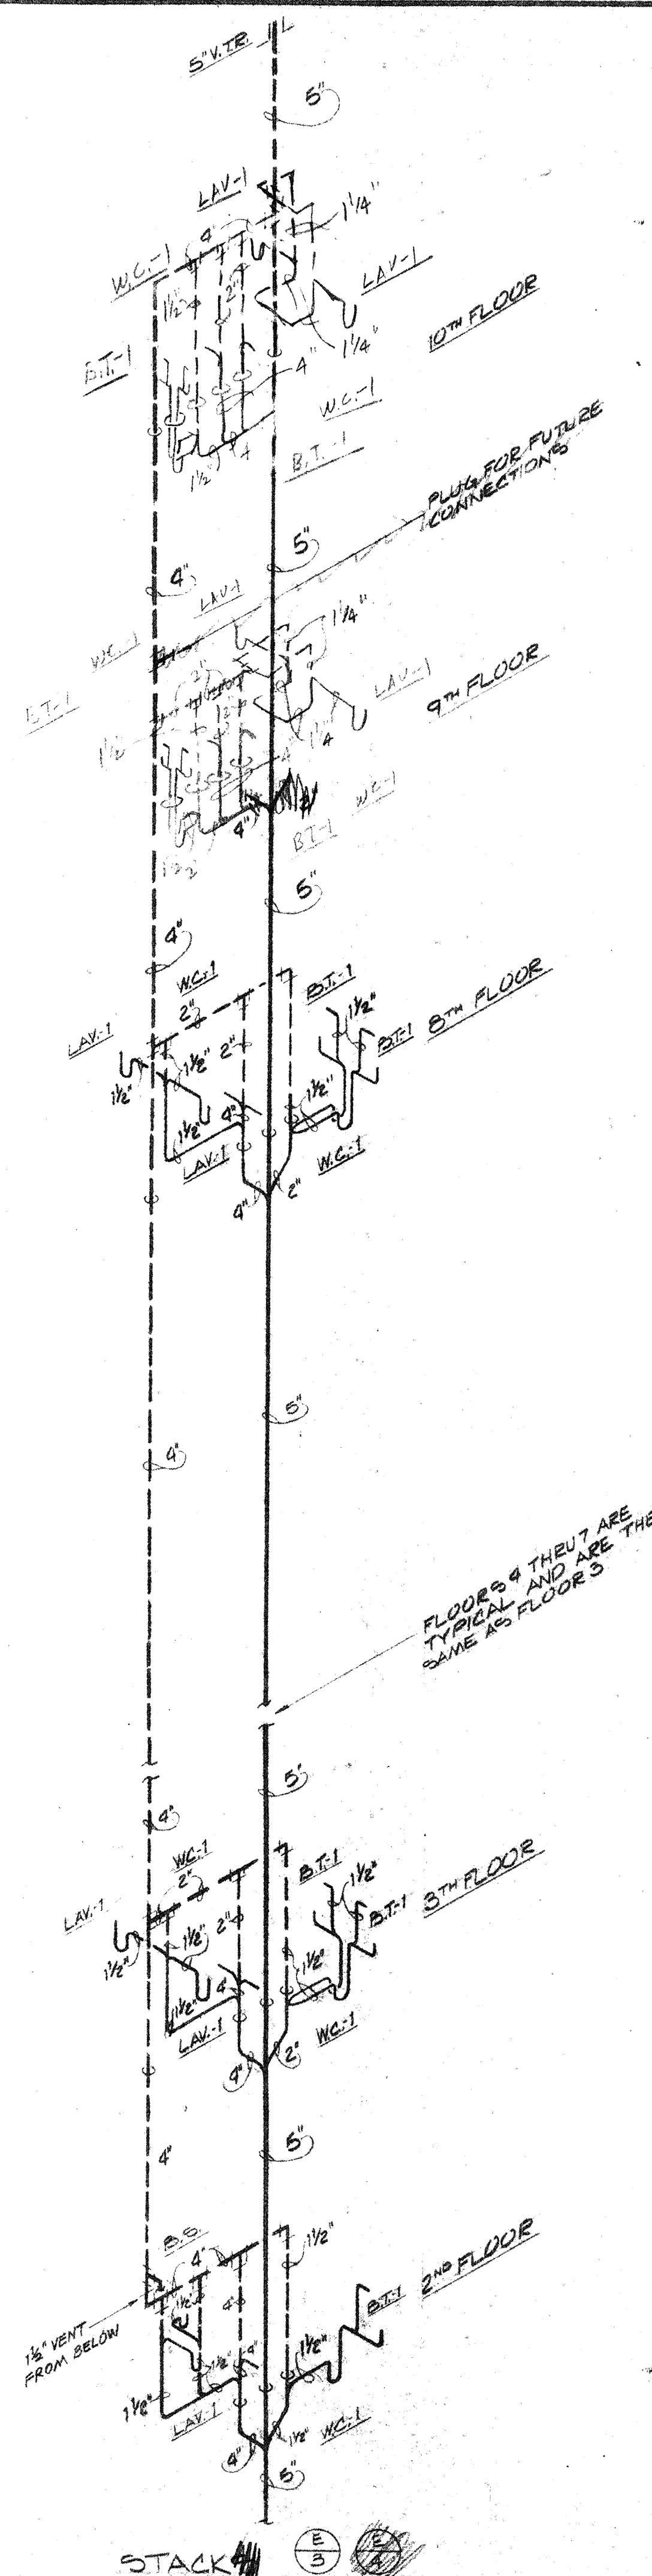




PARTIAL WASTE & VENT PIPING
NO SCALE

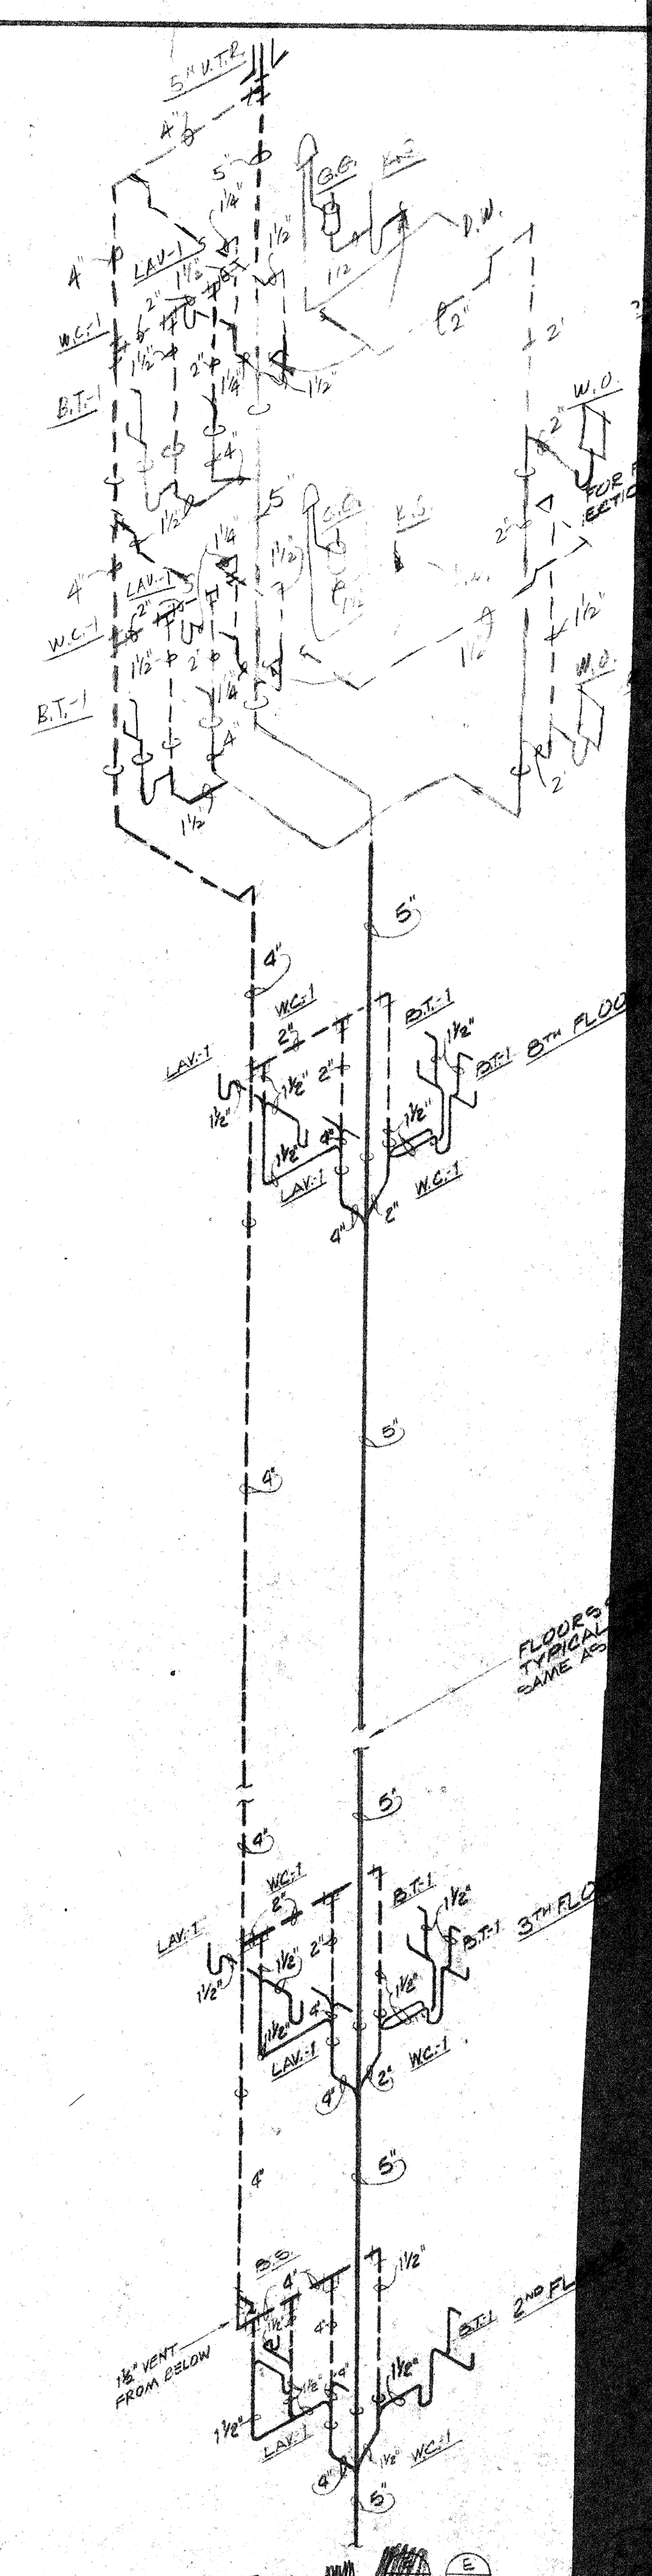

CARTER - FOSTER INC.

3257 Lochness Drive
Lexington, Kentucky

CAPITOL PLAZA HOTEL
FRANKFORT / KENTUCKY

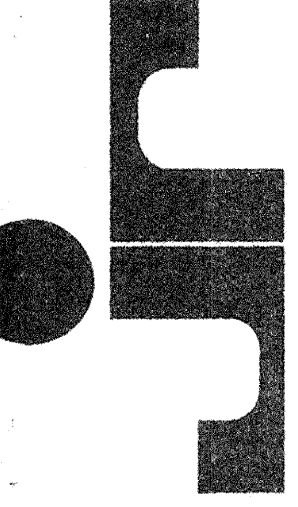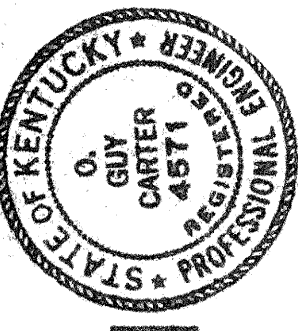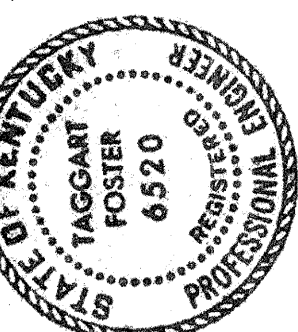

JOHNSON / ROMANOWITZ / ARCHITECTS / LEXINGTON / KENTUCKY
301 EAST VINE STREET, SUITE A
TELEPHONE (606) 252-6781


DRAWN B.H.	PROJECT
CHECKED T.F.	DATE 5-10-83

PLUMBING


PARTIAL WASTE & VENT
PIPING DIAGRAM

DRAWING
P-22

REVISED - 7-5-83

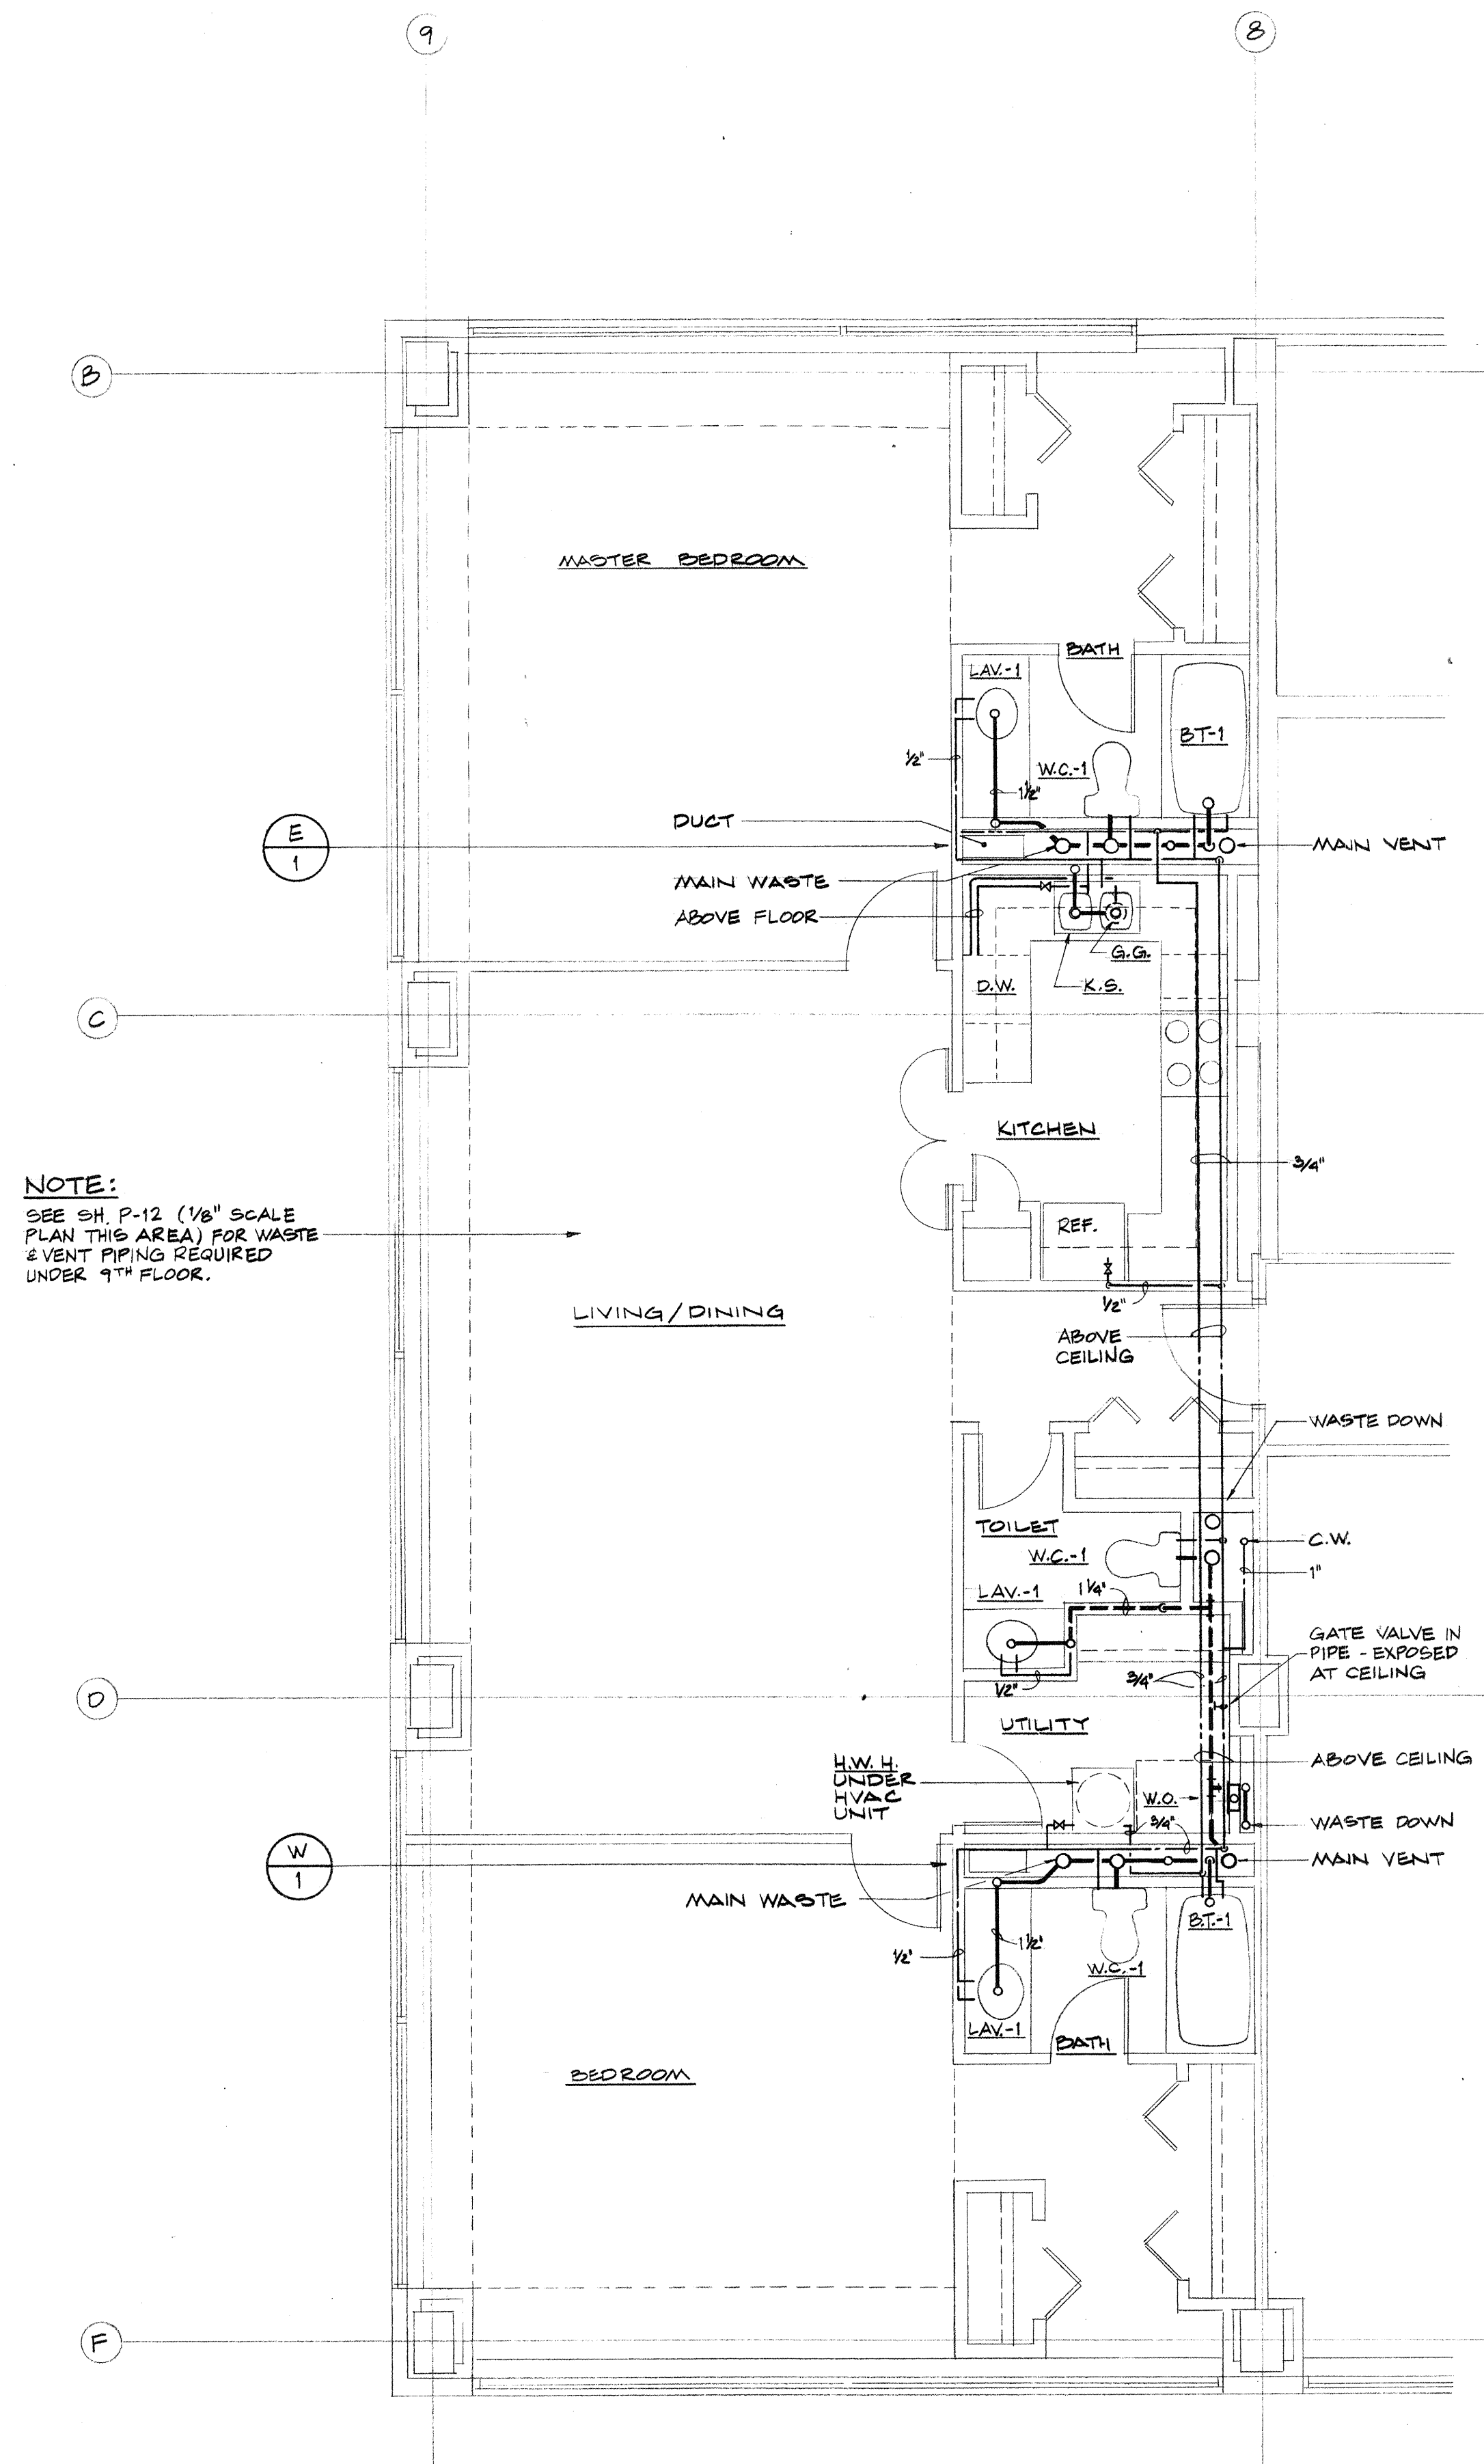

ENLARGED PLUMBING PLAN - TYPICAL FOR UNIT TYPE "A"
SCALE: 1/4" = 1'-0" (2 TYPICAL)



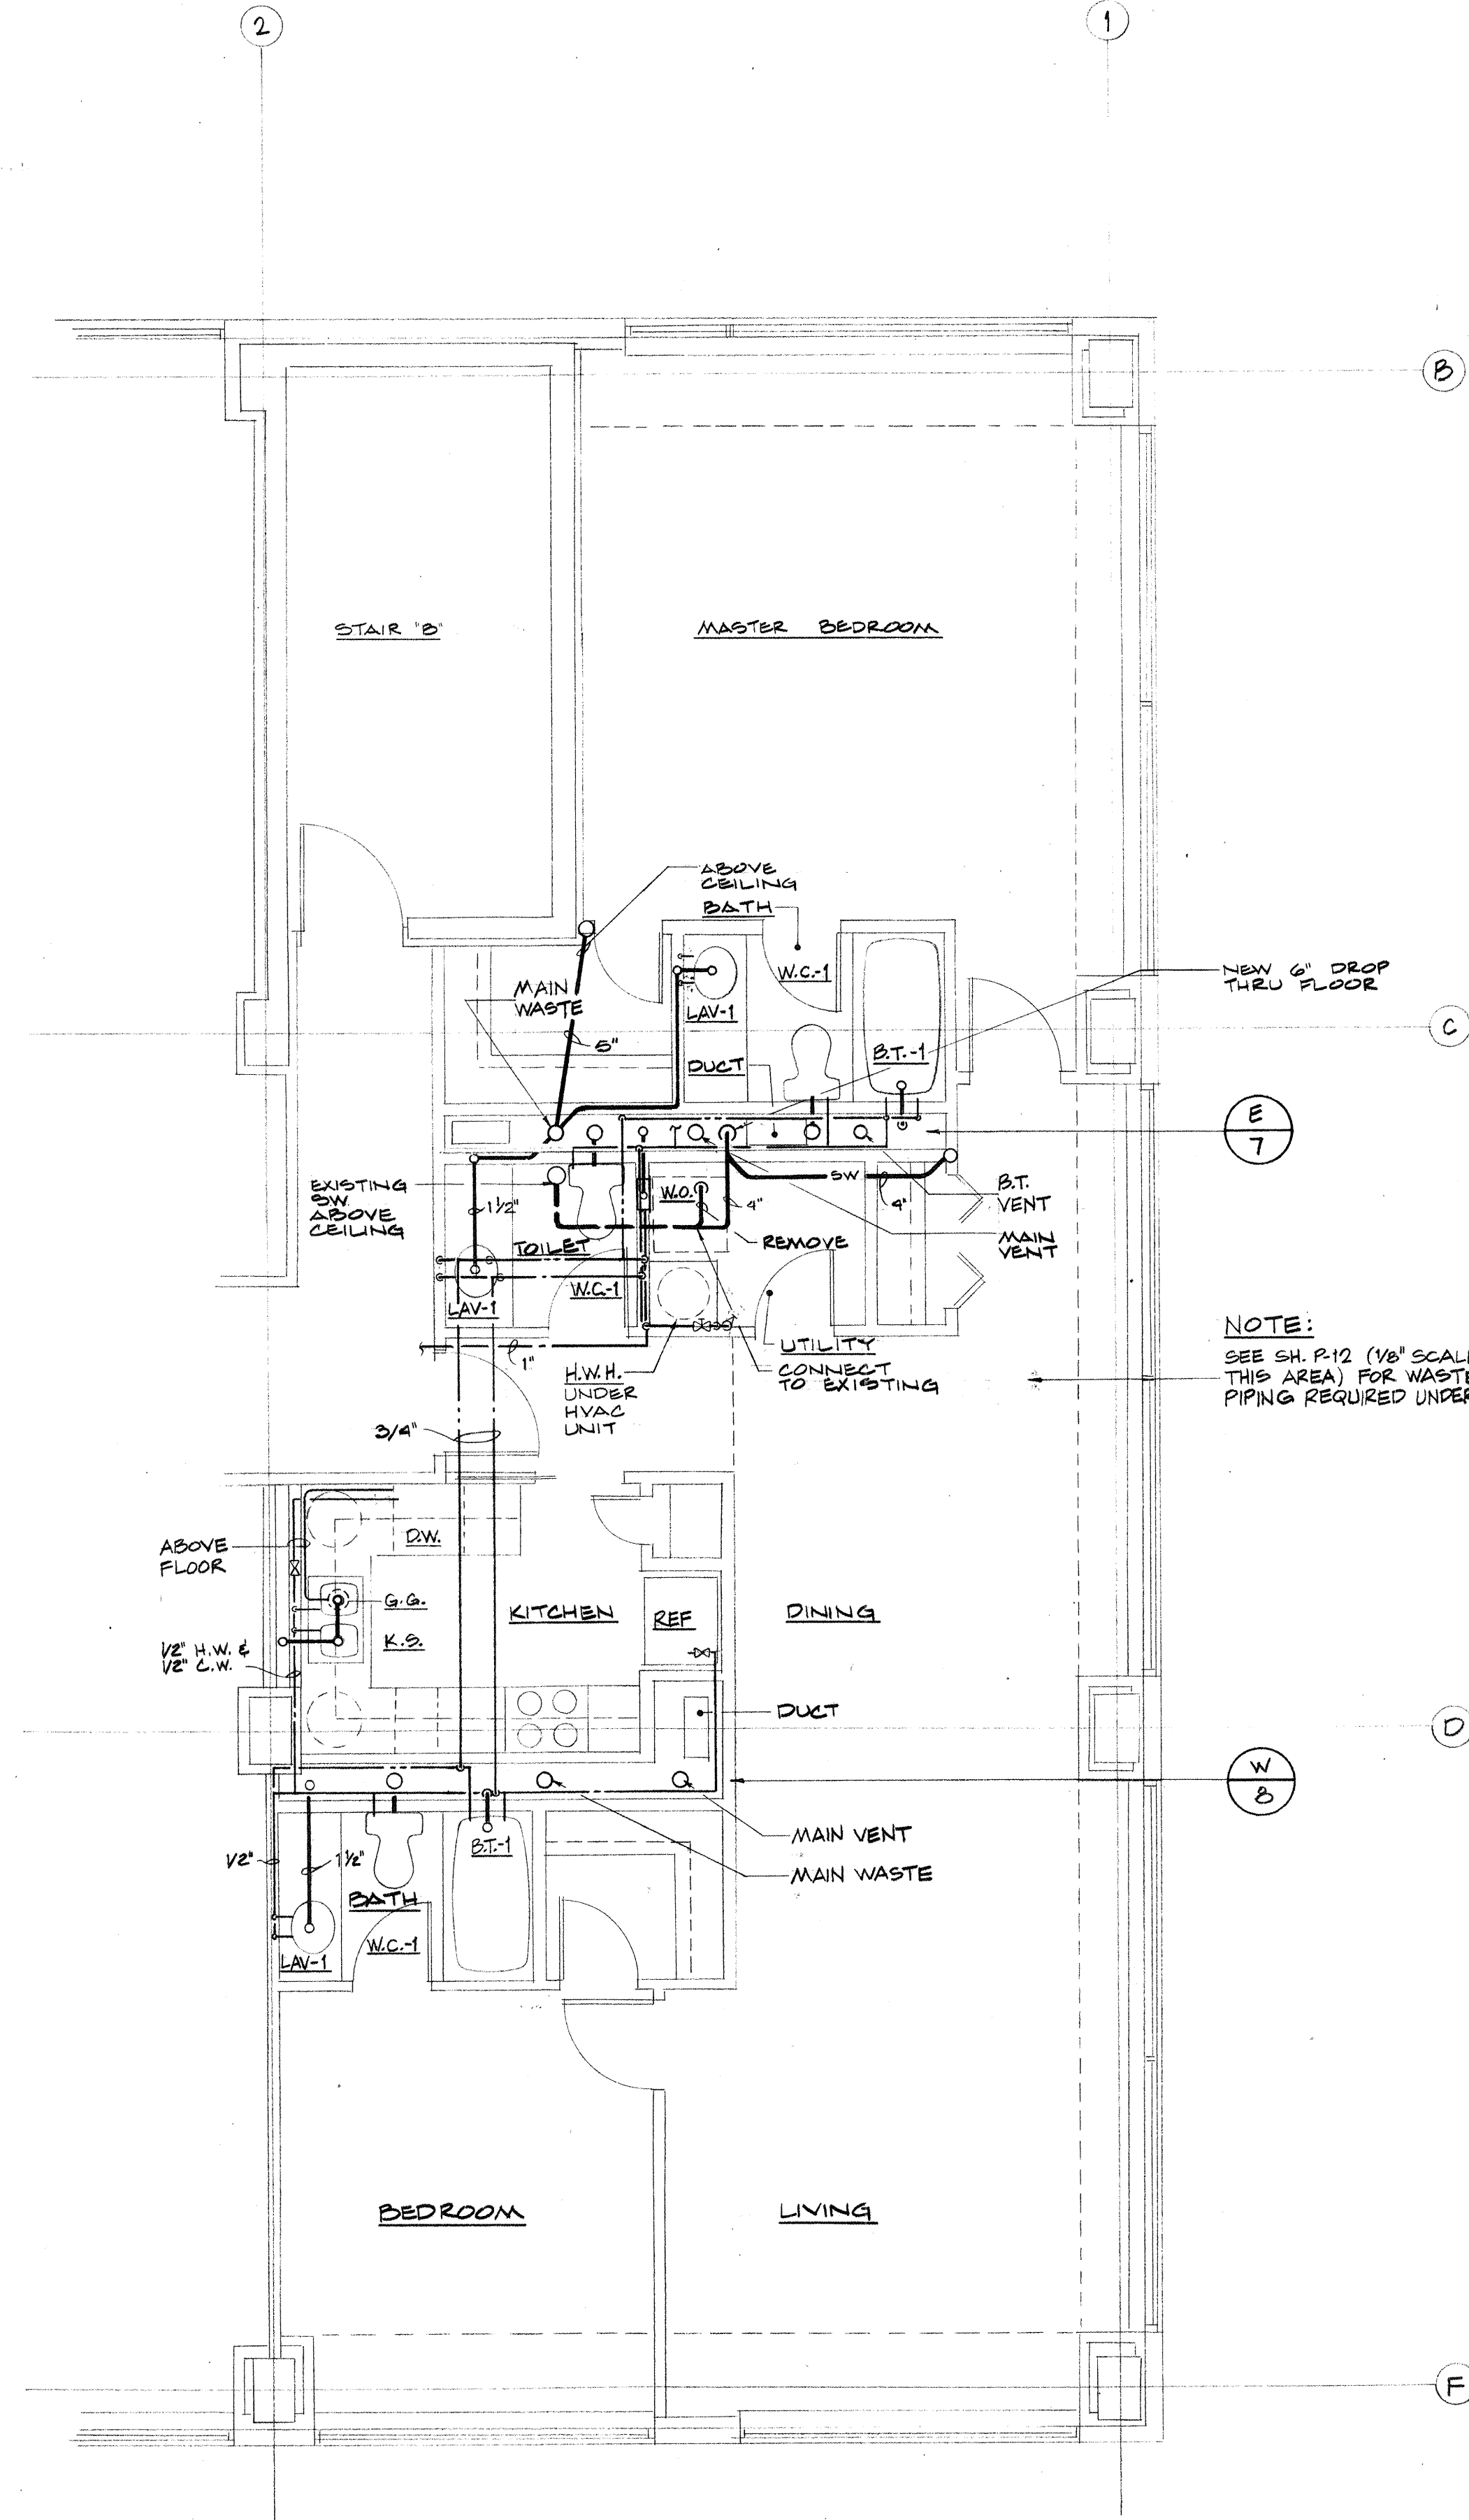


ENLARGED PLUMBING PLAN - TYPICAL FOR UNIT TYPE "E"
SCALE: 1/4" = 1'-0" (1 TYPICAL)

Consulting Engineers
3257 Lochness Drive
Lexington, Kentucky

CARTER - FOSTER INC.

CAPITOL PLAZA HOTEL
FRANKFORT / KENTUCKY

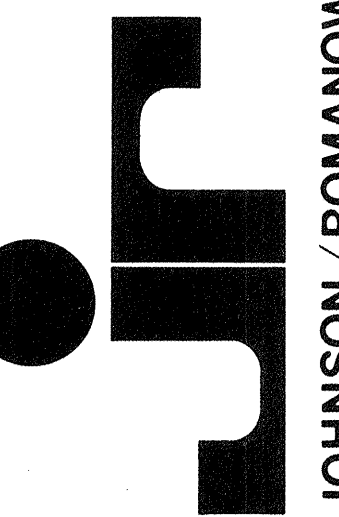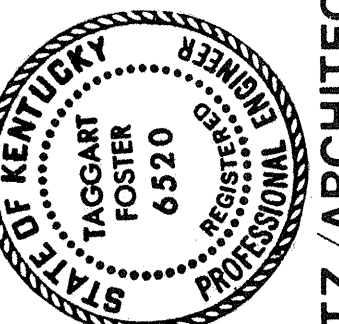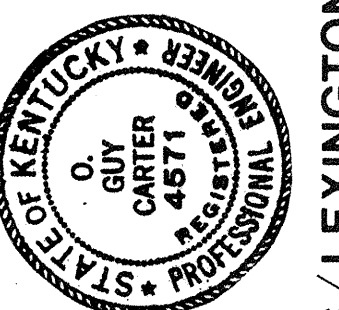

JOHNSON / ROMANOWICZ ARCHITECTS / LEXINGTON / KENTUCKY
301 EAST VINE STREET, SUITE A
TELEPHONE (606) 282-6781

DRAWN B. H.	PROJECT
CHECKED T. F.	DATE 1-3-84

PLUMBING


PLUMBING PLANS
LARGE SCALE
CONDOMINIUM UNITS
"A" AND "E"

DRAWING

P-23

PRINTED 2-7-84
NEW DRAWING 1-3-84


Note:
see sb. P-12
(1/8 scale plan this area)
for waste & vent piping
required under 9th
floor

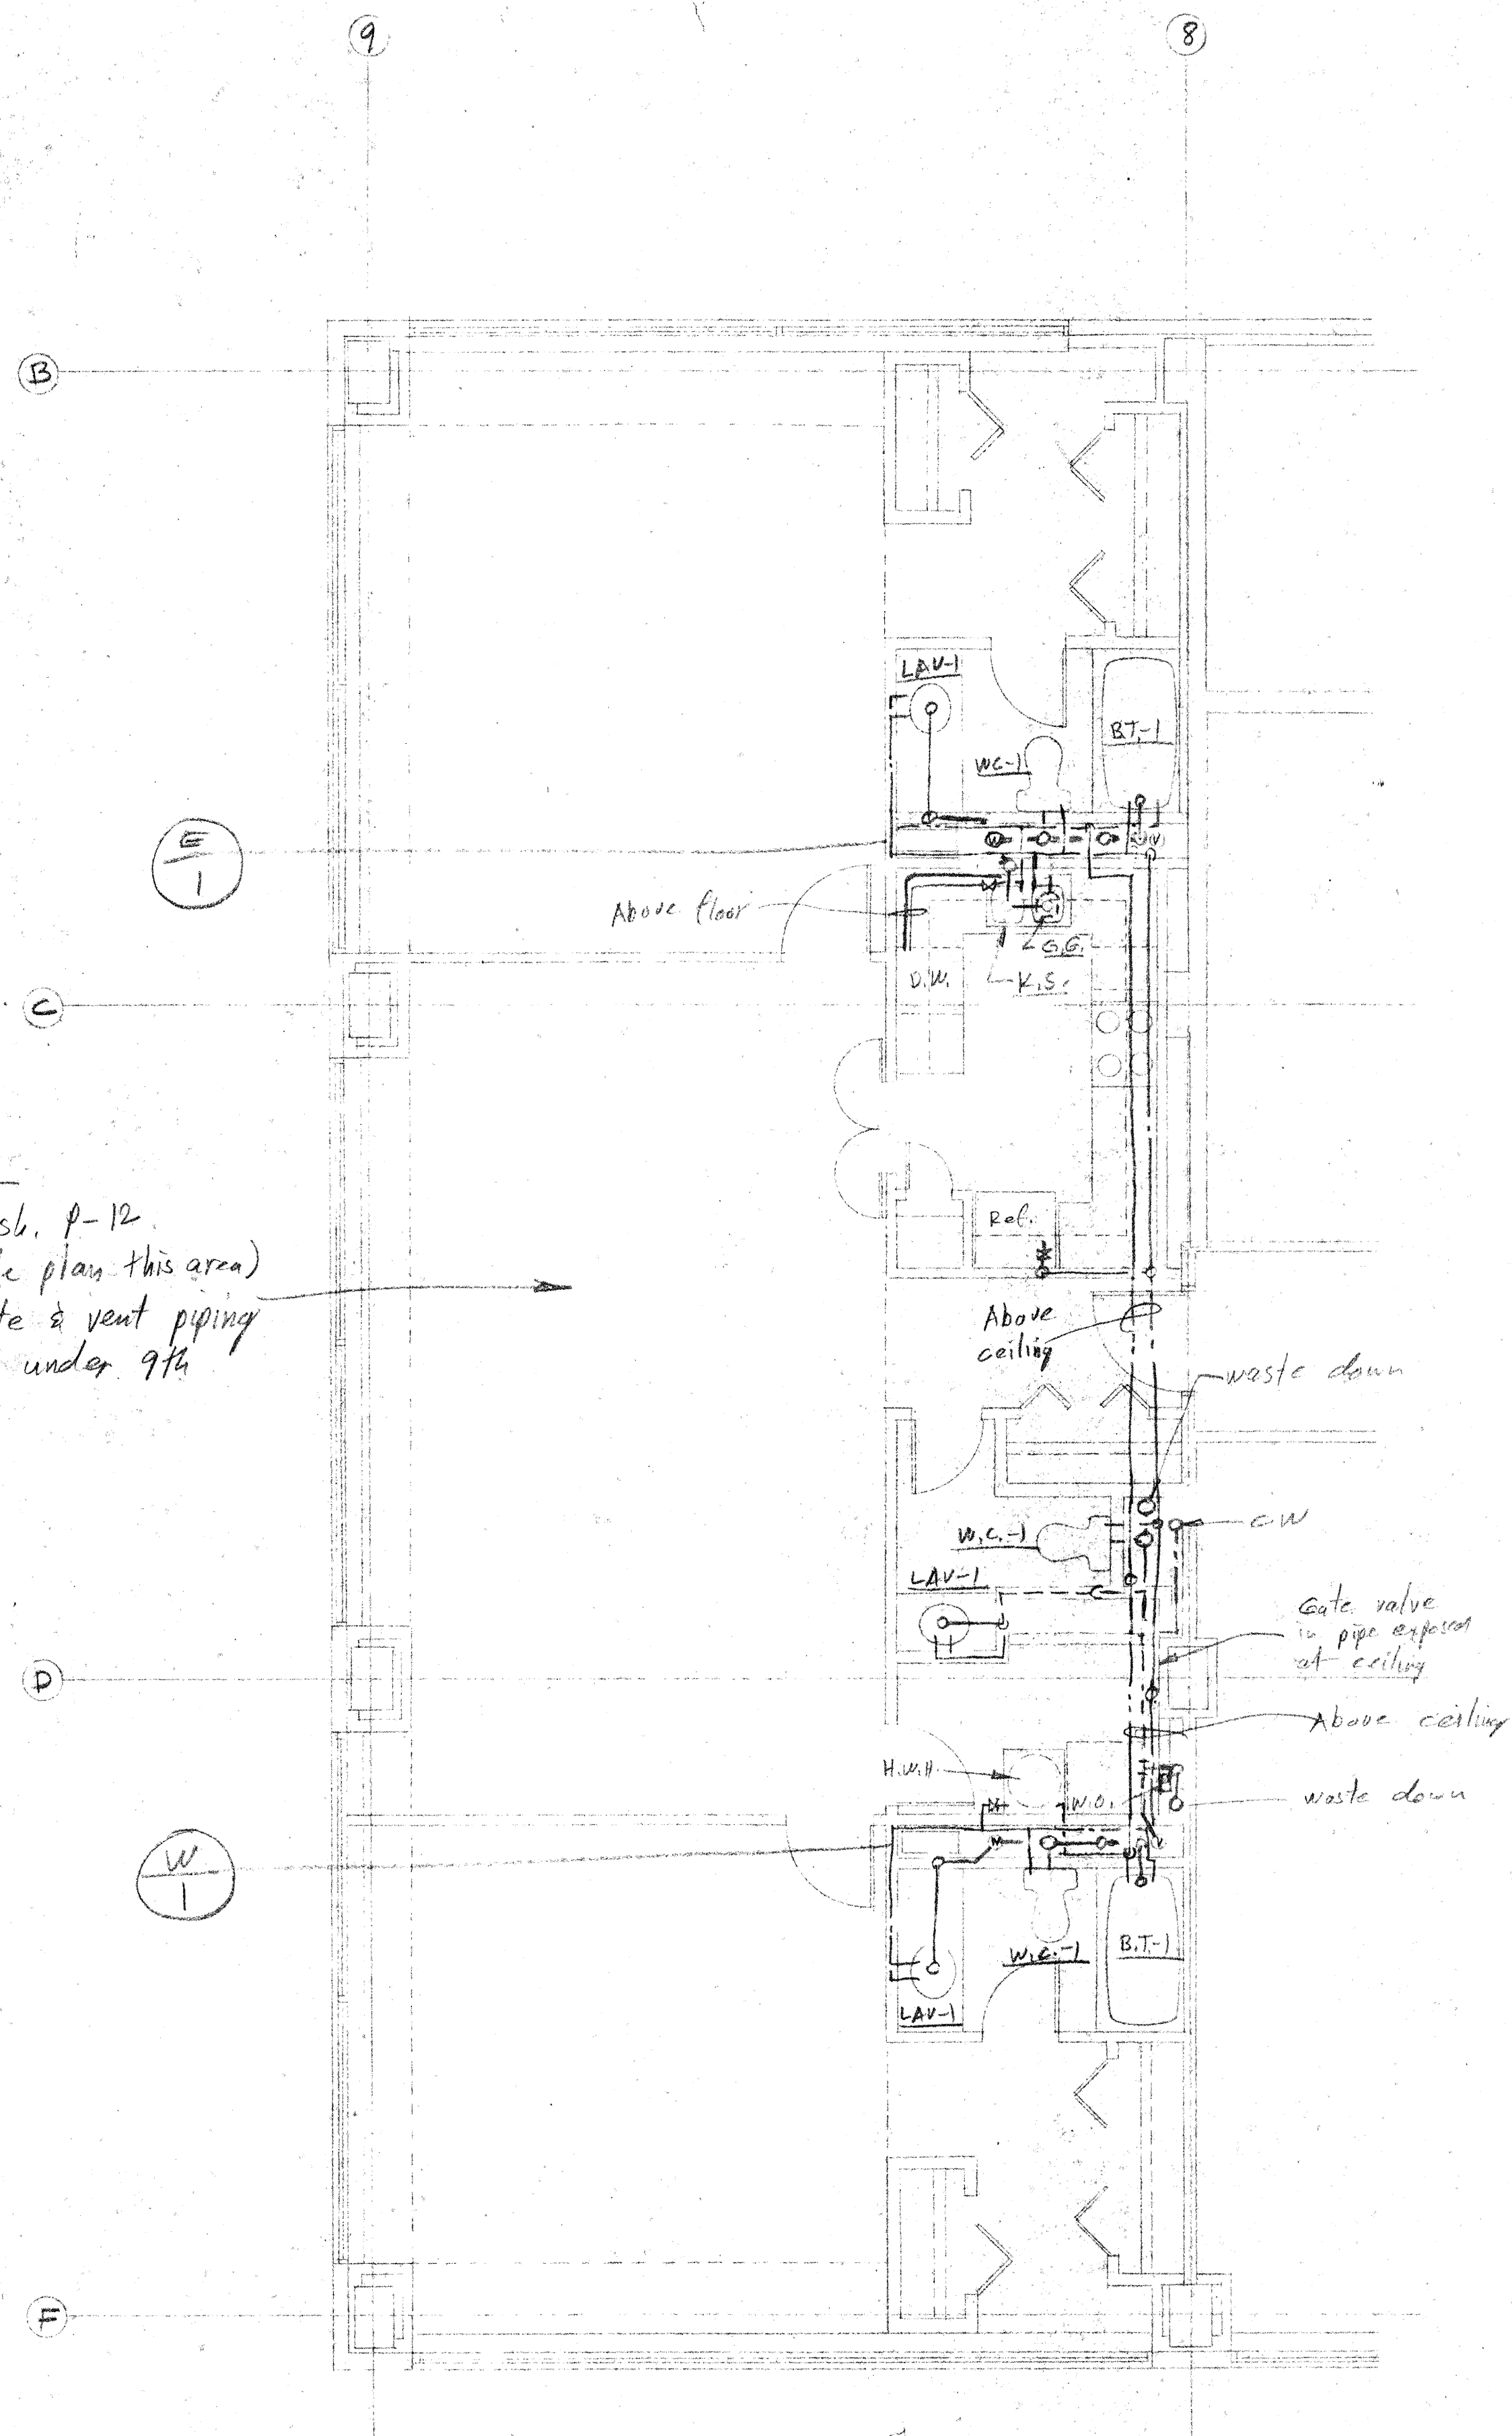

ENLARGED PLUMBING PLAN-TYPICAL FOR UNIT TYPE "A"
scale: 1/4" = 1'-0"

(2 typical)


Note:
see sb. P-12
(1/8 scale plan this area)
for waste & vent piping
required under 9th
floor

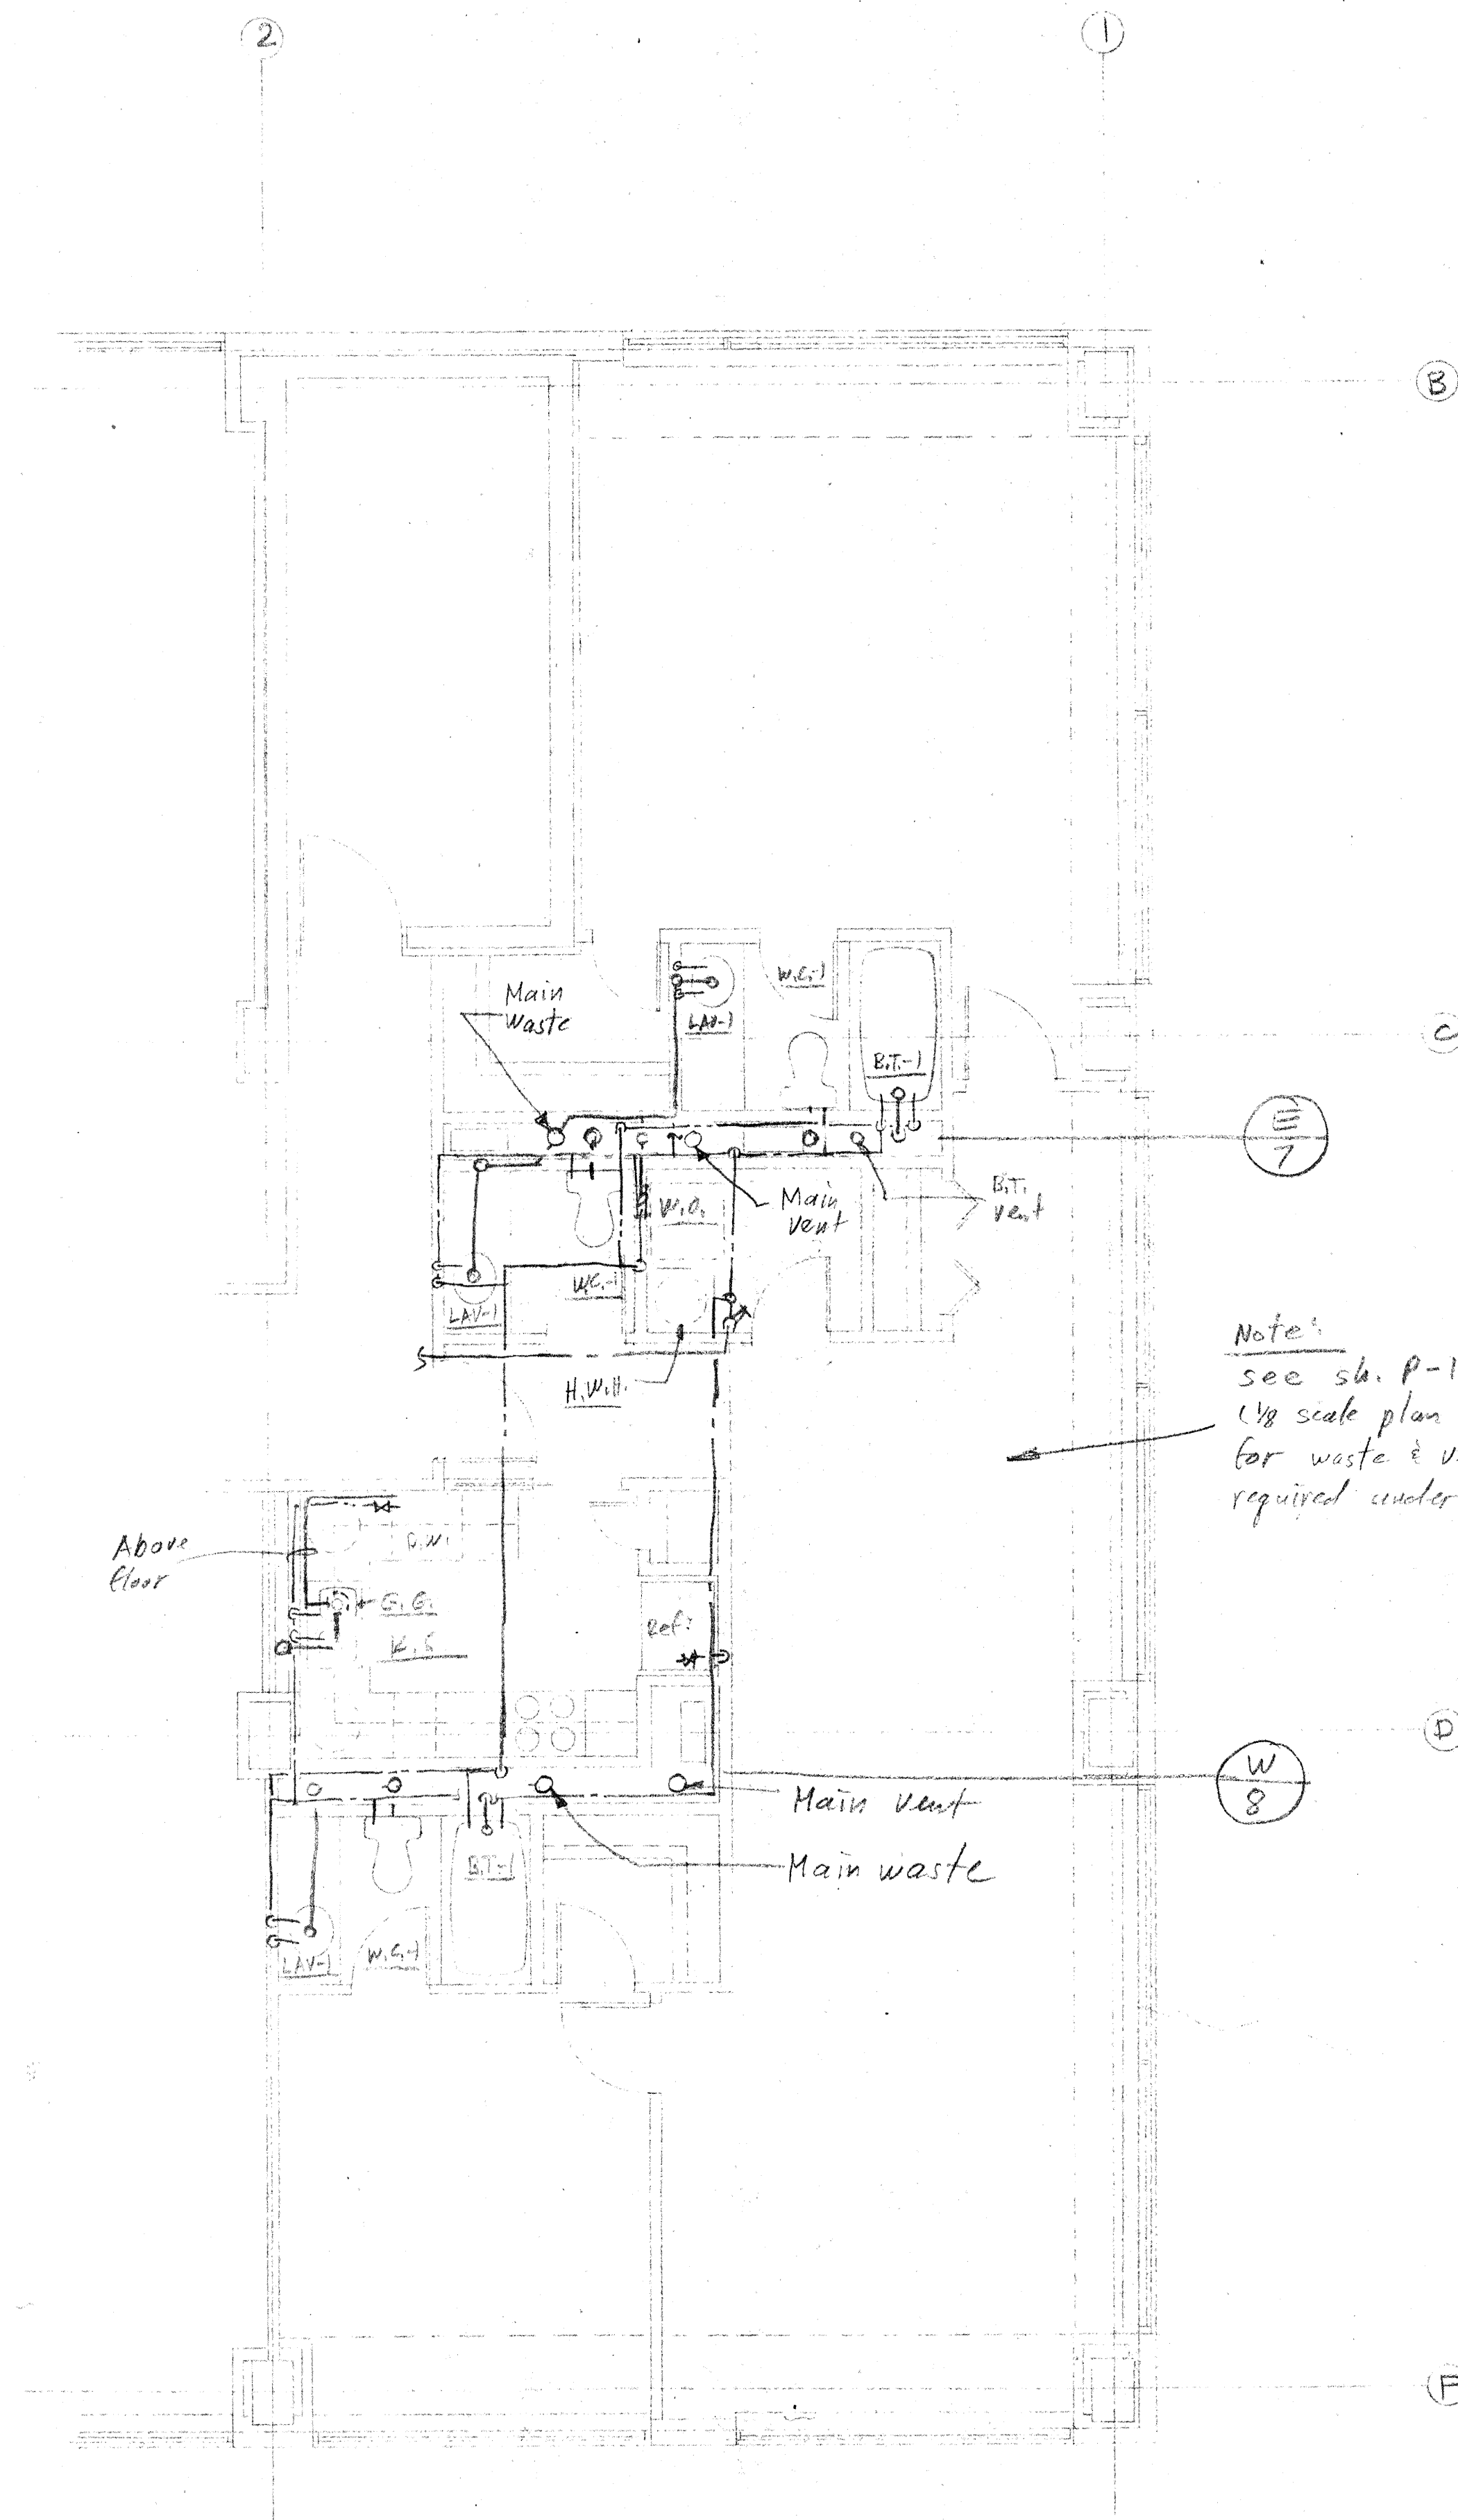


ENLARGED PLUMBING PLAN-TYPICAL FOR UNIT TYPE "E" (1 typical)
scale: 1/4" = 1'-0"

Dec 12, 1983


Drawing
P-23

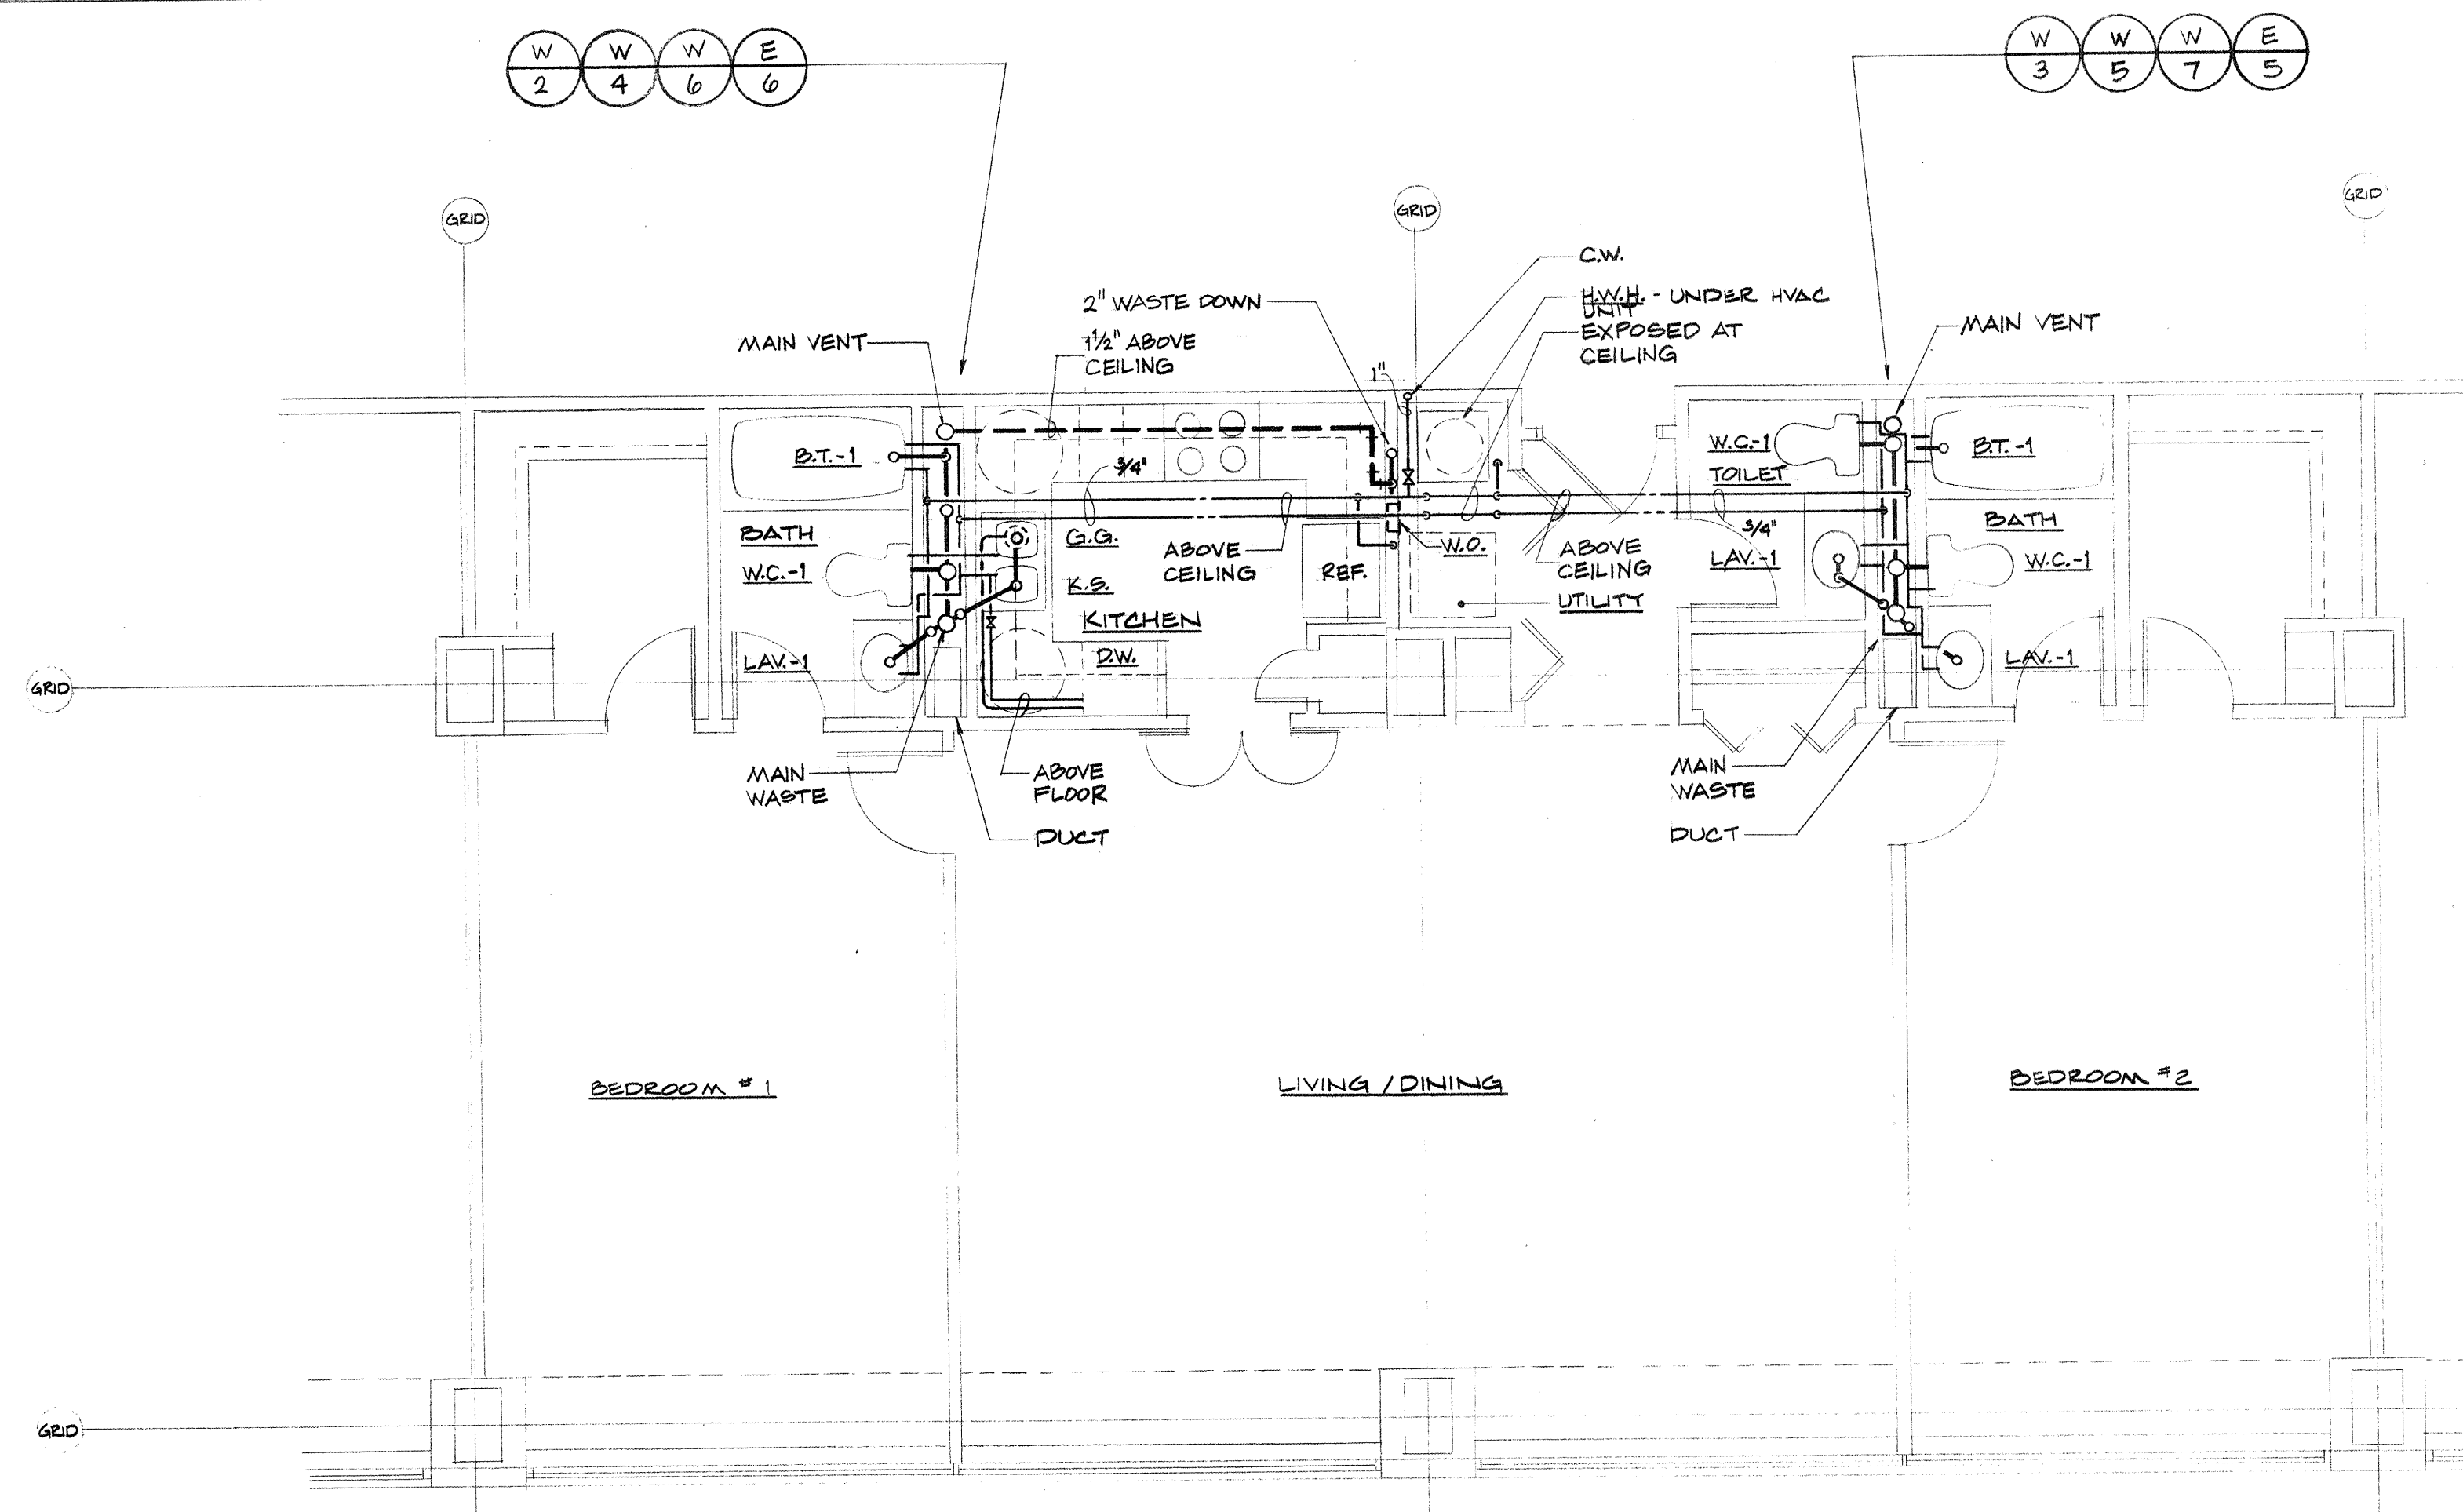

ENLARGED PLUMBING PLAN - TYPICAL FOR UNIT TYPE "B"
SCALE: 1/4" = 1'-0" (B TYPICAL)

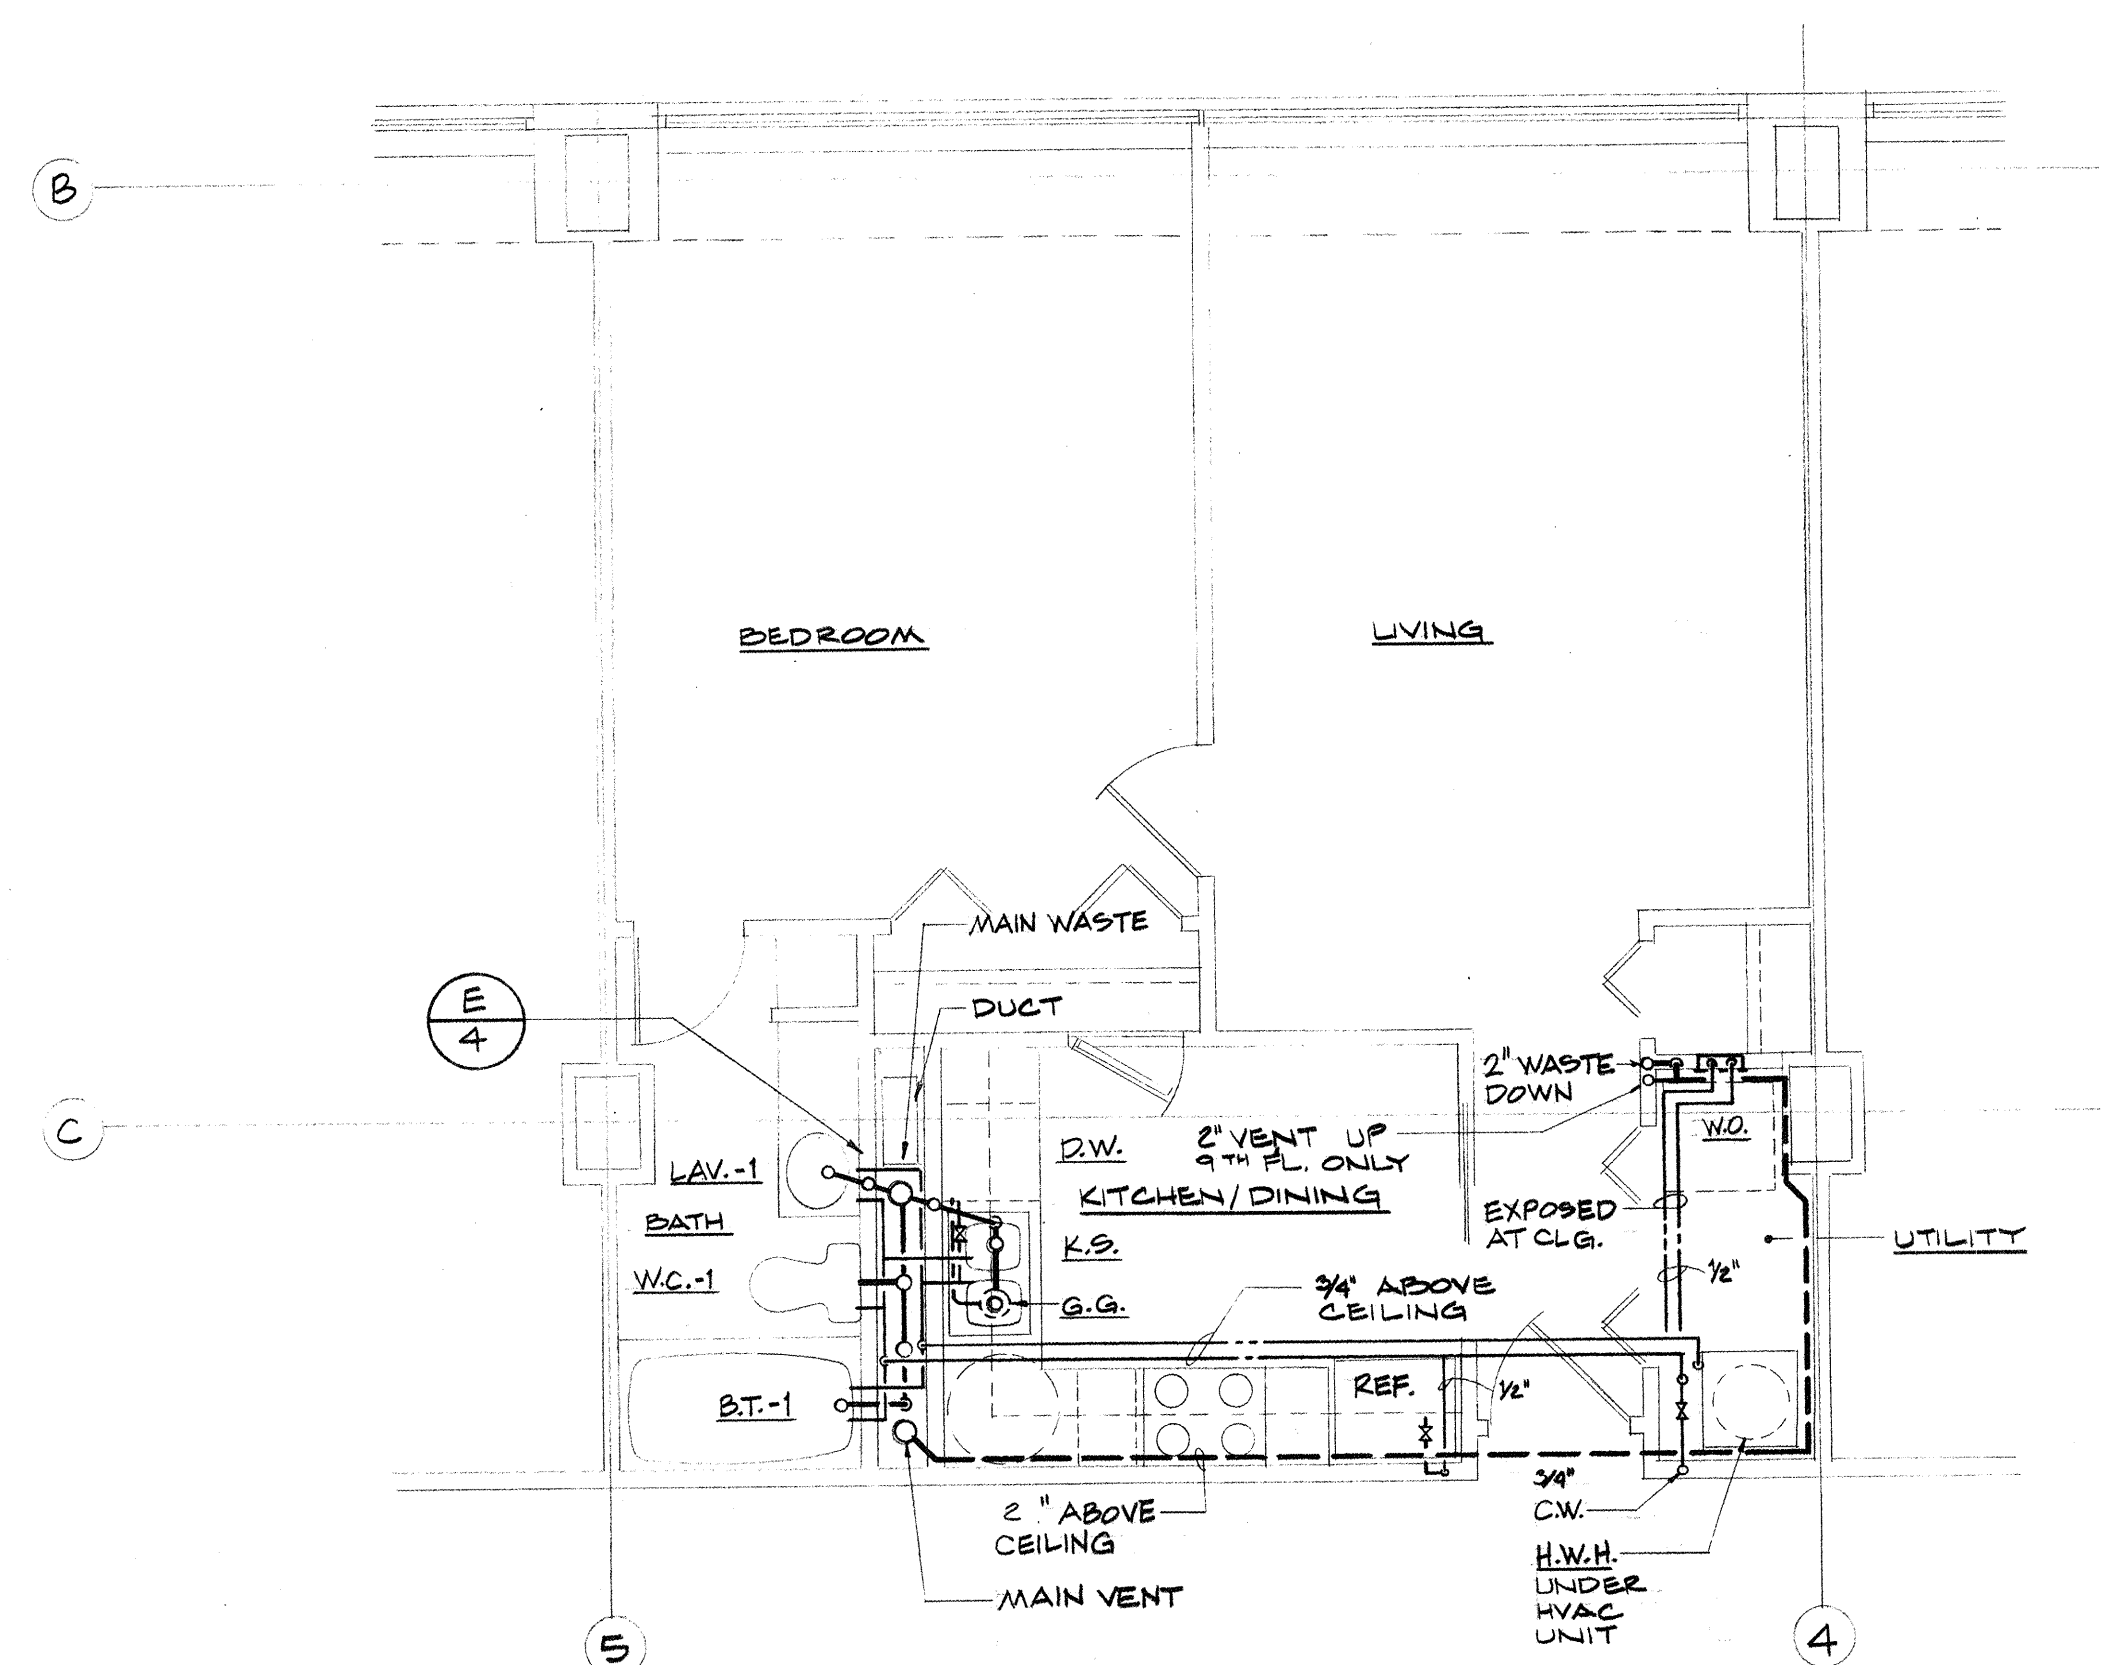

ENLARGED PLUMBING PLAN - TYPICAL FOR UNIT TYPE "C"
SCALE: 1/4" = 1'-0" (2 TYPICAL)

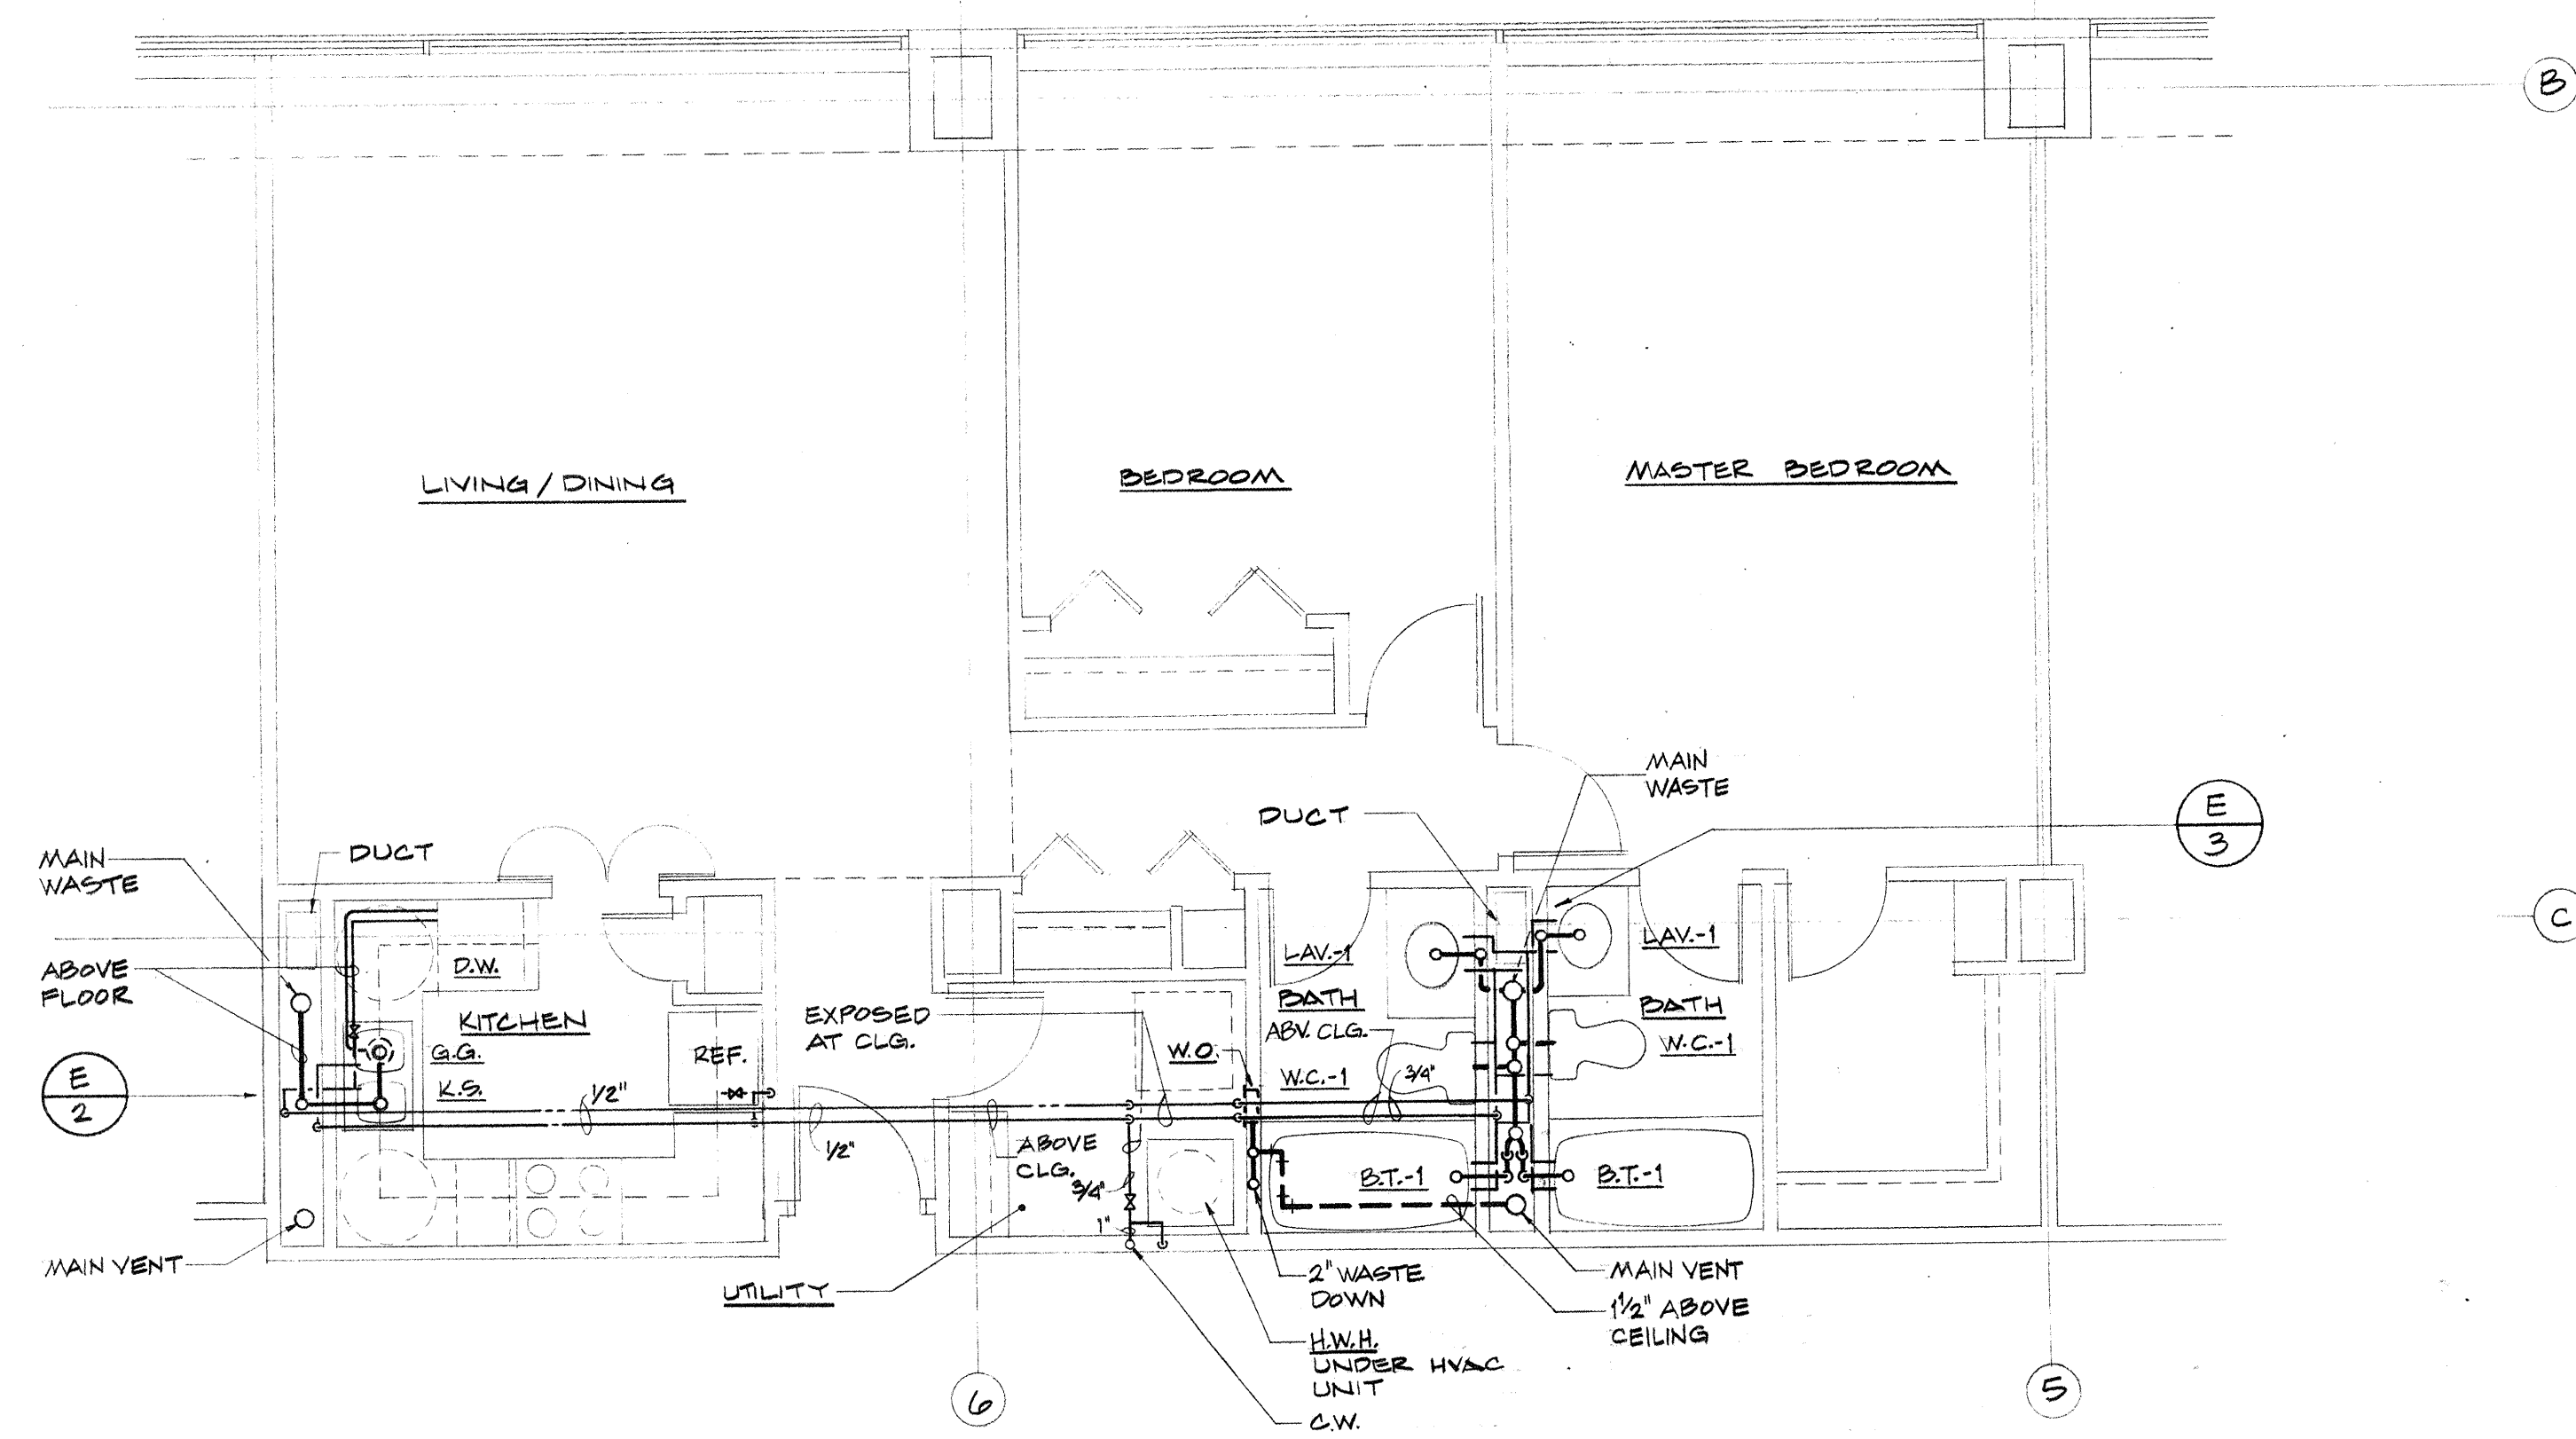

ENLARGED PLUMBING PLAN - TYPICAL FOR UNIT TYPE "D"
SCALE: 1/4" = 1'-0" (2 TYPICAL)

SCHEDULE OF PLUMBING FIXTURES

WATER CLOSET - 1 (W.C.-1): SAME AS IN ORIGINAL CONTRACT DOCUMENTS.

WATER CLOSET - 5 (W.C.-5): AMERICAN STANDARD "ELLISSE" NO. 2008.019 LOW PROFILE ONE PIECE VITREOUS CHINA TOILET WITH SEAT, COVER, BACKFLOW PREVENTER, VOLUME REGULATOR, FLUSH VALVE, ACTUATOR BUTTON AND TOP IN SUPPLY.

LAVATORY - 1 (LAV.-1): SAME AS IN ORIGINAL CONTRACT DOCUMENTS.

BATHTUB - 1 (B.T.-1): SAME AS IN ORIGINAL CONTRACT DOCUMENTS.

SHOWER (SH): POWERS NO. 401 PRESSURE BALANCED MIXING VALVE WITH INLET CHECK STOPS AND POWERS SHOWER SET NO. 85 WITH SHOWER HEAD, ARM AND FLANGE. PROVIDE DOLE NO. 3-5 3.0 GPM FLOW REGULATOR.

SHOWER DRAIN (S.D.): ZURN Z-415 TRIUMPH DRAIN WITH 6" POLISHED BRASS TOP, TYPE M STRAINER WITH BUCKET, CLAMPING COLLAR, SIZE 2".

KITCHEN SINK (K.S.): ELKAY NO. LR-3322 18 GA. STAINLESS STEEL DOUBLE BOWL SINK 33" L X 22" W X 7 1/2" D WITH LK-2103 SINGLE LEVER FAUCET WITH SPRAY, LK-35 STRAINER, 1 1/2" CAST BRASS P-TRAP, 1 1/2" CONTINUOUS WASTE AND STOPS IN SUPPLIES. PROVIDE EXTRA HOLE DRILLED IN SINK TO ACCOMMODATE VACUUM BREAKER FOR DISHWASHER DRAIN.

GARBAGE GRINDER (G.G.): IN-SINK-ERATOR MODEL 77, 1/2 HP, 10/115V.

WASHER OUTLET BOX (W.O.): GUY GRAY NO. BBED-200TS WITH TOP FEED WATER SUPPLIES, 2" DRAIN CONNECTION, WASHER ELECTRICAL OUTLET AND DRYER ELECTRICAL OUTLET.

DISHWASHER (D.W.): FURNISHED BY OTHERS. PROVIDE HOT WATER AND DRAIN ROUGH-INS.

REFRIGERATOR (REF.): FURNISHED BY OTHERS. PROVIDE COLD WATER ROUGH-IN.

KEYED NOTES

- DOMESTIC WATER HEATER - LOCHINVAR STUBBY SERIES NO. GSA-050KK ENERGY SAVER SERIES, UL LISTED, 10 YEAR LIMITED WARRANTY, 50 GALLON STORAGE, 9 KW, 10/240V.
- PRESSURE AND TEMPERATURE RELIEF VALVE - WATTS NO. 40XL, SIZE 3/4" PIPE 3/4" DISCHARGE PIPE TO WASHER OUTLET BOX AND TURN DOWN OVER DRAIN INLET. HOLD BOTTOM AT 3/4" DISCHARGE PIPE AT LEAST 1" ABOVE DRAIN INLET.
- SHOCK ABSORBER - ZURN Z-1700, SIZE 200.
- MAIN C.W. SERVICE TO CONDO UNIT. DROP IN CORRIDOR PARTITION TO CEILING SPACE BELOW (TYPICAL FOR 10TH FLOOR UNITS). RISE TO ABOVE CEILING AT CORRIDOR PARTITION (TYPICAL FOR 9TH FLOOR UNITS.)

GENERAL NOTES:

- PLUMBING INSTALLATION SHALL BE IN ACCORDANCE WITH ORIGINAL CONTRACT DOCUMENTS UNLESS OTHERWISE NOTED.
- SEE SHEET P-4 FOR LEGEND.
- PIPING IN ROOMS WITH SUSPENDED CEILINGS SHALL BE ABOVE CEILING UNLESS OTHERWISE NOTED.
- LOCATIONS OF PIPING AND EQUIPMENT ARE APPROXIMATE AND SUBJECT TO MINOR ADJUSTMENTS IN THE FIELD. DO NOT SCALE THE DRAWINGS.
- ALL OFFSETS IN PIPING ARE NOT NECESSARILY SHOWN. PROVIDE ADDITIONAL OFFSETS WHERE NECESSARY.
- COORDINATE WITH SPRINKLER, HVAC AND ELECTRICAL CONTRACTORS TO AVOID INTERFERENCES WITH PIPING, DUCTS AND CONDUIT.
- INSTALL PIPING AND EQUIPMENT IN ACCORDANCE WITH MANUFACTURERS INSTALLATION INSTRUCTIONS.



SUPPLEMENTAL PLUMBING LEGEND	
---	HOT WATER
---	REGULATING HOT WATER
K.S.	KITCHEN SINK
G.G.	GARBAGE GRINDER
W.O.	WASHER OUTLET BOX
D.W.	DISHWASHER
REF.	REFRIGERATOR
W.B.	WHIRLPOOL BATH

NOTE:
SEE LEGEND ON DWG. P-4 FOR
ADDITIONAL PLUMBING SYMBOLS

Consulting Engineers
3257 Lochness Drive
Lexington, Kentucky

CARTER - FOSTER INC.

CAPITOL PLAZA HOTEL
FRANKFORT / KENTUCKY

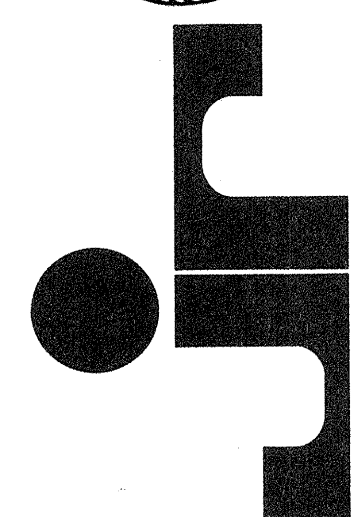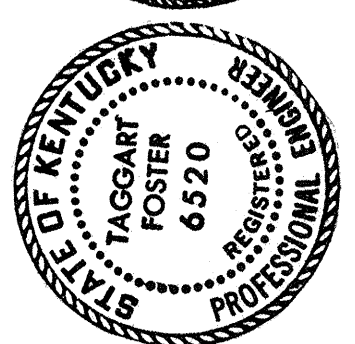

JOHNSON / ROMANOWITZ ARCHITECTS / ENGINEERS / LEXINGTON / KENTUCKY
301 EAST VINE STREET, SUITE A
TELEPHONE (606) 252-6781

DRAWN B.H.	PROJECT
CHECKED T.F.	DATE 1-3-84


PLUMBING

PLUMBING PLANS
LARGE SCALE
CONDOMINIUM UNITS
8", 10" AND 12"


DRAWING

P-24


PRINTED 2-27-84
NEW DRAWING (1-3-84)

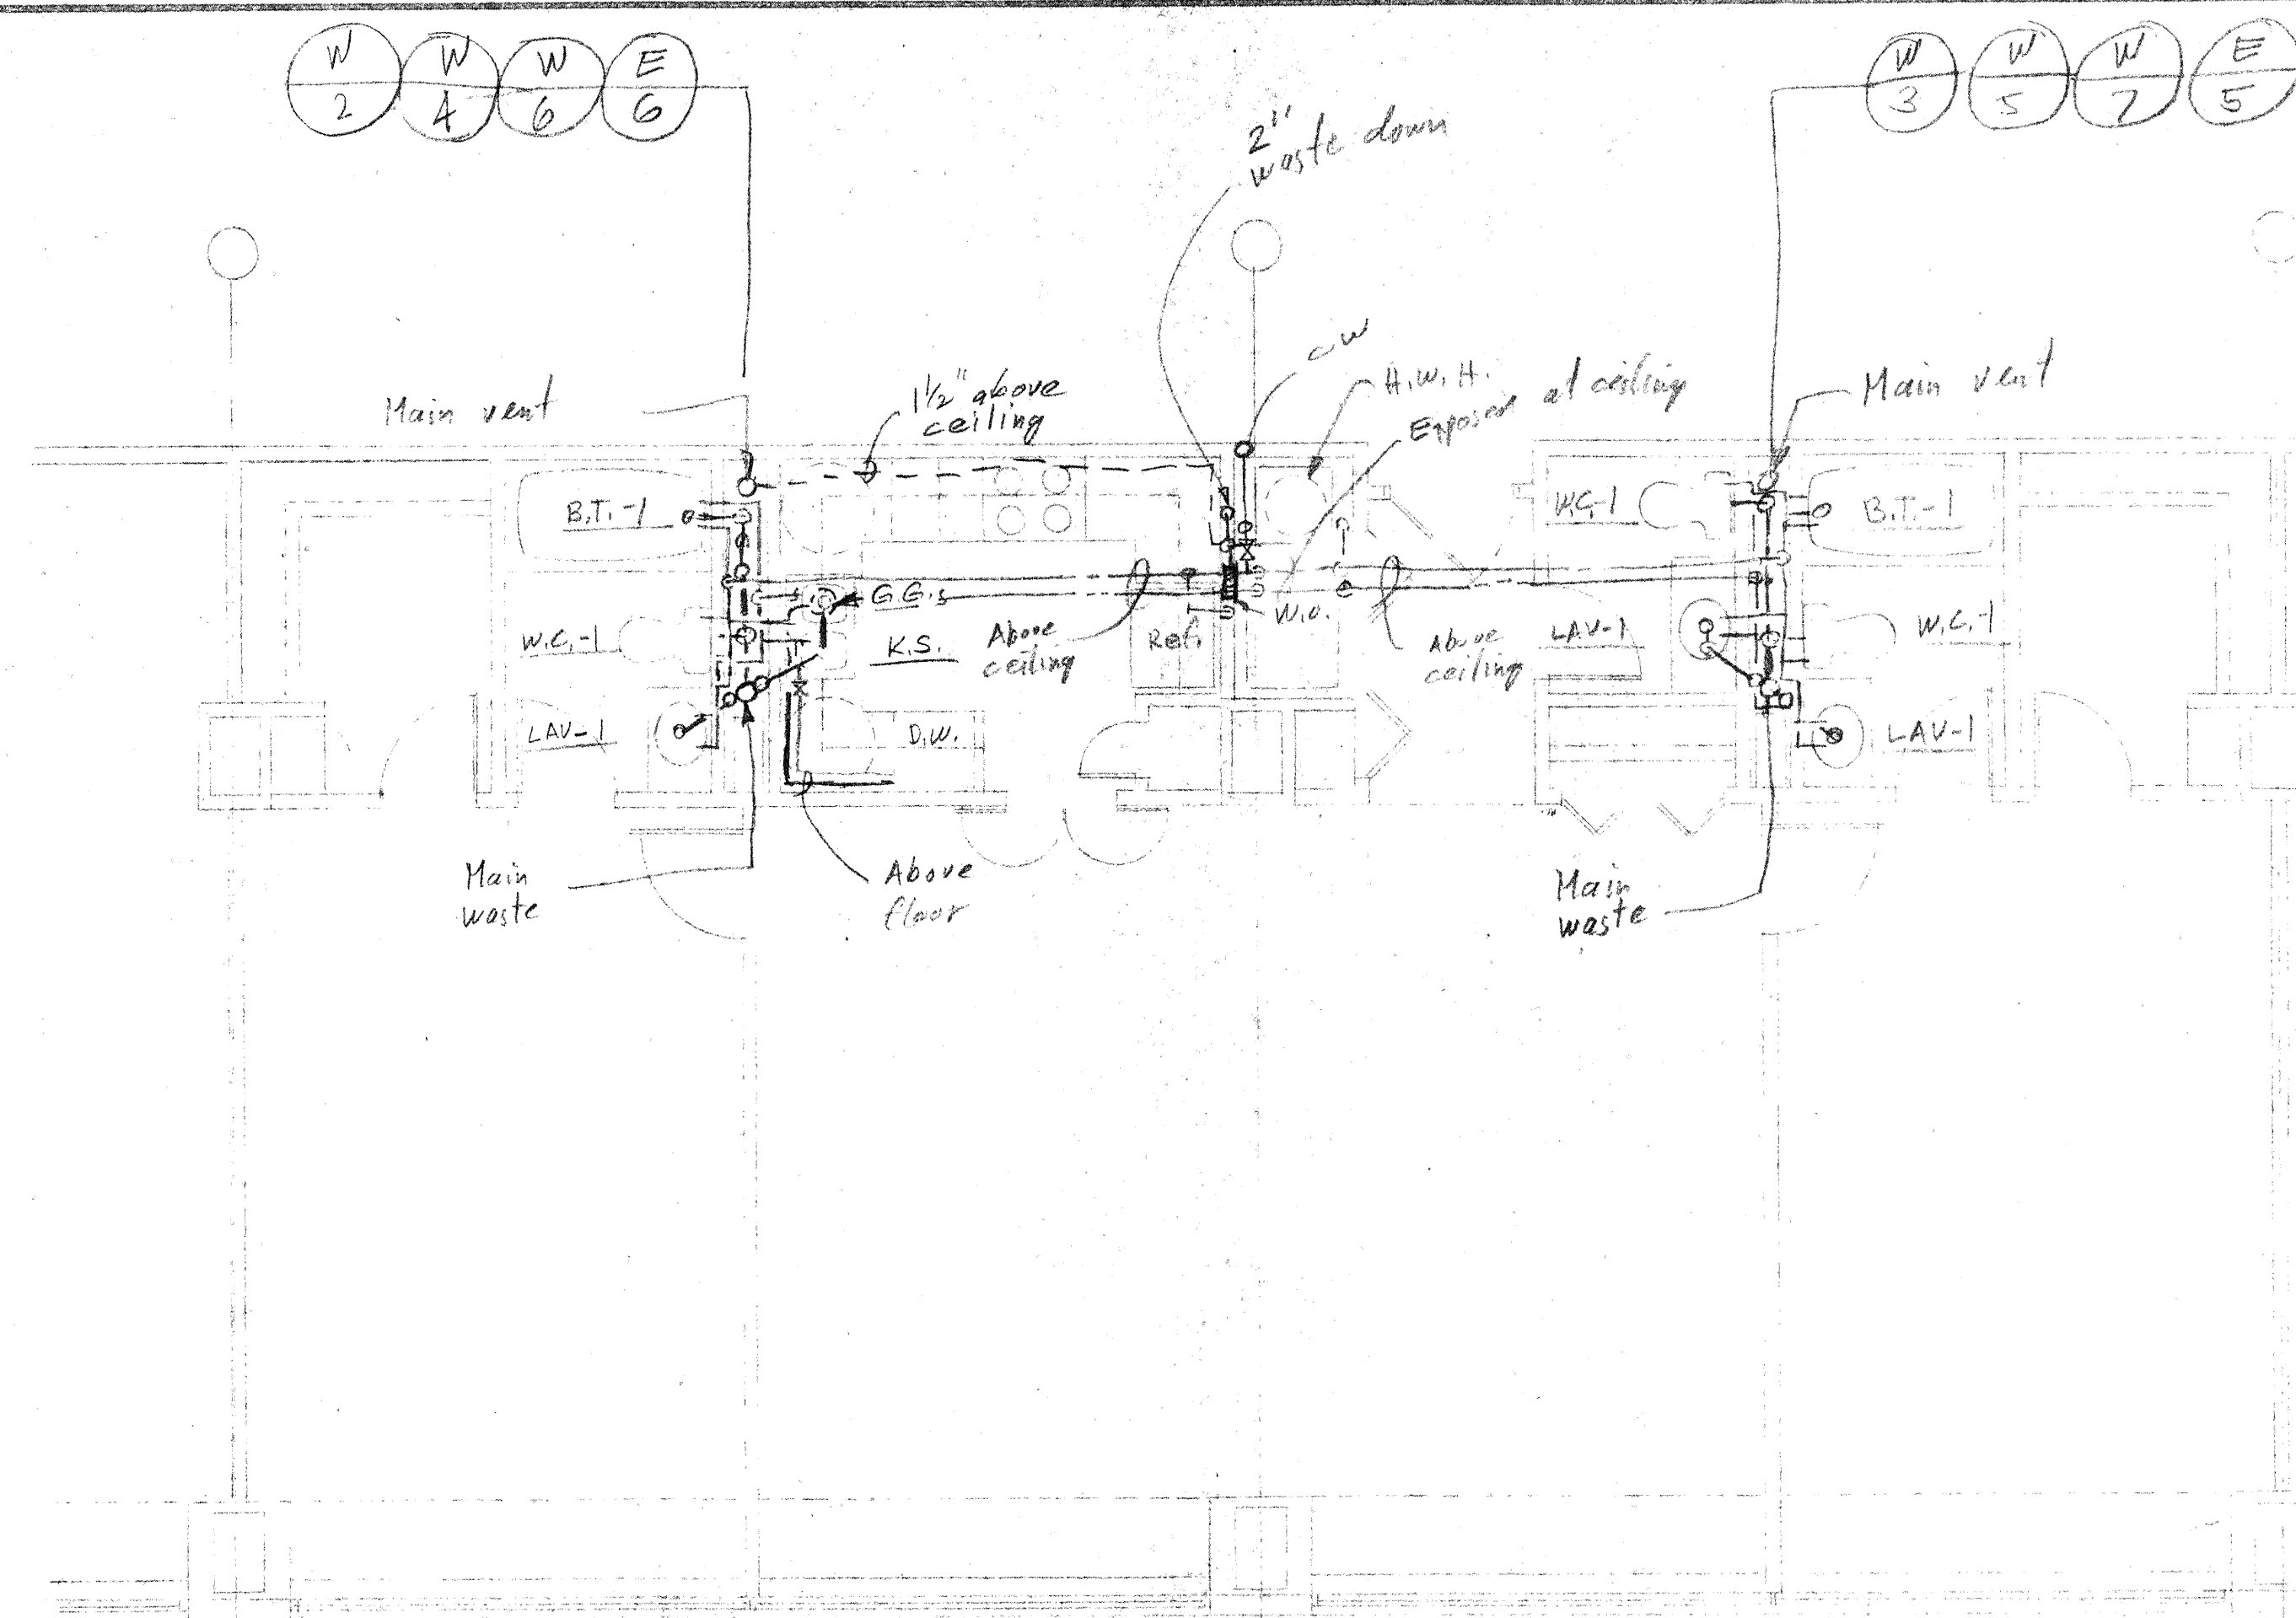

ENLARGED PLUMBING PLAN - TYPICAL FOR UNIT TYPE "B"
 scale: 1/4" = 1'-0"
 (8 typical)

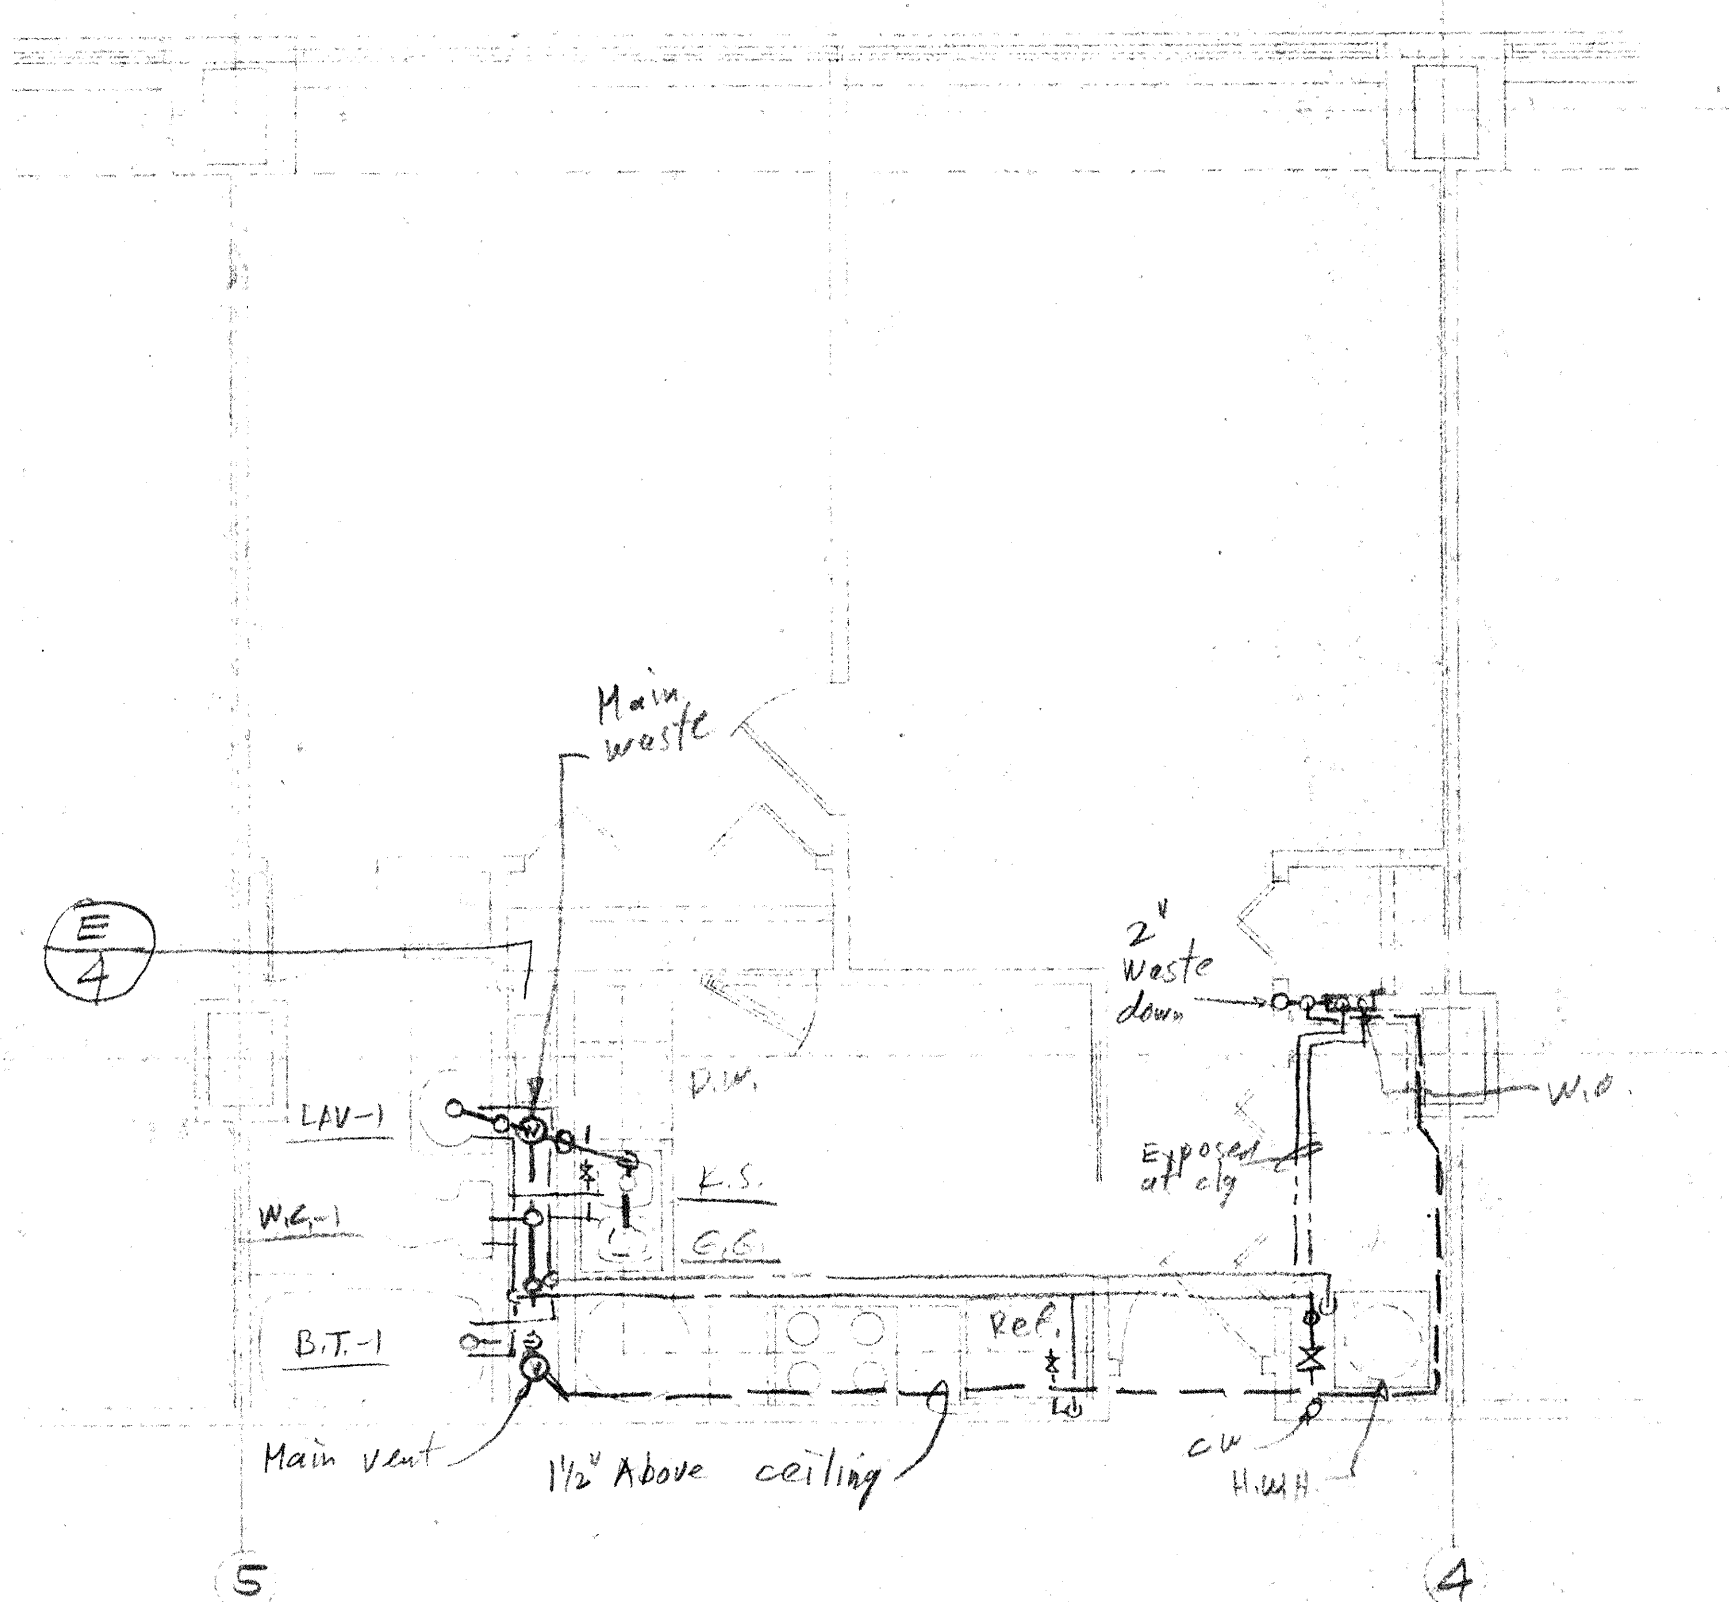


ENLARGED PLUMBING PLAN - TYPICAL FOR UNIT TYPE "C"
 scale: 1/4" = 1'-0"
 (2 typical)

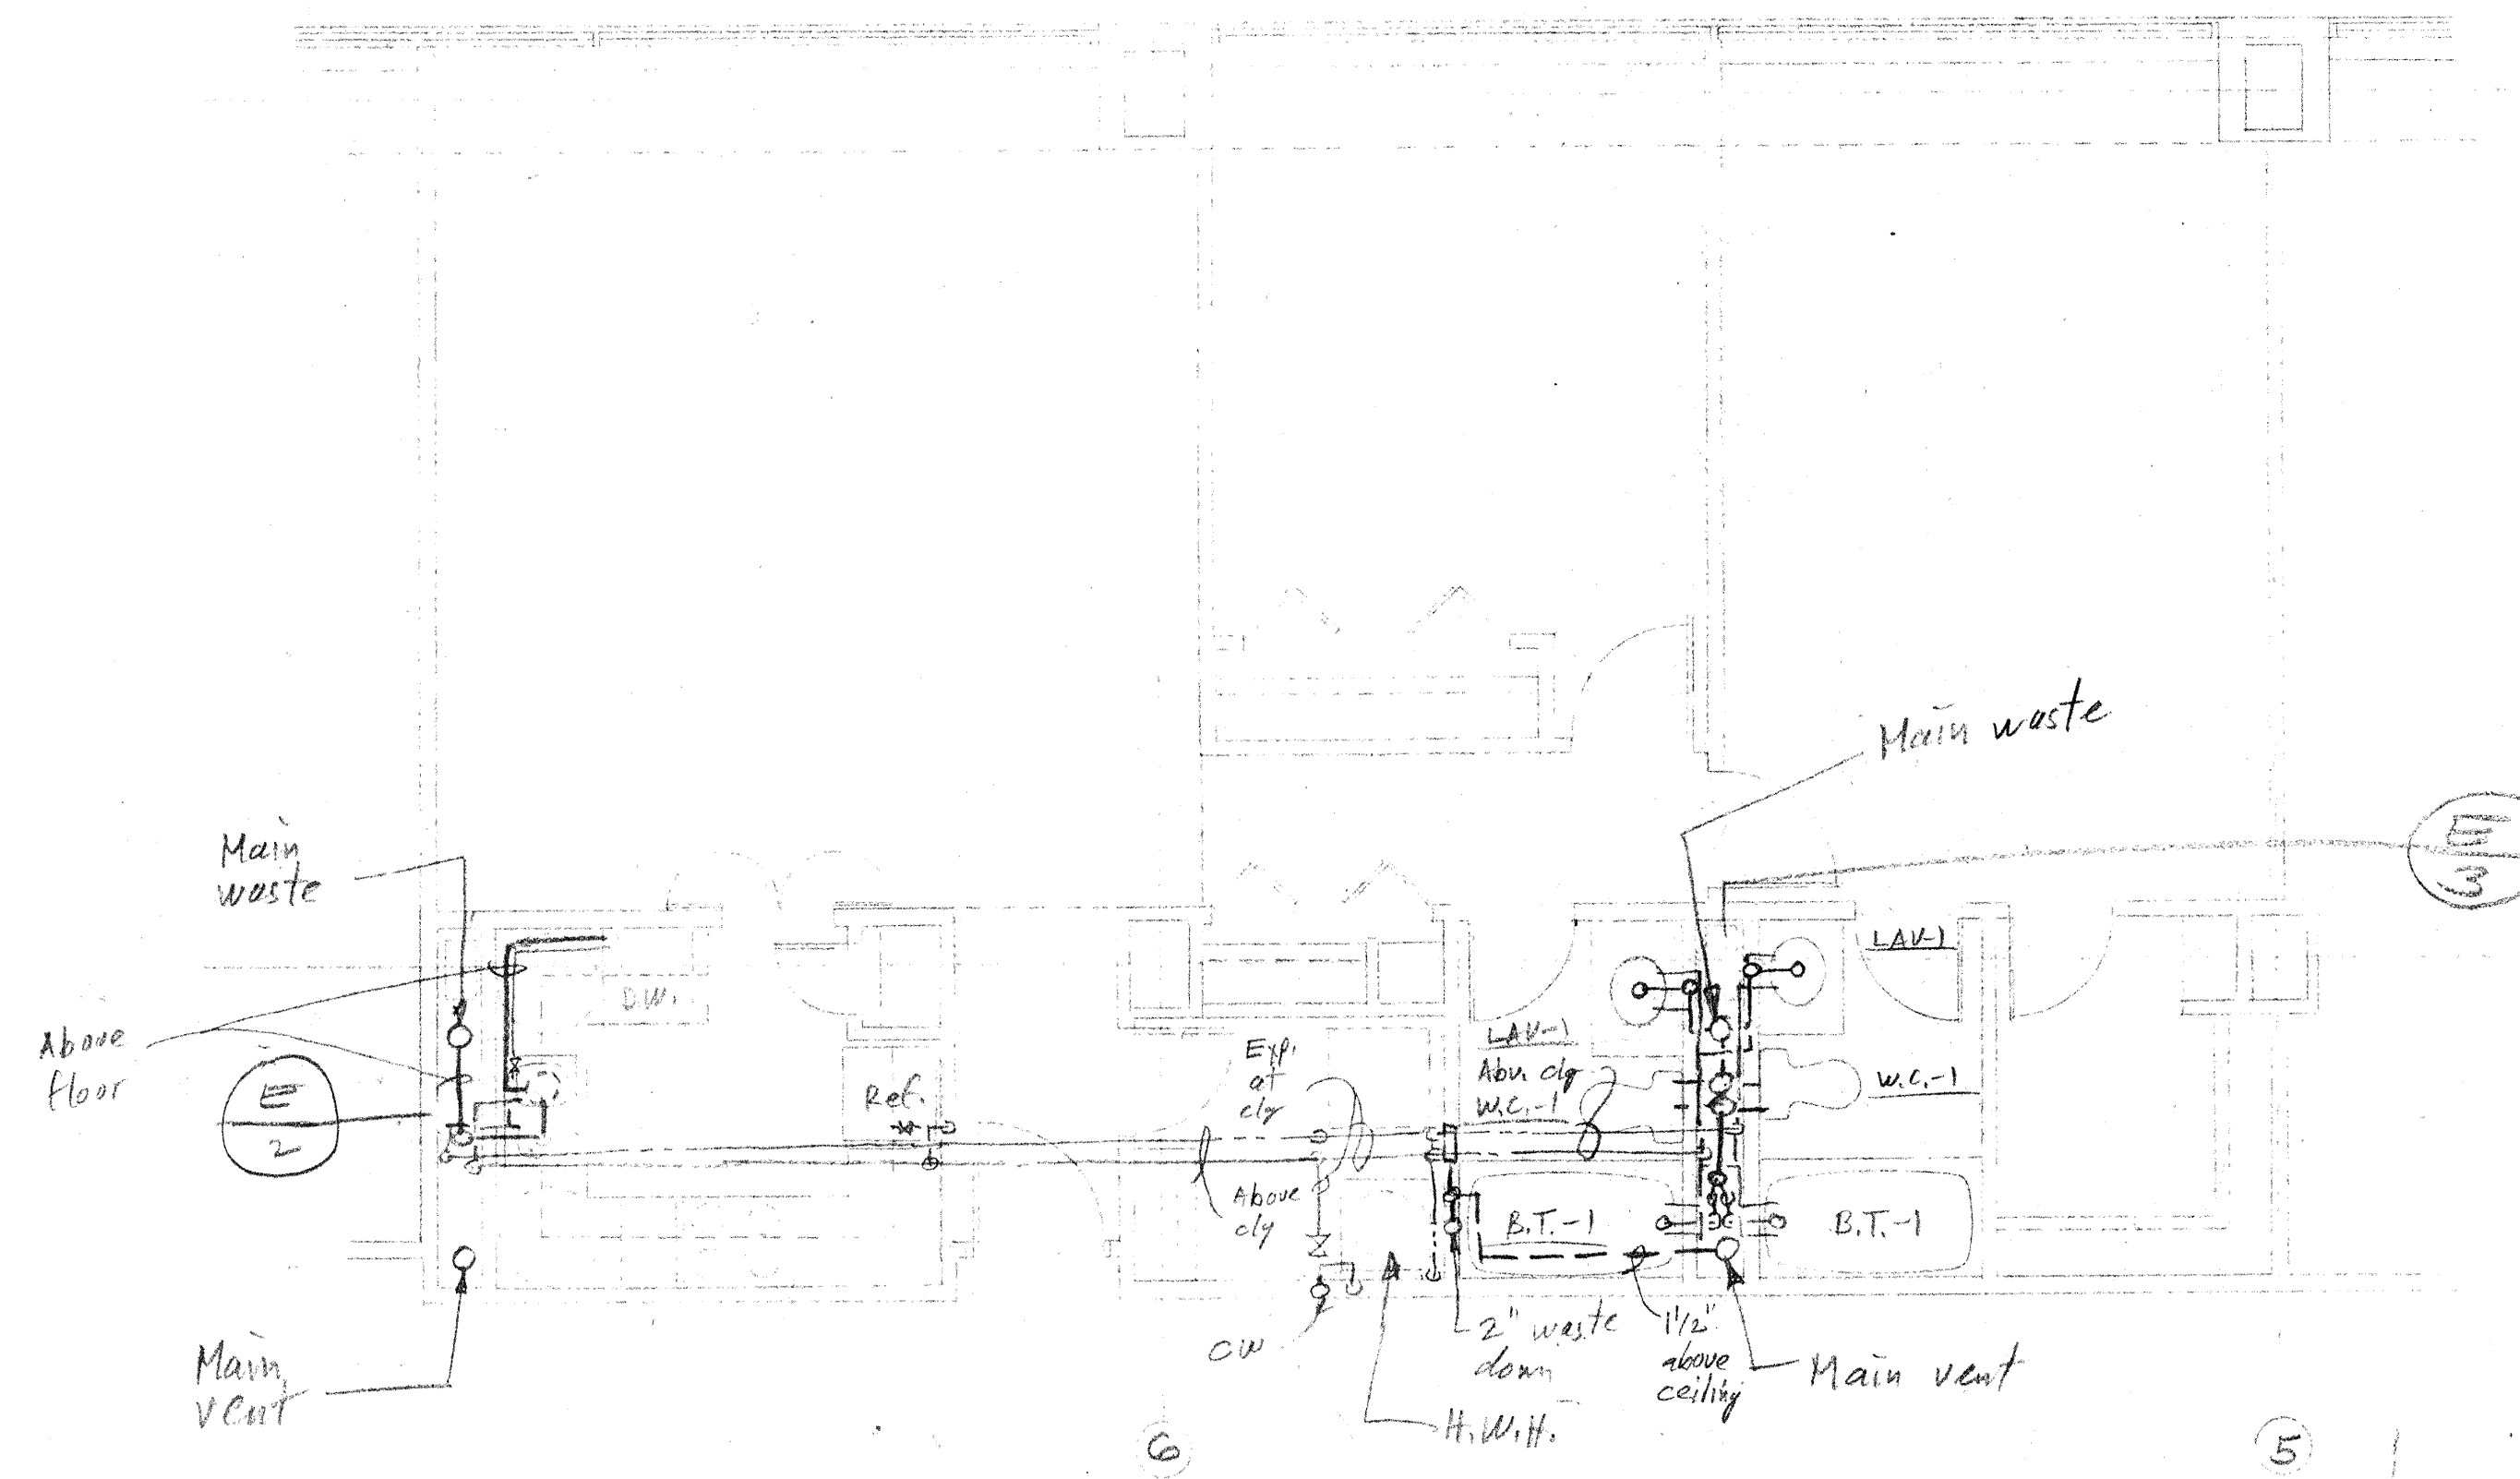


ENLARGED PLUMBING PLAN - TYPICAL FOR UNIT TYPE "D"
 scale: 1/4" = 1'-0"
 (2 typical)

Dec 12, 1983

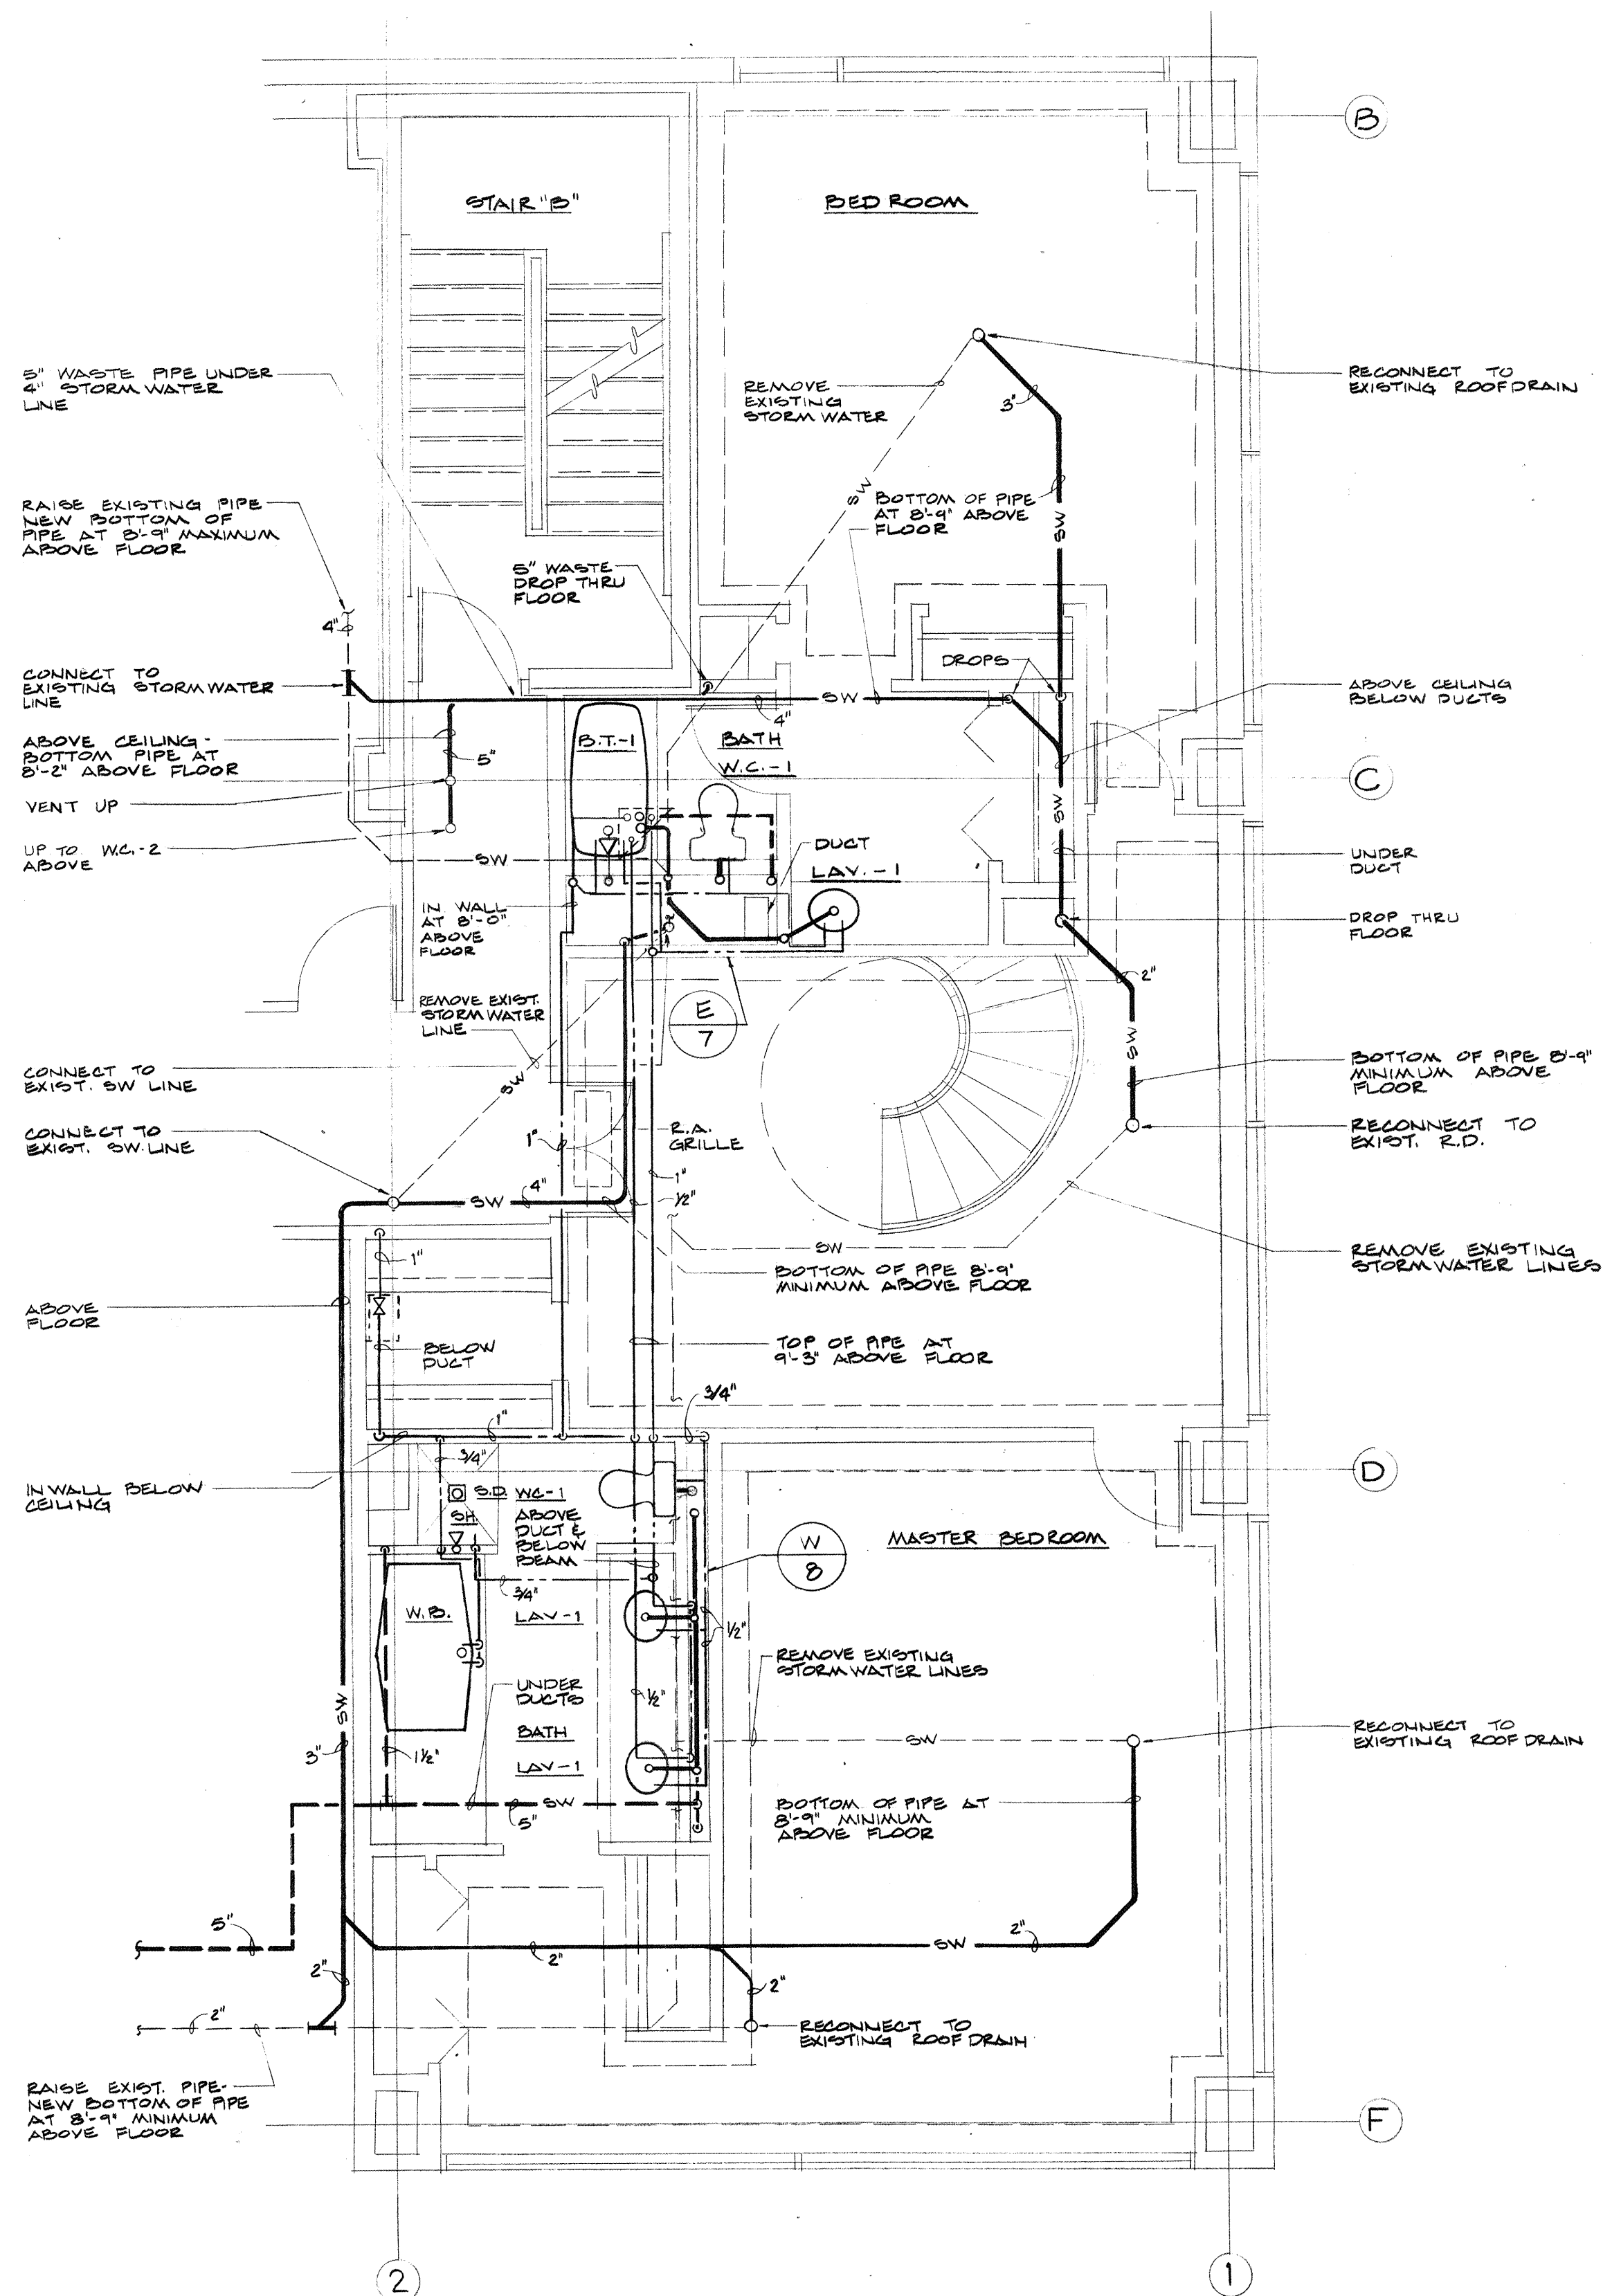

NOTE:
FOR WASTE AND VENT PIPING UNDER 10TH FLOOR SEE
1/8\"/>

ENLARGED PLUMBING PLAN - 10TH FLOOR -
WILKINSON UNIT
SCALE: 1/4\"/>

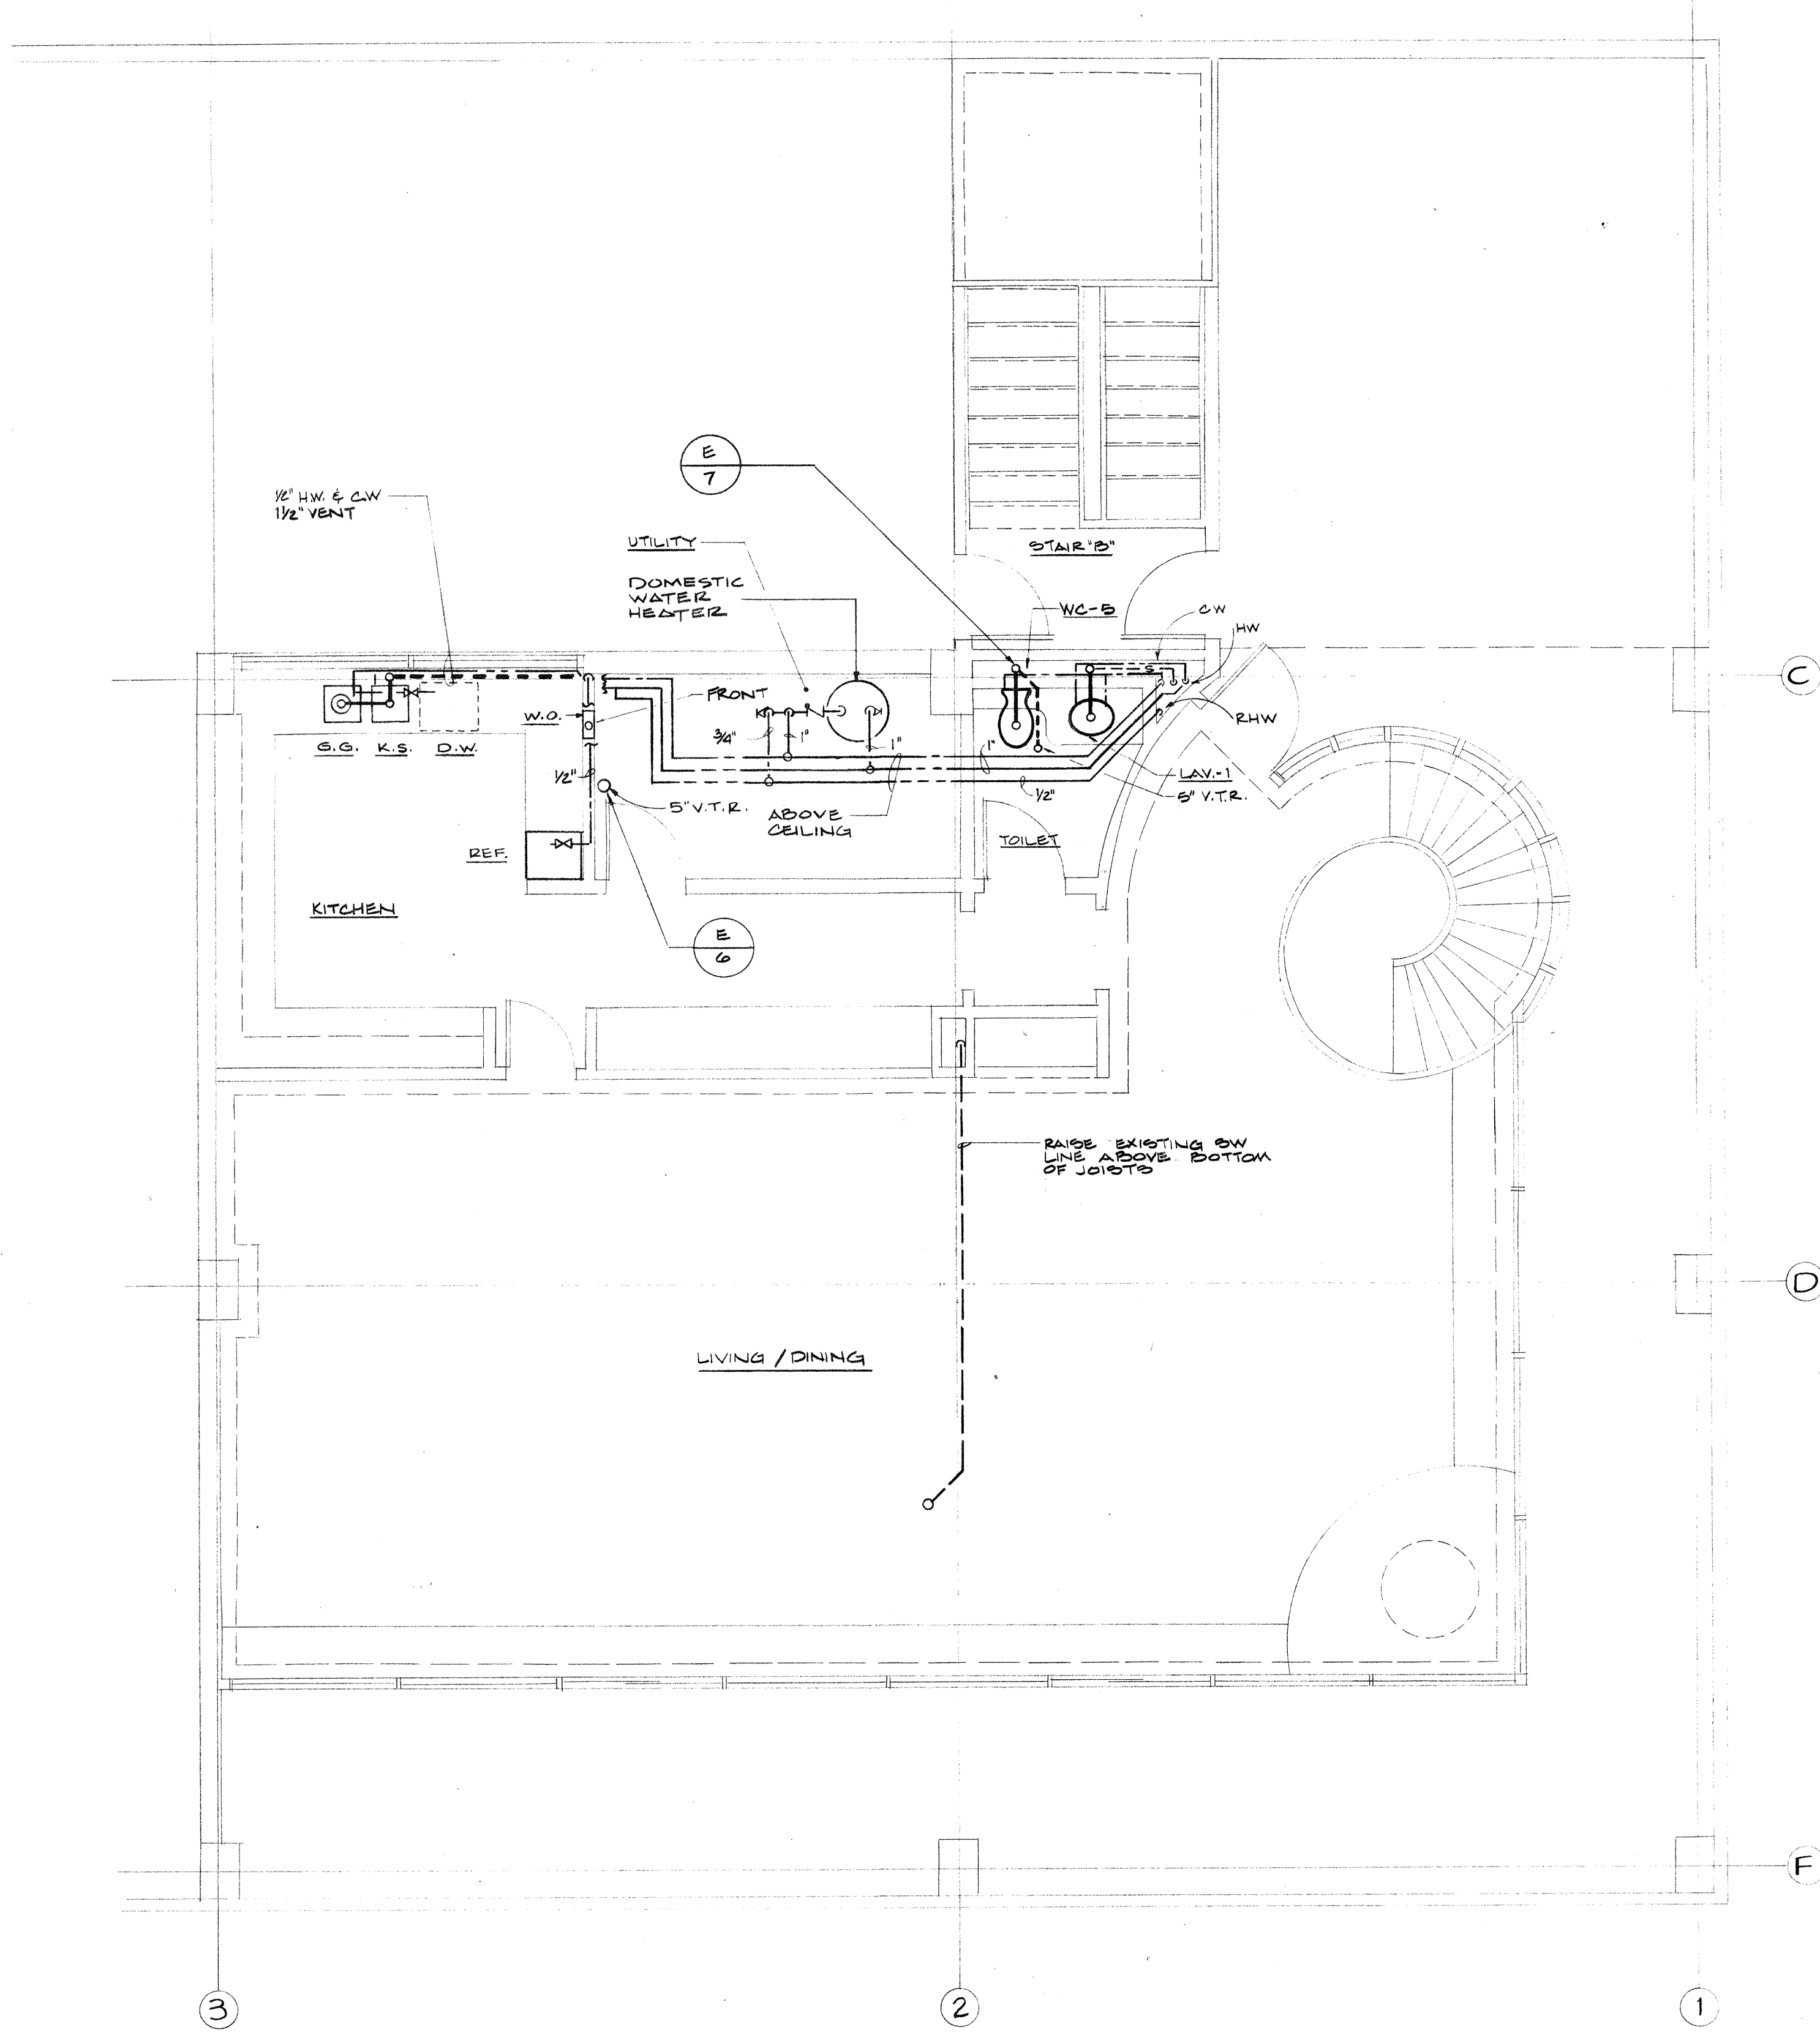




NOTE:
COLOR OF ALL PLUMBING FIXTURES IN WILKINSON
UNIT SHALL BE SELECTED BY OWNER.

ENLARGED PLUMBING PLAN - 11TH FLOOR
WILKINSON UNIT
SCALE: 1/4\"/>

Consulting Engineers
3257 Lochness Drive
Lexington, Kentucky


CARTER - FOSTER INC.

CAPITOL PLAZA HOTEL
FRANKFORT / KENTUCKY

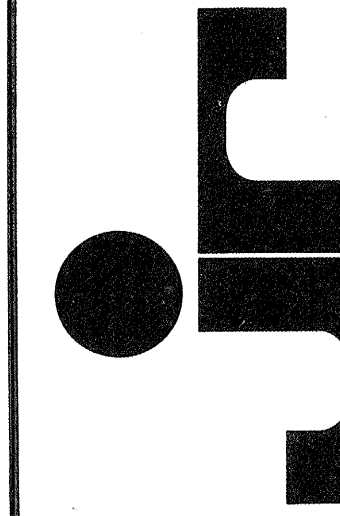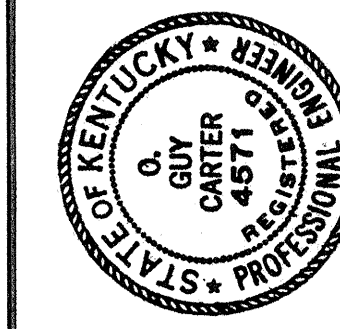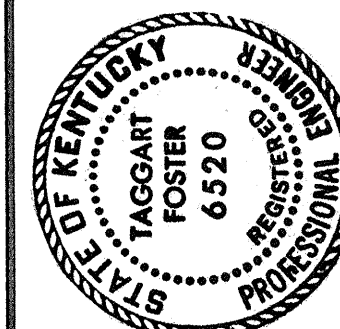


JOHNSON / ROMANOWITZ / ARCHITECTS / LEXINGTON / KENTUCKY
301 EAST VINE STREET, SUITE A
TELEPHONE (606) 252-6781


DRAWN K.P.	PROJECT
CHECKED T.F.	DATE 1-3-84
PLUMBING	
PLUMBING PLAN - WILKINSON UNIT	
DRAWING P-25 PRINTED 2-27-84 NEW DRAWING (1-3-84)	

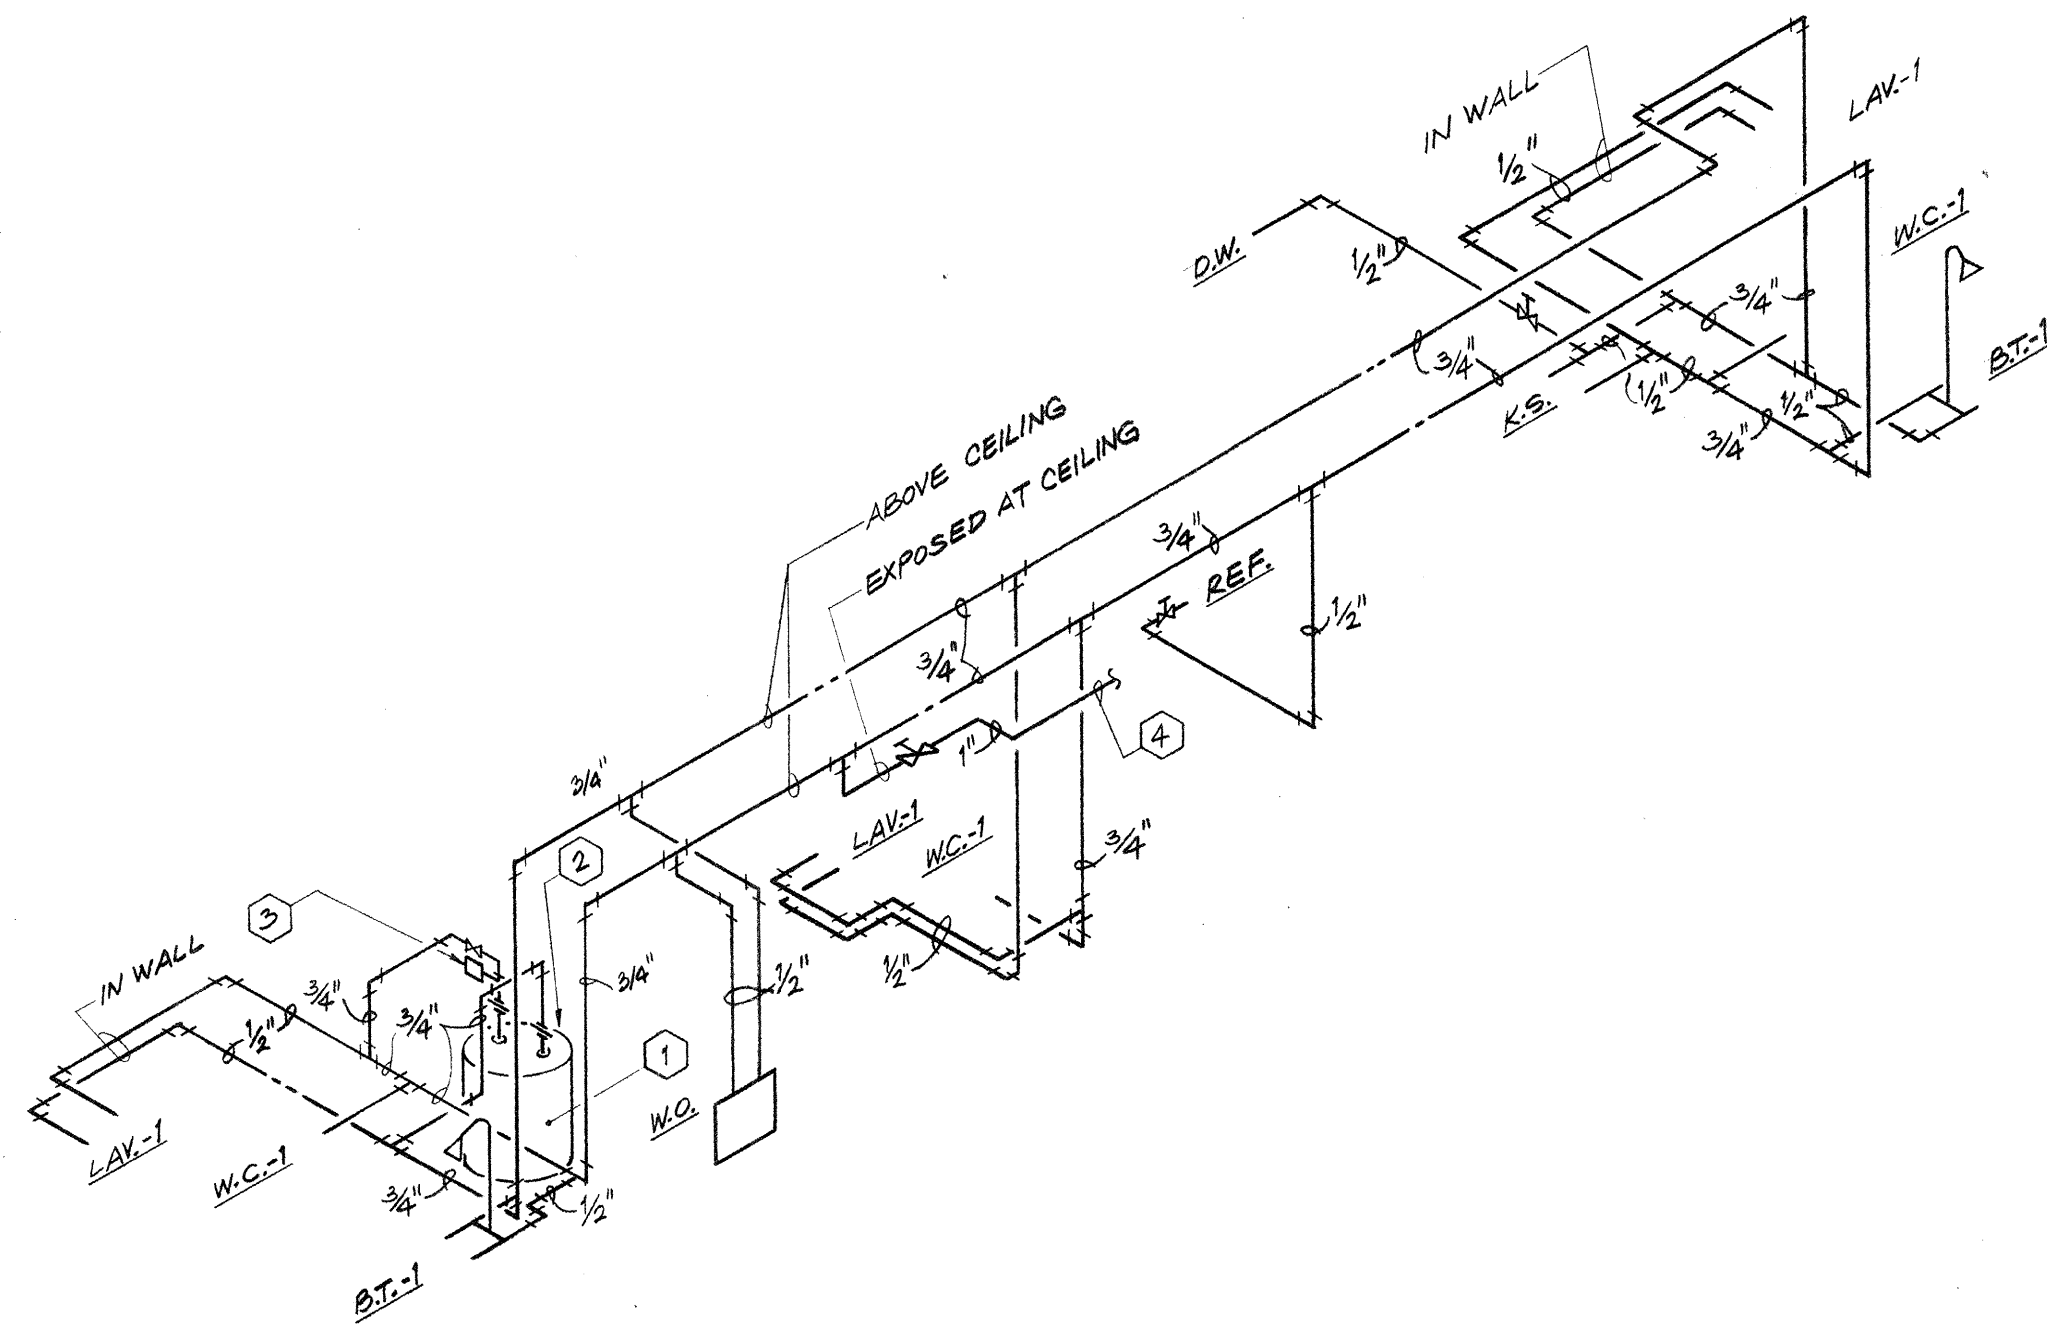


DOMESTIC WATER PIPING DIAGRAM - UNIT TYPE "A"
NO SCALE

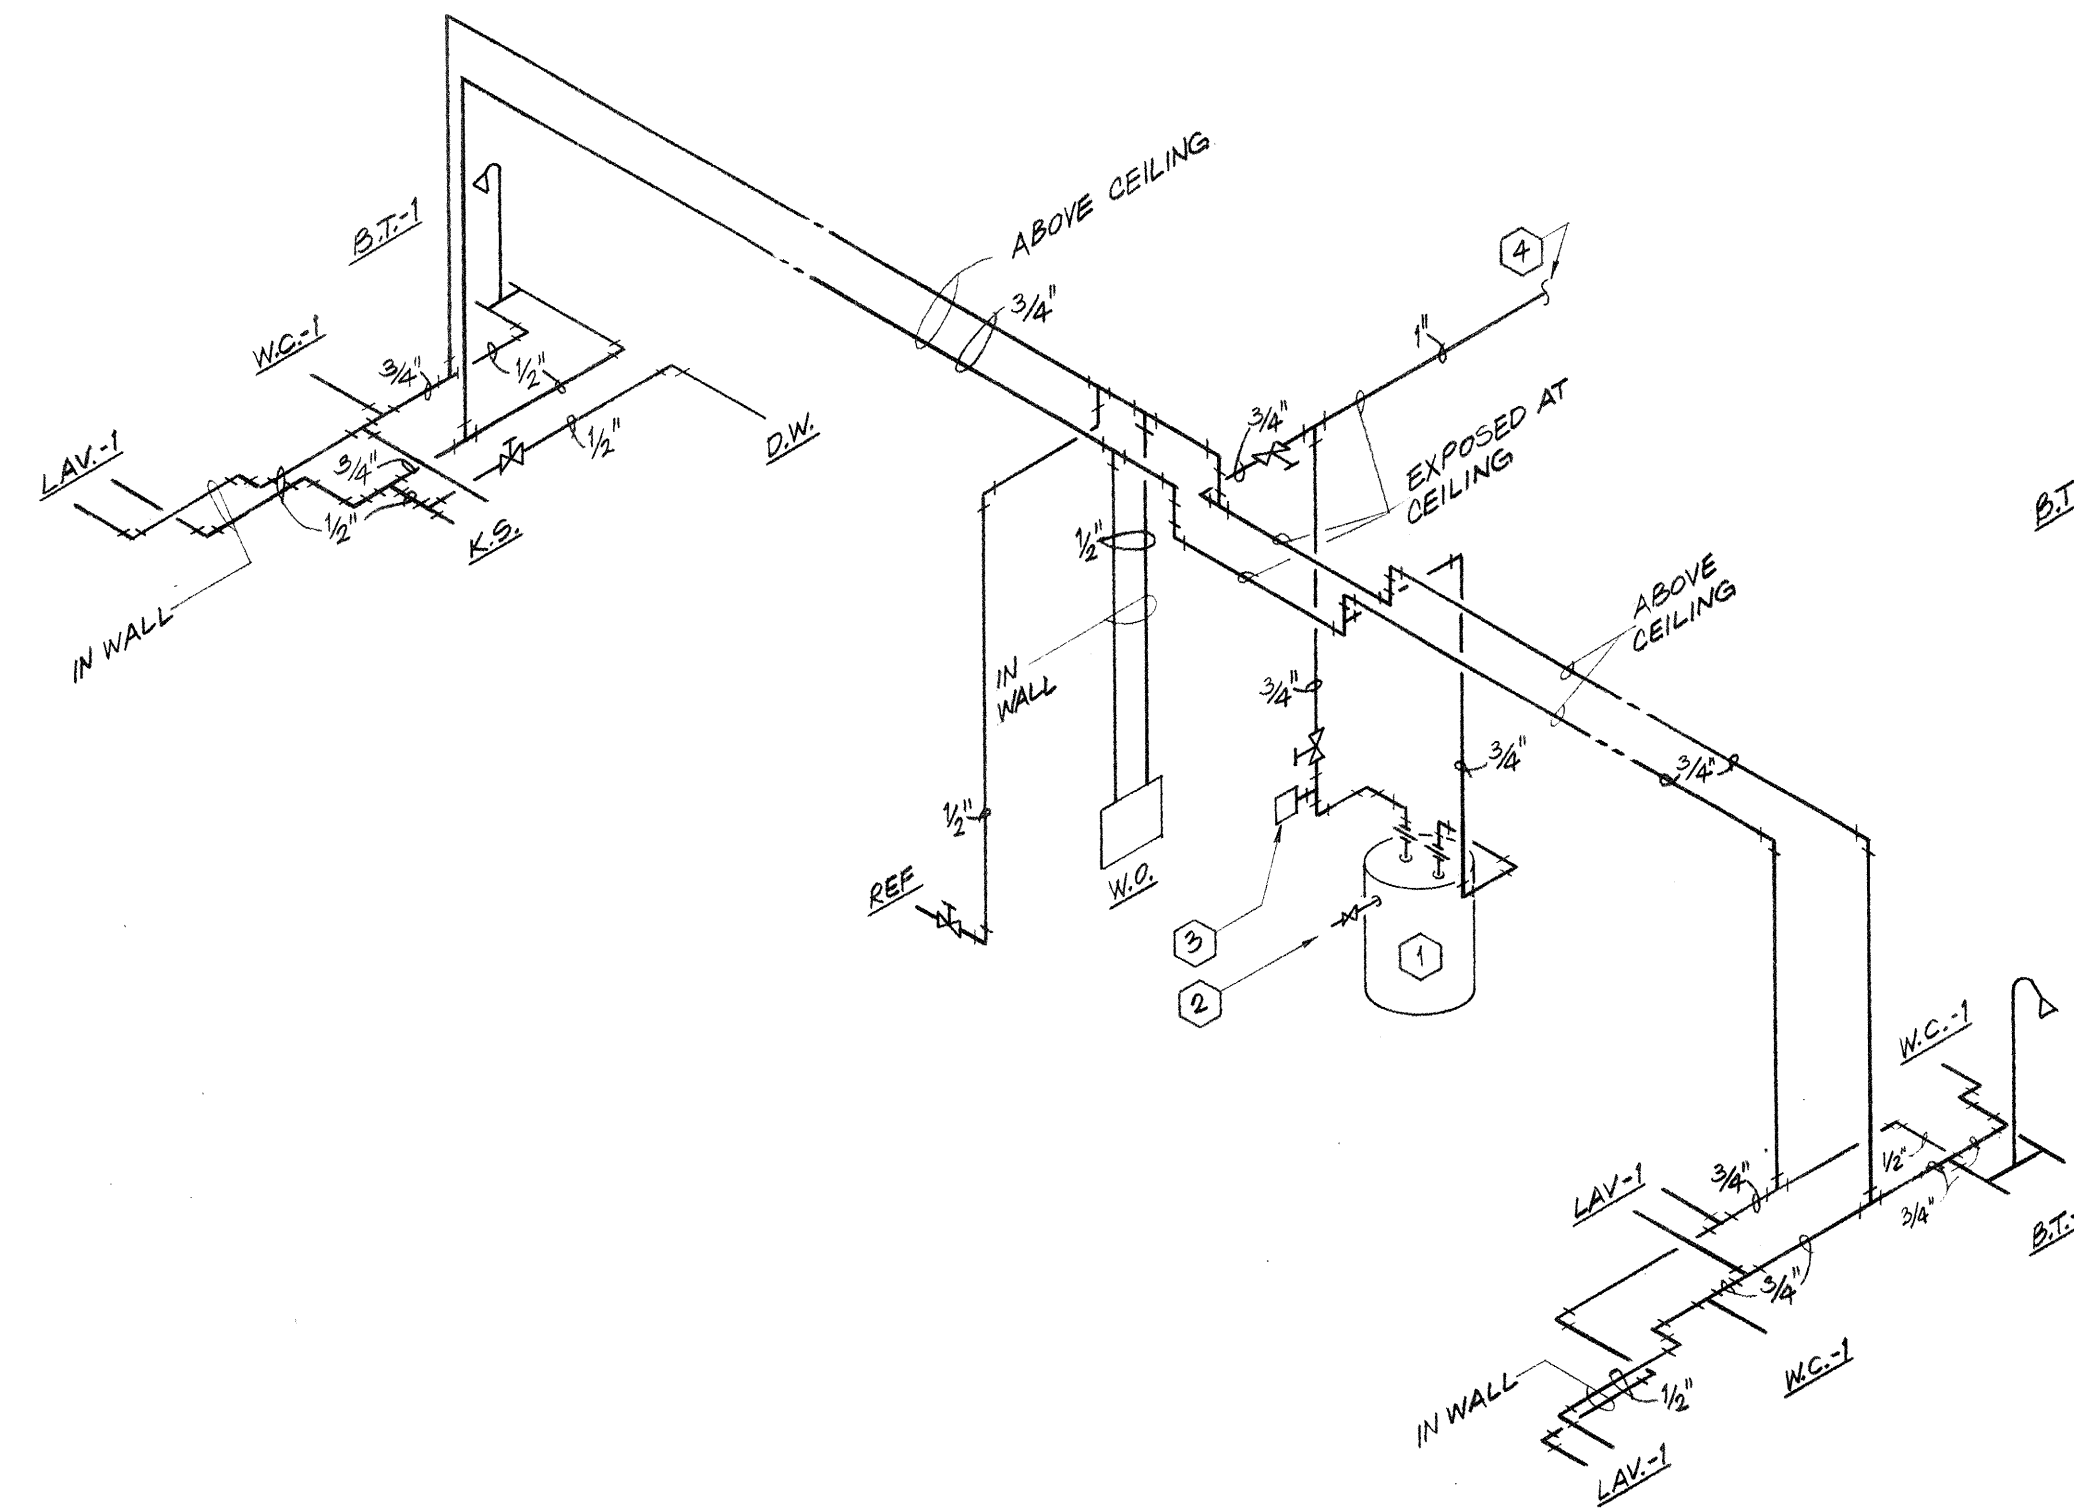


DOMESTIC WATER PIPING DIAGRAM - UNIT TYPE "B"
NO SCALE

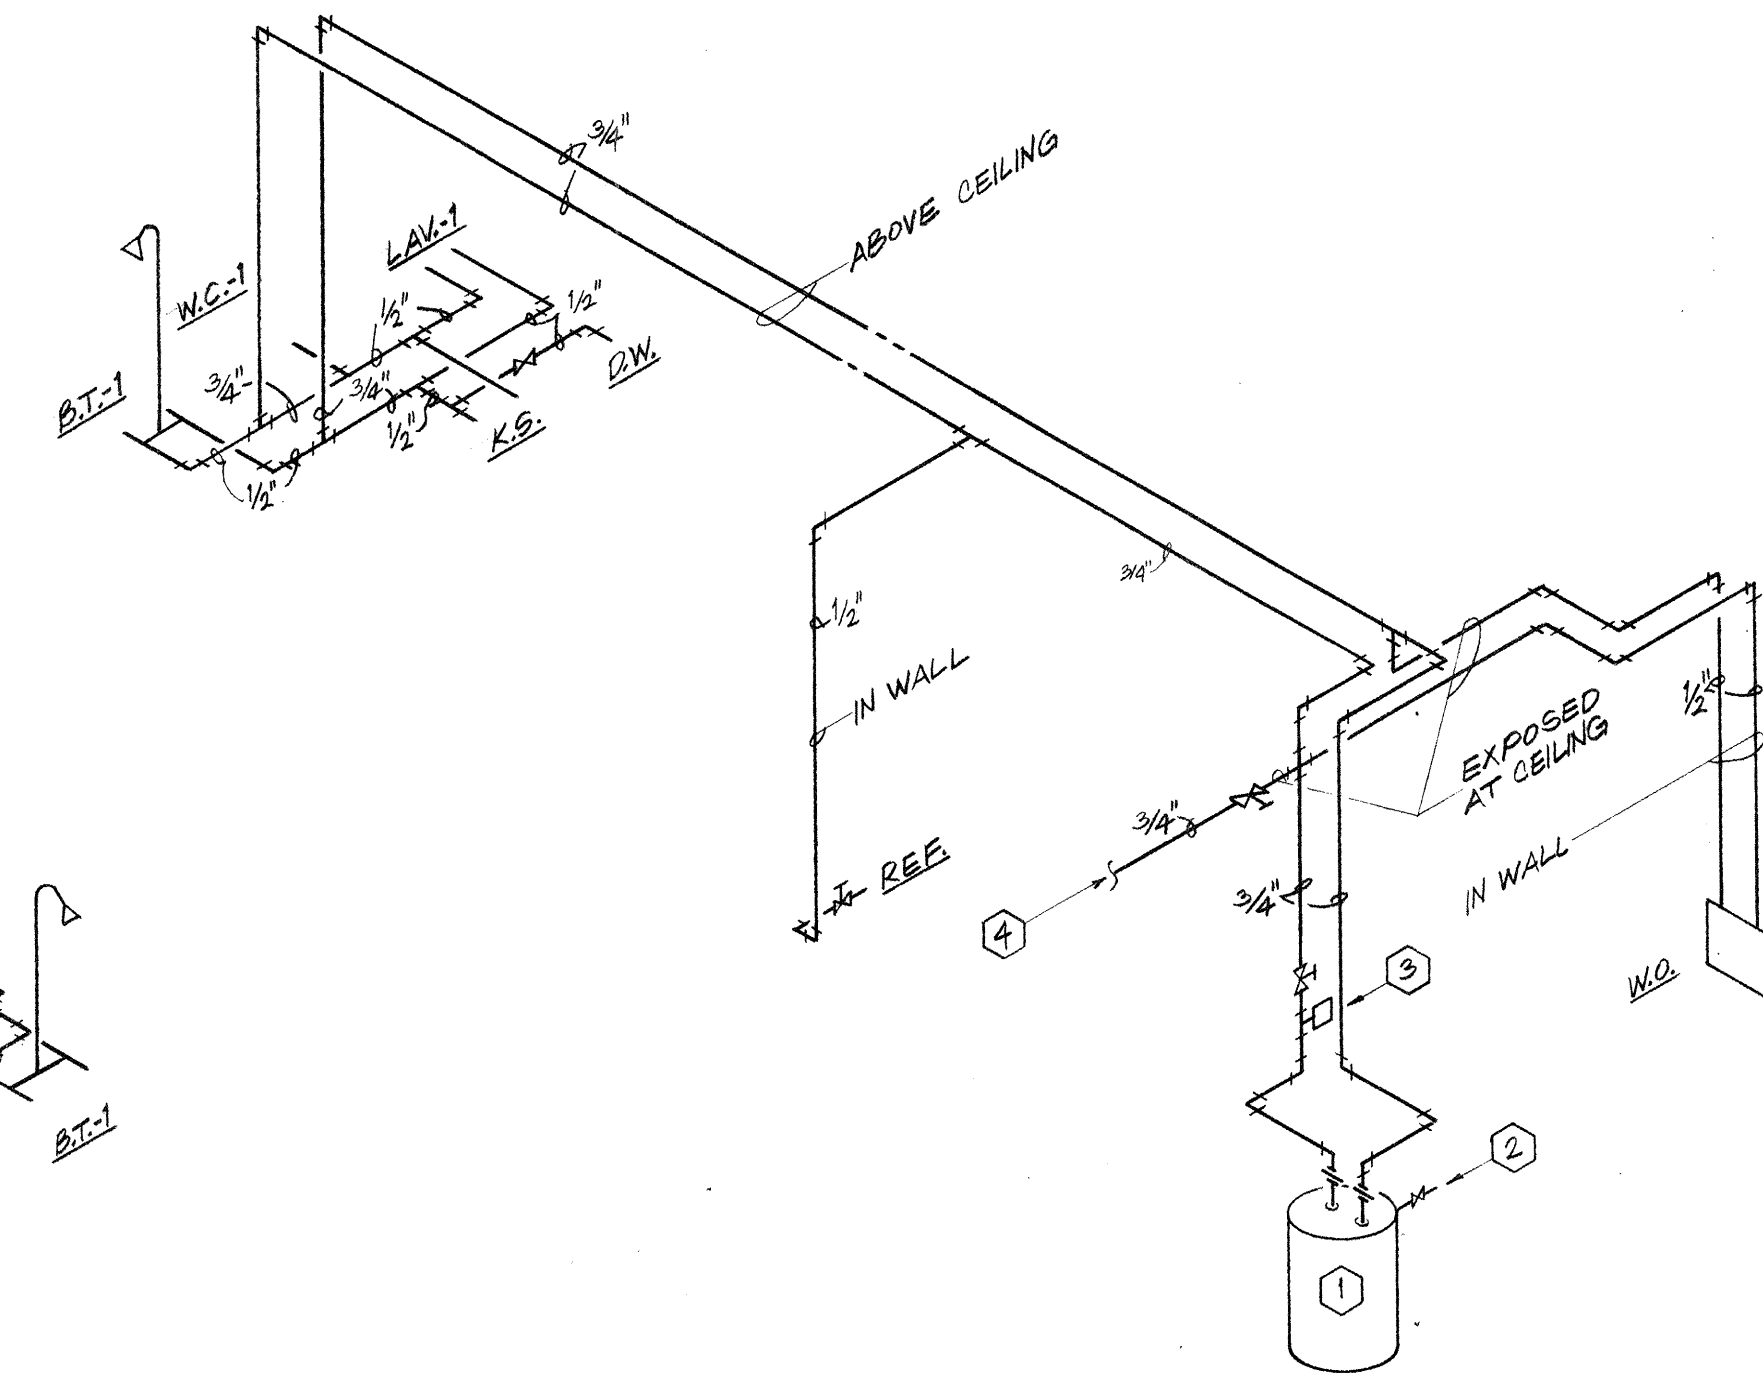


DOMESTIC WATER PIPING DIAGRAM - UNIT TYPE "C"
NO SCALE

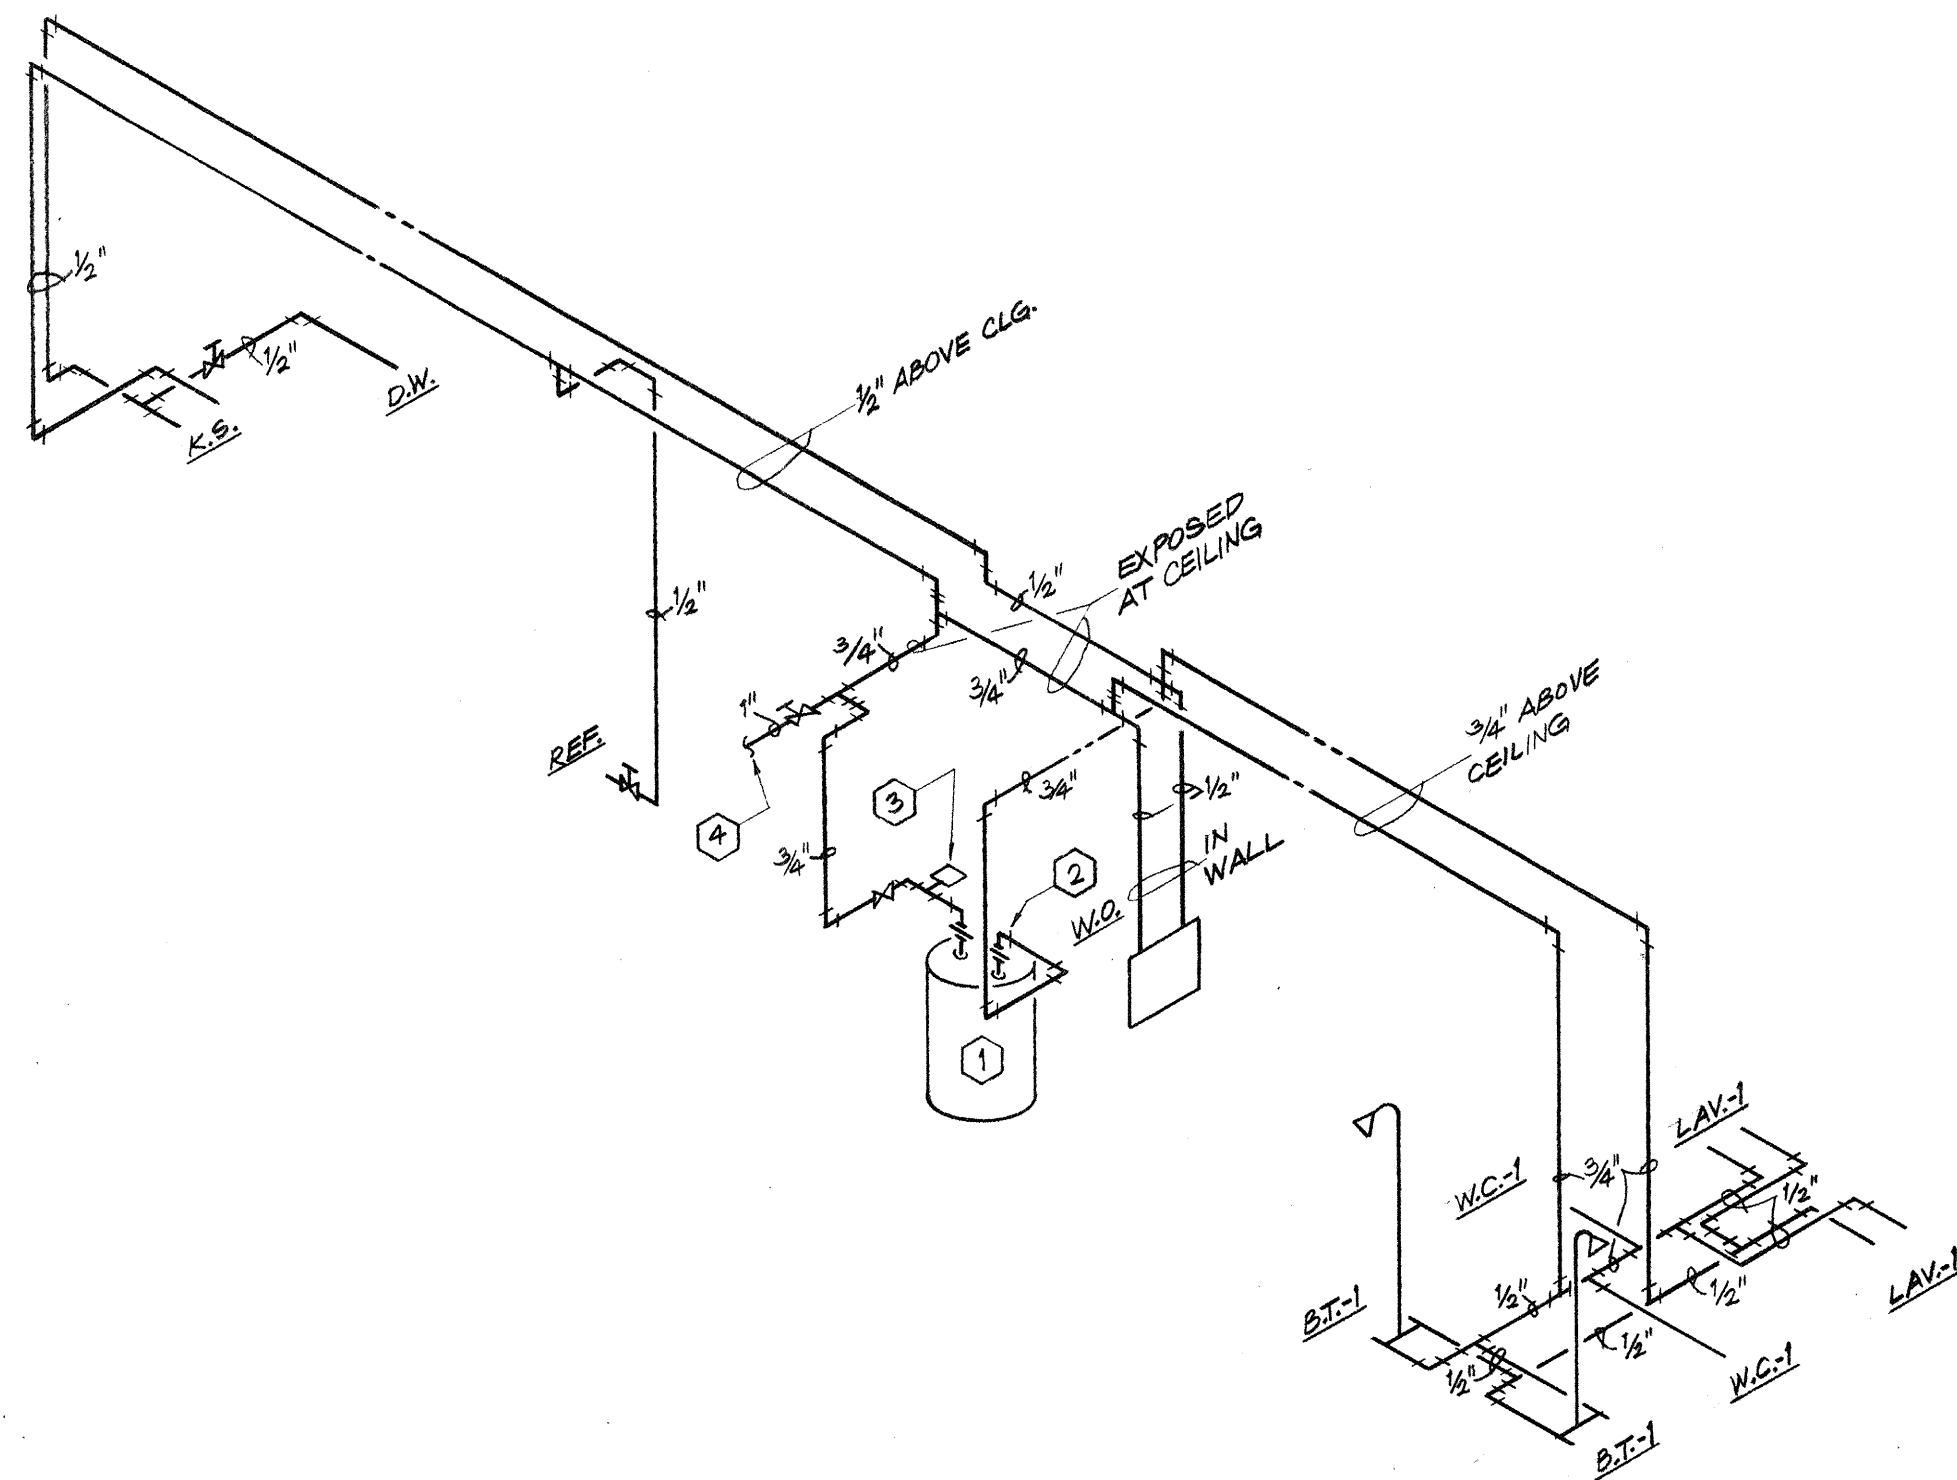

DOMESTIC WATER PIPING DIAGRAM - UNIT TYPE "D"
NO SCALE

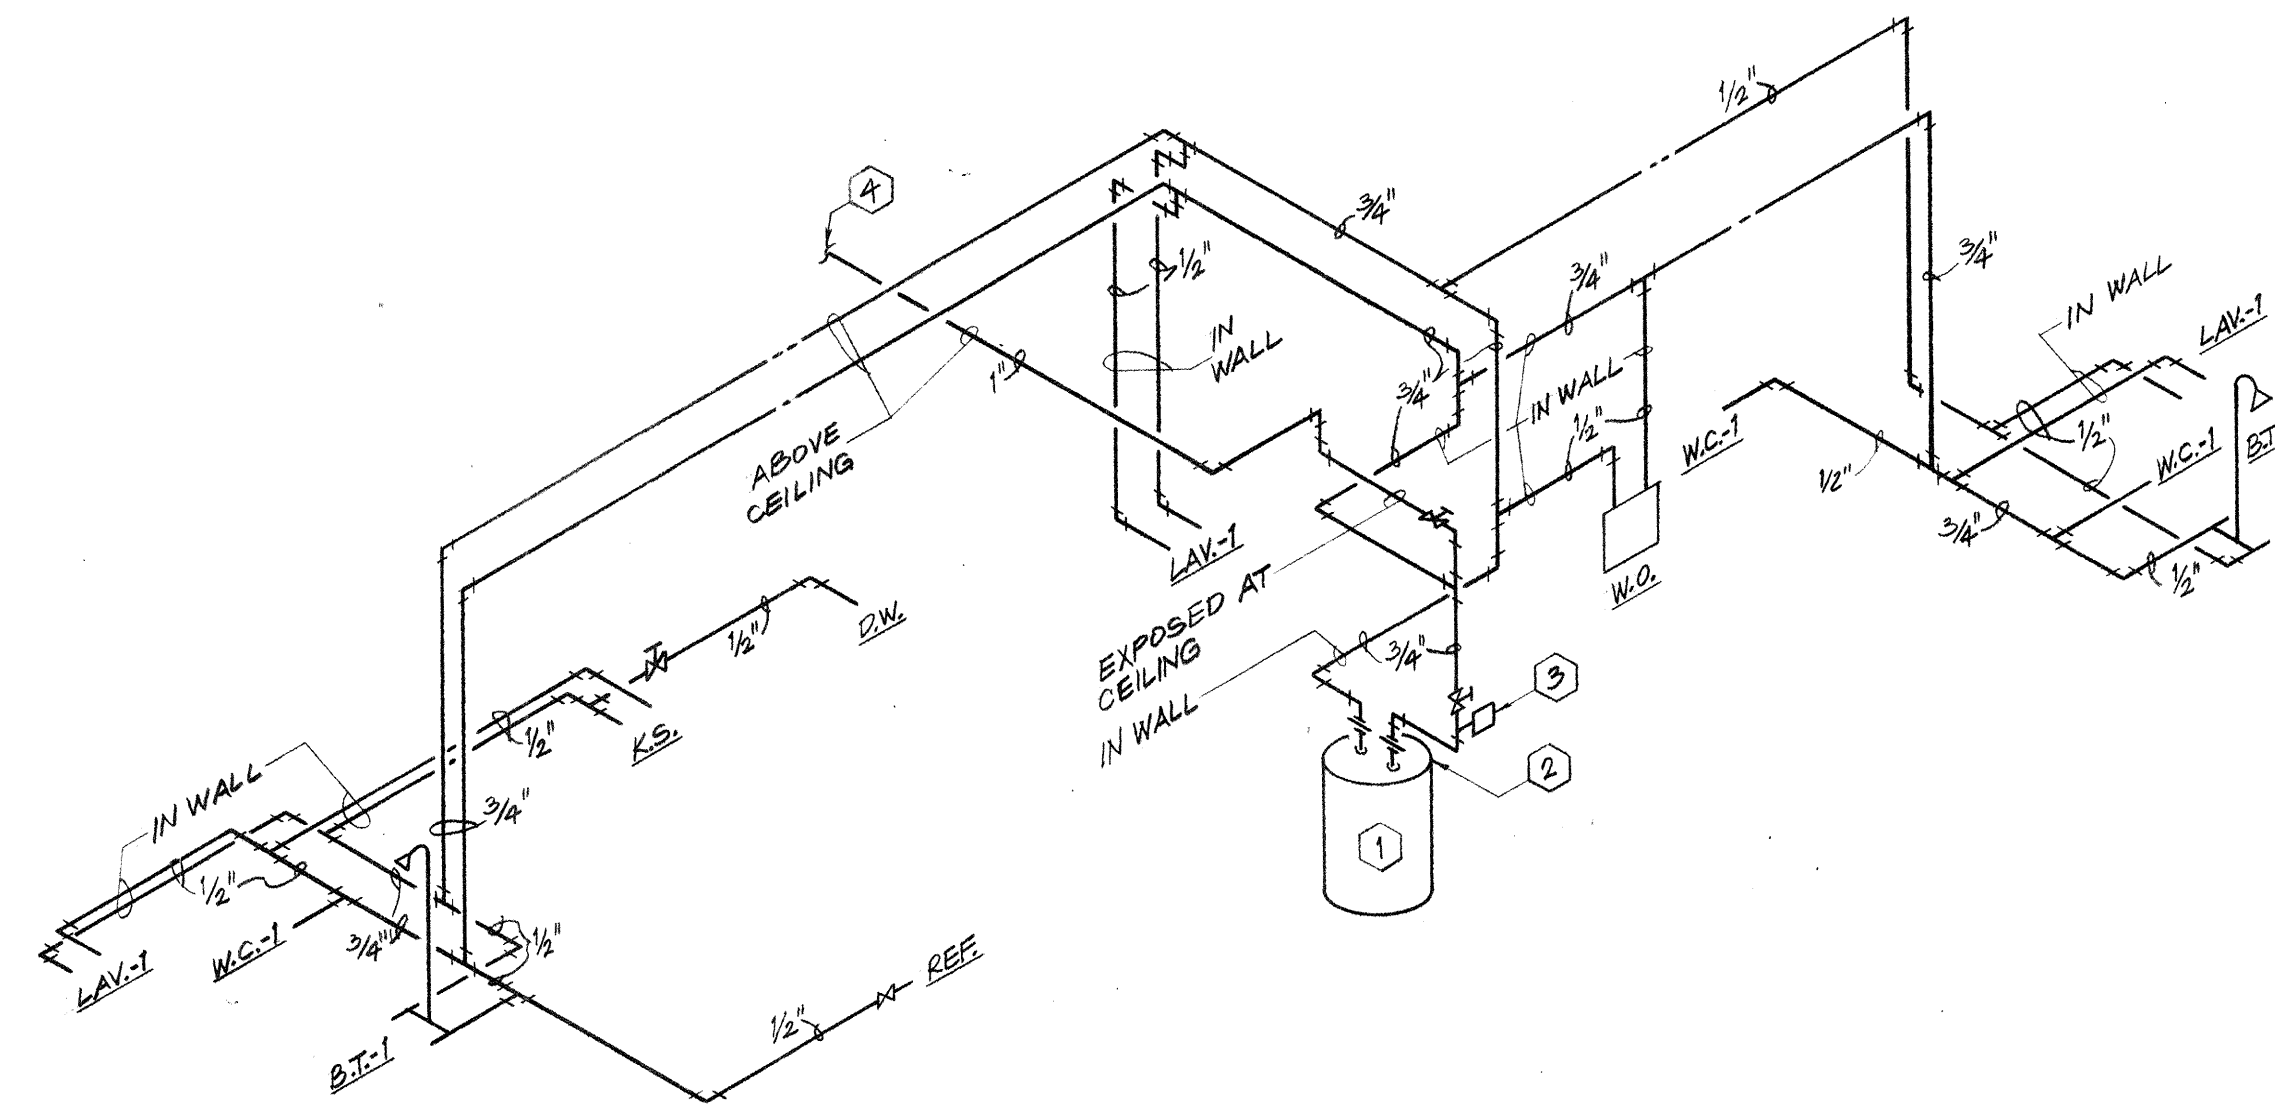

DOMESTIC WATER PIPING DIAGRAM - UNIT TYPE "E"
NO SCALE


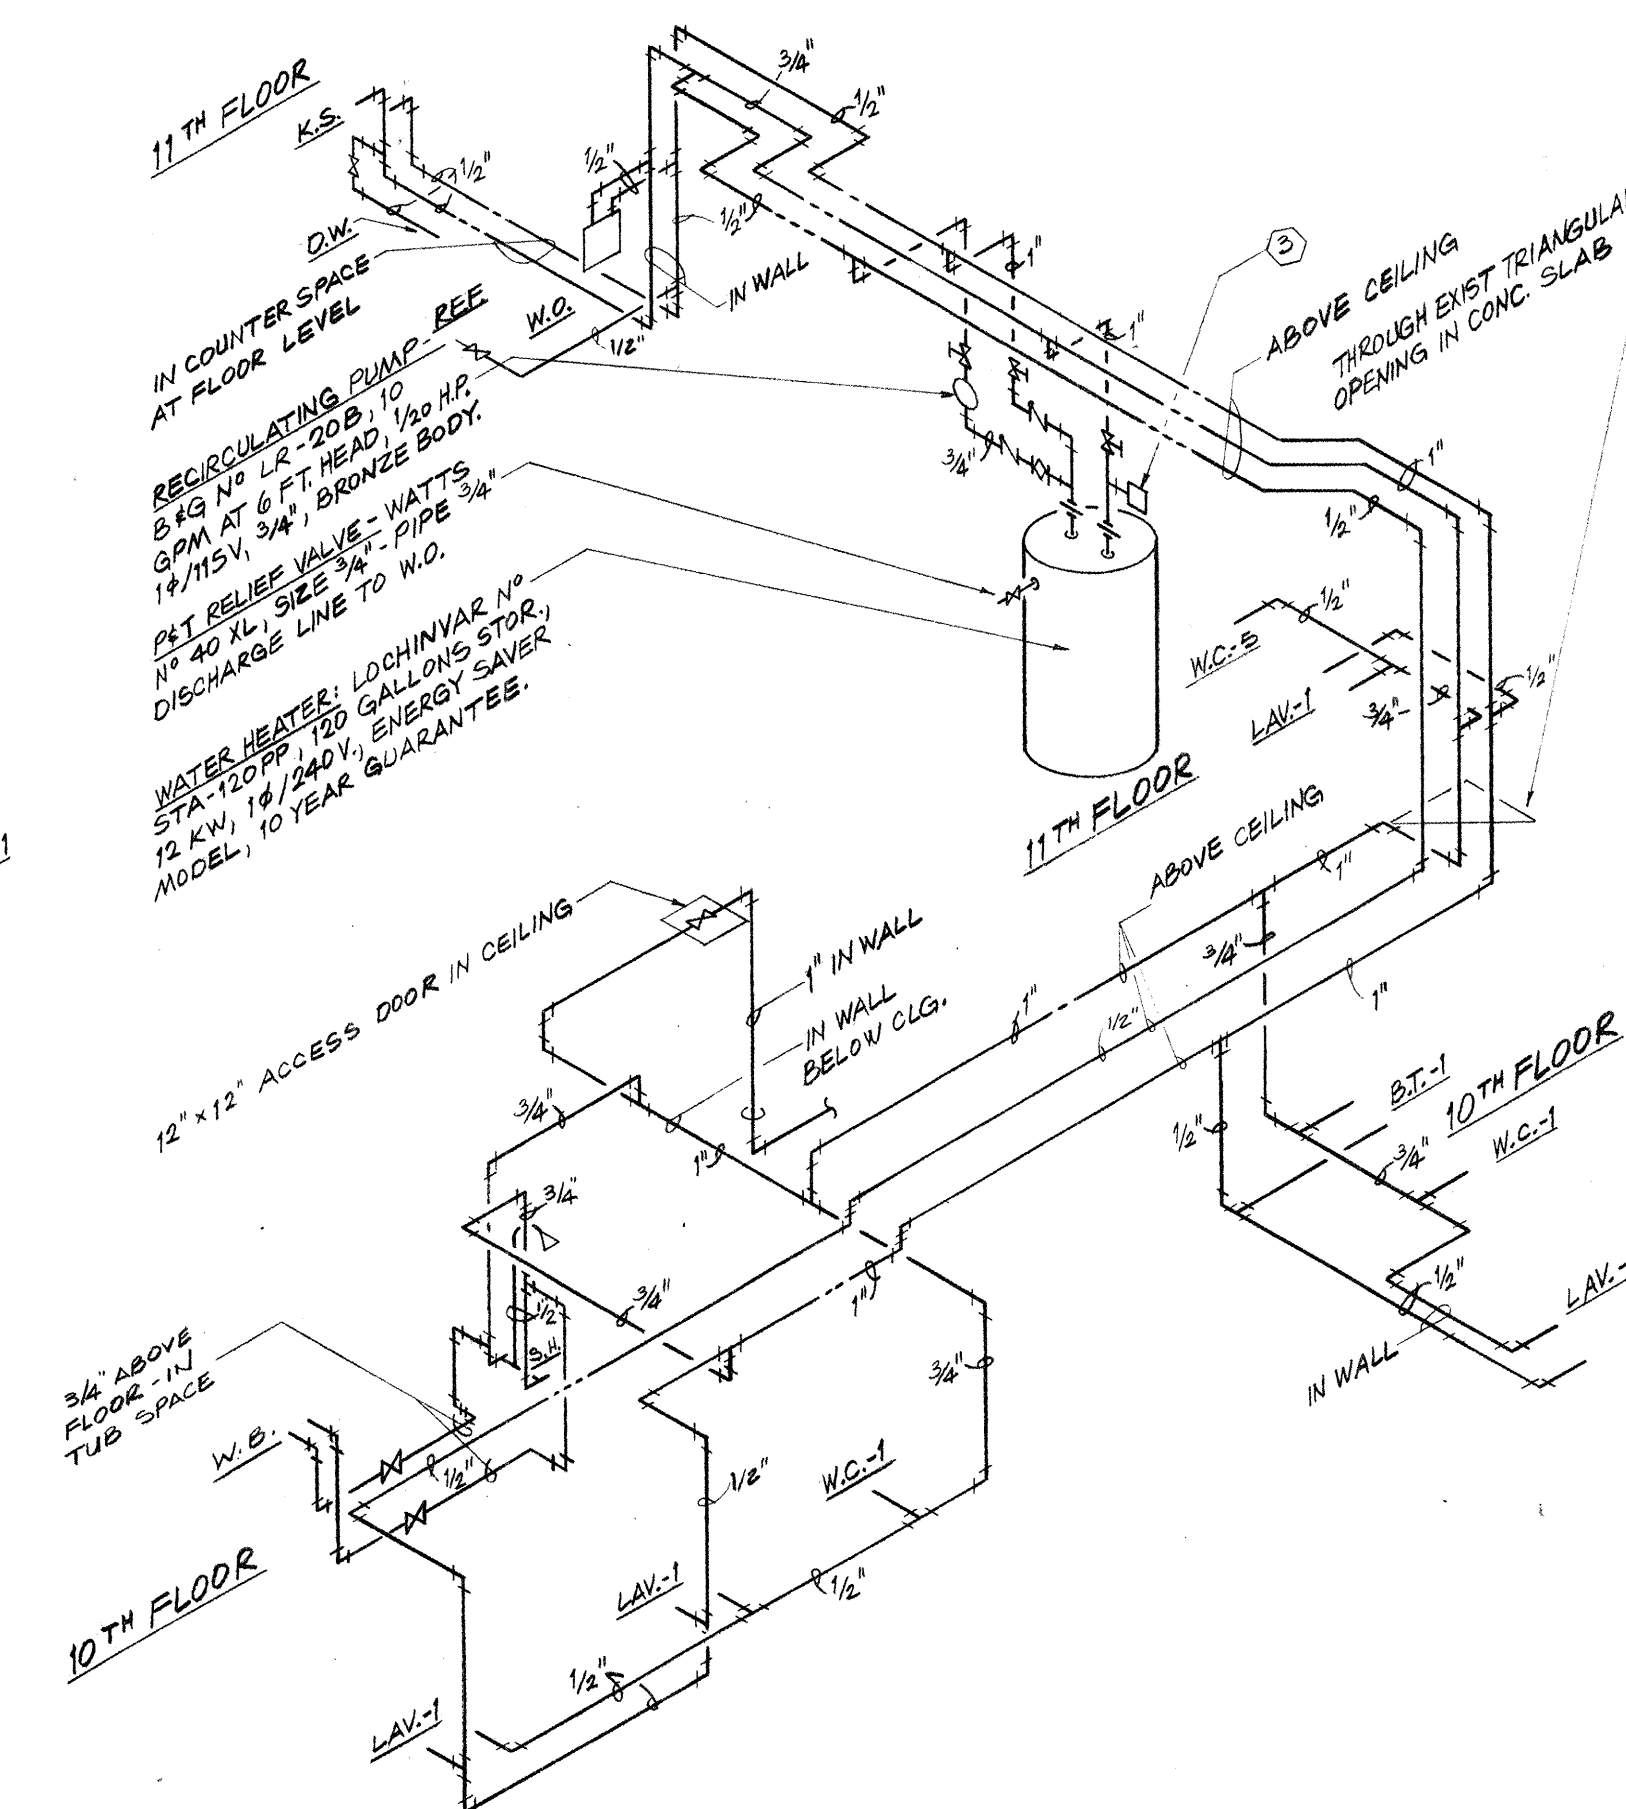


DOMESTIC WATER PIPING DIAGRAM - WILKINSON UNIT
NO SCALE

Consulting Engineers
3257 Lochness Drive
Lexington, Kentucky

CARTER - FOSTER INC.

CAPITOL PLAZA HOTEL
FRANKFORT / KENTUCKY

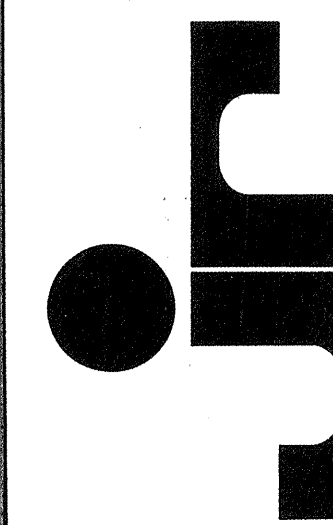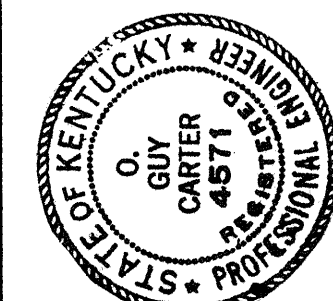

JOHNSON/ROMANOWITZ ARCHITECTS / LEXINGTON / KENTUCKY
301 EAST VINE STREET, SUITE A
TELEPHONE (606) 252-6781

DRAWN M.K.P.	PROJECT
CHECKED T.F.	DATE 1-3-84

PLUMBING

DOMESTIC WATER
PIPING DIAGRAMS
CONDOMINIUMS

DRAWING
P-26
PRINTED 2/84

NEW DRAWING (1-3-84)